

[illegible]

P.A.:	JTG
P.M.:	TRT
DRAWN BY:	Author
PROJECT NO:	1022747

[illegible]

SCALE:	AS INDICATED
DATE:	12/15/22

© The Martin Architectural Group, P.C.


This mechanical floor plan illustrates the HVAC and exhaust systems for a multi-level building. The plan is organized into horizontal sections representing different levels: ROOF, LEVEL 4, LEVEL 3, LEVEL 2, LEVEL 1, CLUB LEVEL 2, CLUB LEVEL 1, and RETAIL LEVEL.

Key Components and Systems:

- Roof Level:** Features three DOAS (Direct Outdoor Air System) units labeled DOAS 1, DOAS 2, and DOAS 3. DOAS 1 is connected to a 44x12 duct. DOAS 2 is connected to a 34x12 duct. DOAS 3 is connected to a 20x22 duct. There are also two EF (Exhaust Fan) units labeled EF 2 and EF 4.
- Level 4:** Shows a 20x12 EA (Exhaust Air) duct and a 2-HR FIRE BARRIER DUCT WRAP. It includes several CD-1 (Ceiling Diffuser) units with 24x24 openings and 450 CFM flow rates, connected to VD (Variable Damper) and FSD (Fan Speed Damper) controls.
- Level 3:** Features a 24x12 SA (Supply Air) duct and a 18x12 EA duct. It includes several CD-1 units with 24x24 openings and 450 CFM flow rates, connected to VD and FSD controls.
- Level 2:** Shows a 18x12 SA duct and a 14x6 SA duct. It includes several CD-1 units with 24x24 openings and 450 CFM flow rates, connected to VD and FSD controls.
- Level 1:** Features a 18x12 EA duct and a 12x18 SA duct. It includes several CD-1 units with 24x24 openings and 450 CFM flow rates, connected to VD and FSD controls.
- Club Level 2:** Shows a 18x12 EA duct and a 12x18 SA duct. It includes several CD-1 units with 24x24 openings and 450 CFM flow rates, connected to VD and FSD controls.
- Club Level 1:** Features a 18x12 EA duct and a 12x18 SA duct. It includes several CD-1 units with 24x24 openings and 450 CFM flow rates, connected to VD and FSD controls.
- Retail Level:** Shows a 18x12 EA duct and a 12x18 SA duct. It includes several CD-1 units with 24x24 openings and 450 CFM flow rates, connected to VD and FSD controls.
- General Exhaust Duct:** A 36x12 EA (4000 CFM) duct is shown on the right side of the plan, with a note indicating it is a GENERAL EXHAUST DUCT TO RETAIL SPACES FOR FUTURE TENANT CONNECTION.


The plan also includes various other components such as FSD (Fan Speed Damper), VD (Variable Damper), and CD-1 (Ceiling Diffuser) units, along with their respective flow rates and duct sizes.

Printed: 1/13/2023 12:03:50 PM

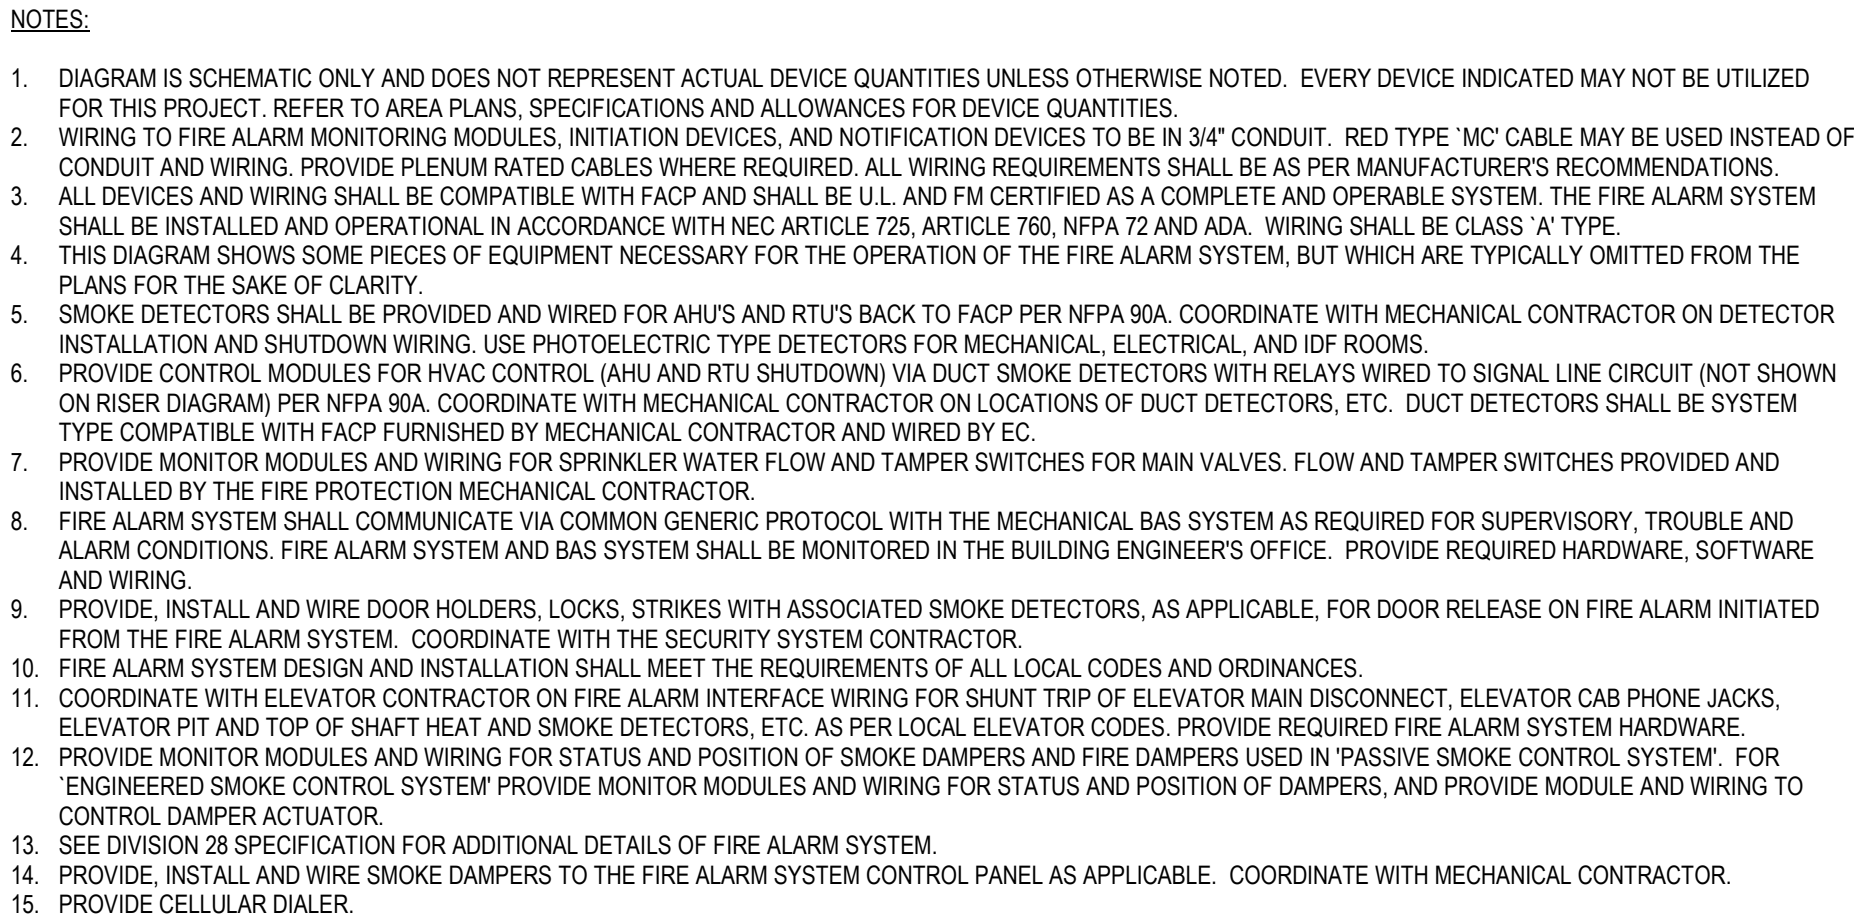

1 FIRE AL
FA0.31 NOT TO SCALE

Printed: 1/13/2023 12:03:55 PM

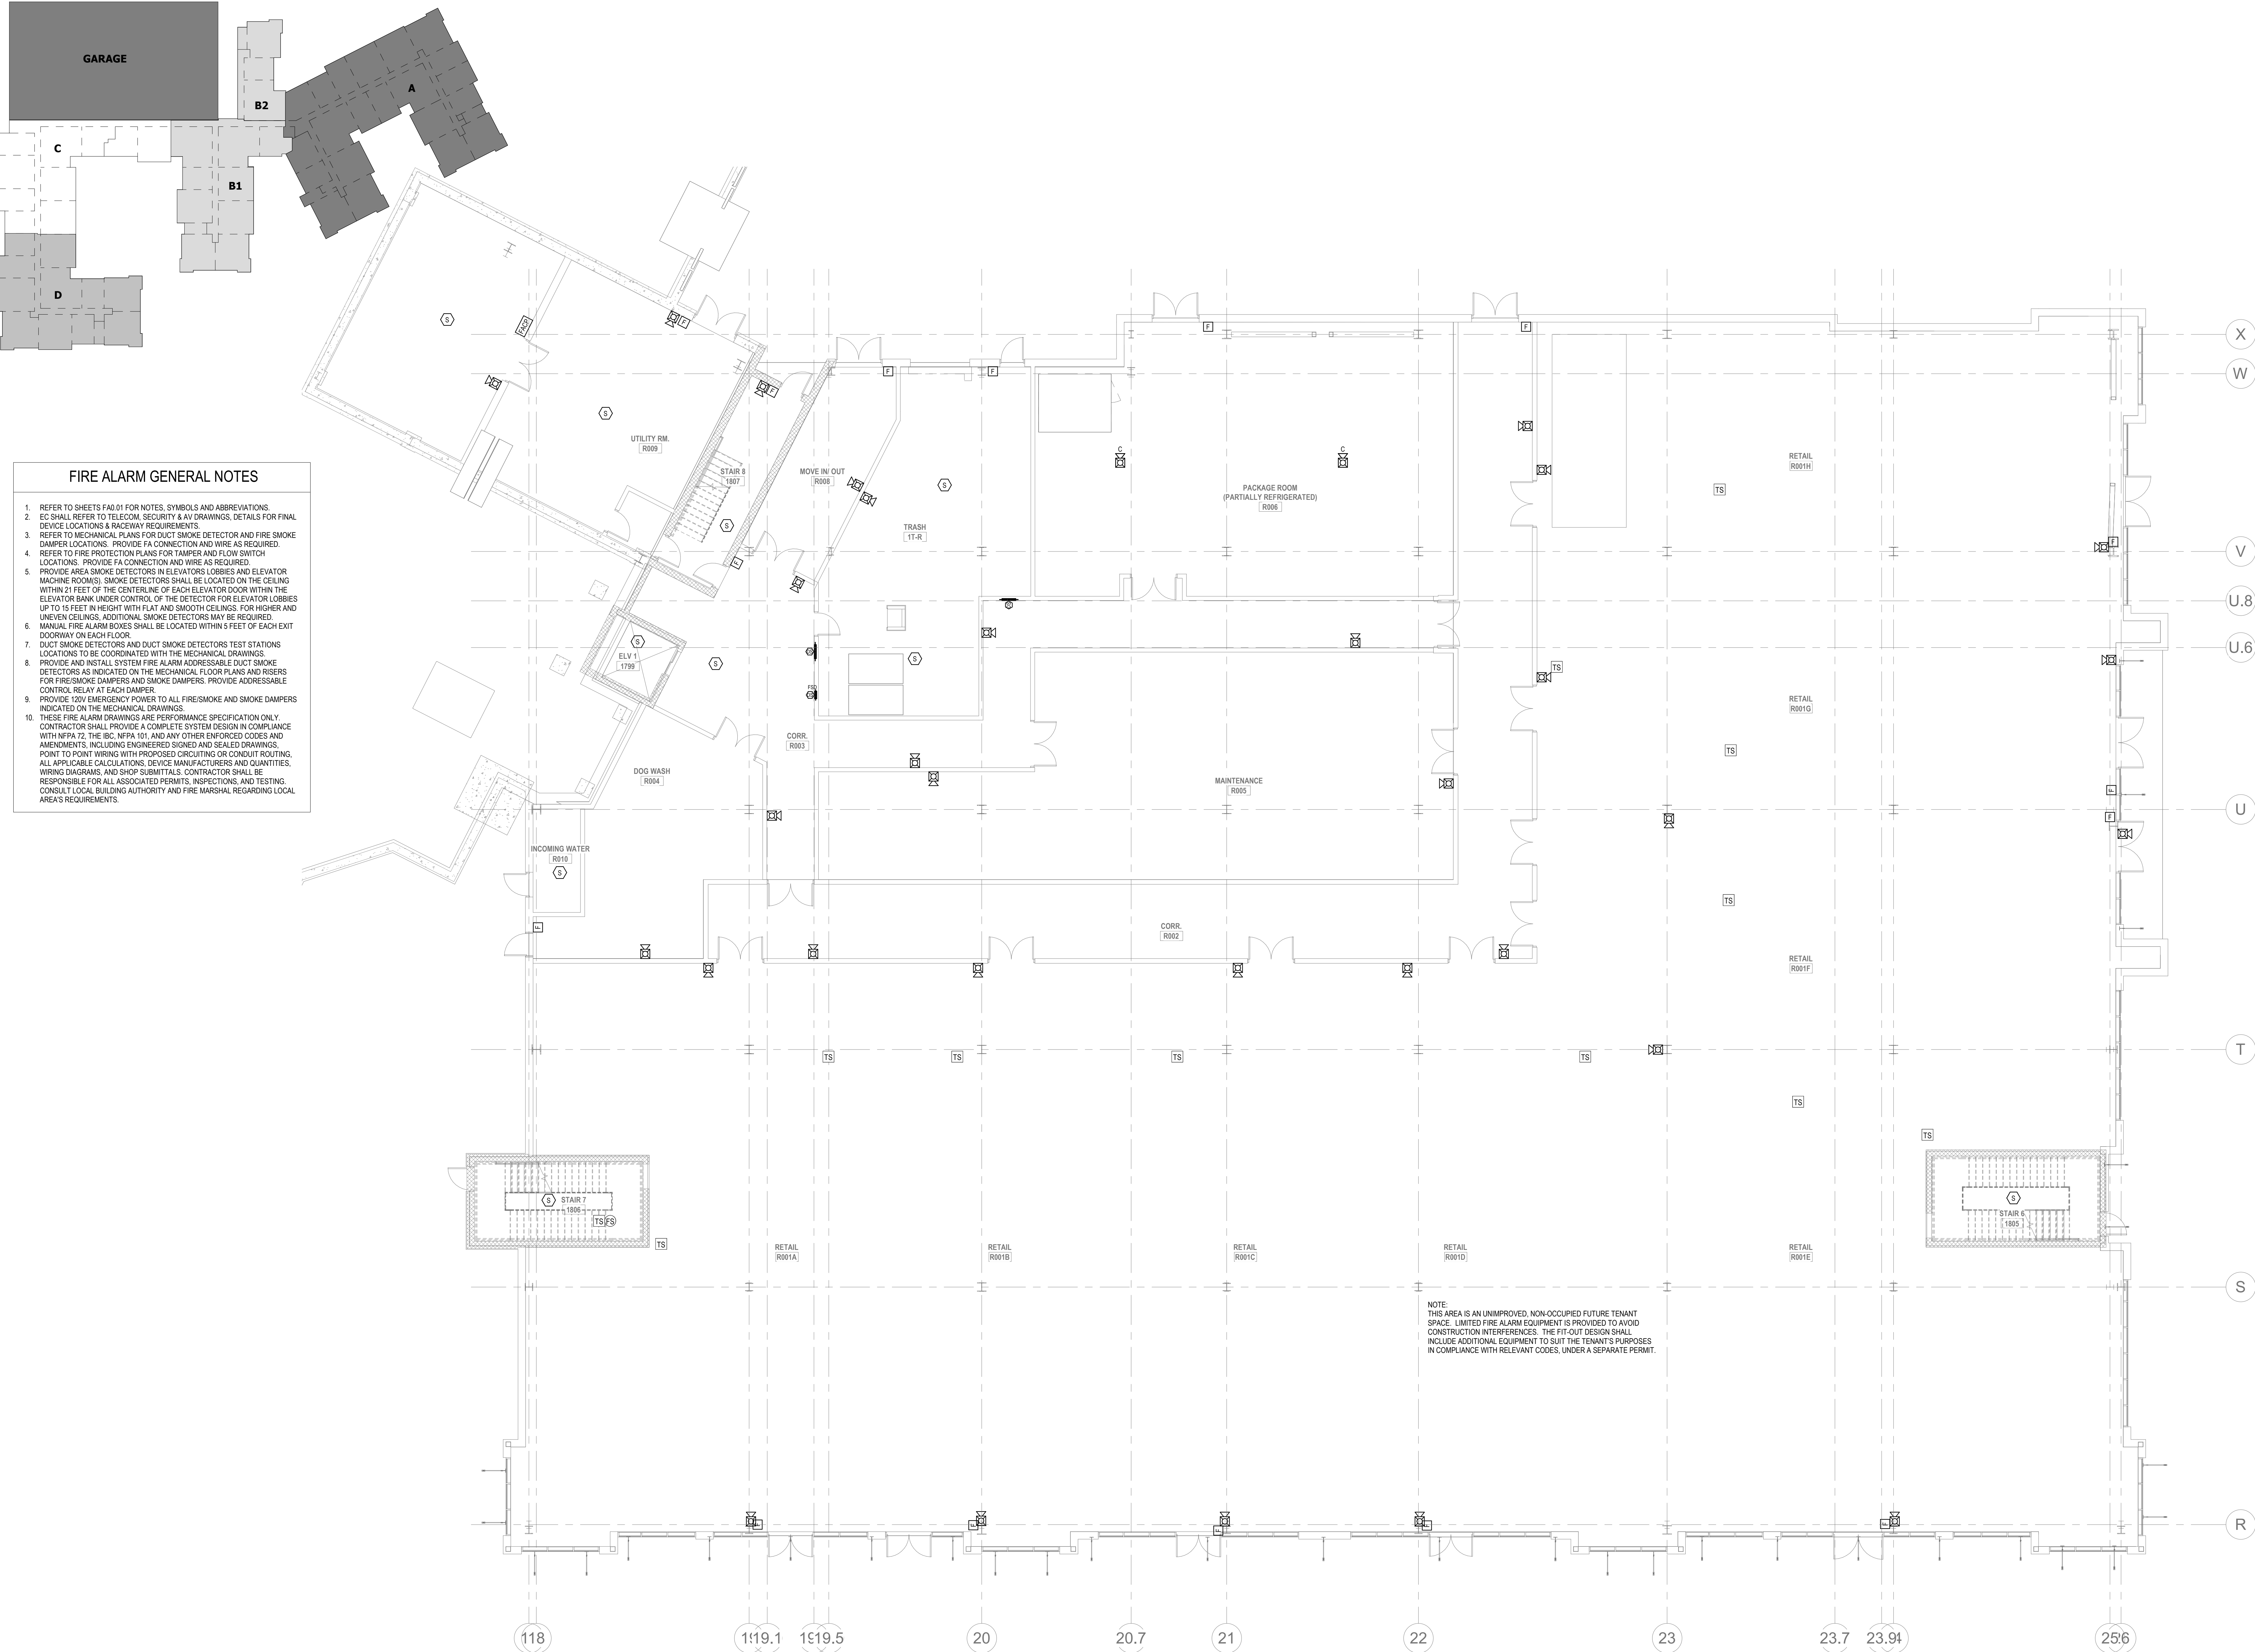

FIRE ALARM GENERAL NOTES

1. REFER TO SHEETS FA0.01 FOR NOTES, SYMBOLS AND ABBREVIATIONS.
2. EC SHALL REFER TO TELECOM, SECURITY & AV DRAWINGS, DETAILS FOR FINAL DEVICE LOCATIONS & RACEWAY REQUIREMENTS.
3. REFER TO MECHANICAL PLANS FOR DUCT SMOKE DETECTOR AND FIRE SMOKE DAMPER LOCATIONS. PROVIDE FA CONNECTION AND WIRE AS REQUIRED.
4. REFER TO FIRE PROTECTION PLANS FOR TAMPER AND FLOW SWITCH LOCATIONS. PROVIDE FA CONNECTION AND WIRE AS REQUIRED.
5. PROVIDE AREA SMOKE DETECTORS IN ELEVATORS LOBBIES AND ELEVATOR MACHINE ROOMS. SMOKE DETECTORS SHALL BE LOCATED ON THE CEILING WITHIN 21 FEET OF THE CENTERLINE OF EACH ELEVATOR DOOR WITHIN THE ELEVATOR BANK UNDER CONTROL OF THE DETECTOR FOR ELEVATOR LOBBIES UP TO 15 FEET IN HEIGHT WITH FLAT AND SMOOTH CEILINGS. FOR HIGHER AND UNEVEN CEILINGS, ADDITIONAL SMOKE DETECTORS MAY BE REQUIRED.
6. MANUAL FIRE ALARM BOXES SHALL BE LOCATED WITHIN 5 FEET OF EACH EXIT DOORWAY ON EACH FLOOR.
7. DUCT SMOKE DETECTORS AND DUCT SMOKE DETECTORS TEST STATIONS LOCATIONS TO BE COORDINATED WITH THE MECHANICAL DRAWINGS.
8. PROVIDE AND INSTALL SYSTEM FIRE ALARM ADDRESSABLE DUCT SMOKE DETECTORS AS INDICATED ON THE MECHANICAL FLOOR PLANS AND RISERS FOR FIRE/SMOKE DAMPERS AND SMOKE DAMPERS. PROVIDE ADDRESSABLE CONTROL RELAY AT EACH DAMPER.
9. PROVIDE 120V EMERGENCY POWER TO ALL FIRE/SMOKE AND SMOKE DAMPERS INDICATED ON THE MECHANICAL DRAWINGS.
10. THESE FIRE ALARM DRAWINGS ARE PERFORMANCE SPECIFICATION ONLY. CONTRACTOR SHALL PROVIDE A COMPLETE SYSTEM DESIGN IN COMPLIANCE WITH NFPA 72, THE IBC, NFPA 101, AND ANY OTHER ENFORCED CODES AND AMENDMENTS, INCLUDING ENGINEERED SIGNED AND SEALED DRAWINGS. POINT TO POINT WIRING WITH PROPOSED CIRCUITING OR CONDUIT ROUTING, ALL APPLICABLE CALCULATIONS, DEVICE MANUFACTURERS AND QUANTITIES, WIRING DIAGRAMS, AND SHOP SUBMITTALS. CONTRACTOR SHALL BE RESPONSIBLE FOR ALL ASSOCIATED PERMITS, INSPECTIONS, AND TESTING. CONSULT LOCAL BUILDING AUTHORITY AND FIRE MARSHAL REGARDING LOCAL AREA'S REQUIREMENTS.

NOTE:
THIS AREA IS AN UNIMPROVED, NON-OCCUPIED FUTURE TENANT SPACE. LIMITED FIRE ALARM EQUIPMENT IS PROVIDED TO AVOID CONSTRUCTION INTERFERENCES. THE FIT-OUT DESIGN SHALL INCLUDE ADDITIONAL EQUIPMENT TO SUIT THE TENANT'S PURPOSES IN COMPLIANCE WITH RELEVANT CODES, UNDER A SEPARATE PERMIT.

1 FIRE ALARM - RETAIL LEVEL PLAN A
FA2.01A 1/8" = 1'-0"

ALL REPORTS, PLANS, SPECIFICATIONS AND COMPUTER FILES RELATING TO THIS PROJECT ARE THE PROPERTY OF THE MARTIN ARCHITECTURAL GROUP. THE MARTIN ARCHITECTURAL GROUP RETAINS ALL COMMON LAW, STATUTE AND OTHER RESERVED RIGHTS INCLUDING THE COPY RIGHT THEREIN. REPRODUCTION OF THE MATERIAL HEREIN OR SUBSTANTIAL USE WITHOUT WRITTEN PERMISSION OF THE MARTIN ARCHITECTURAL GROUP VIOLATES THE COPYRIGHT LAWS OF THE UNITED STATES AND WILL BE SUBJECT TO LEGAL PROSECUTION.
© The Martin Architectural Group, P.C.



THE MARTIN ARCHITECTURAL GROUP, P.C.
ARCHITECTS AND LAND PLANNERS
A PROFESSIONAL CORPORATION
240 NORTH 22ND STREET, PHILADELPHIA, PA, 19103
P (215) 665-1060 F (215) 561-5064

P.A.: JTG
P.M.: TRT
DRAWN BY: Author
PROJECT NO: 1022747

NO.	REVISION	DATE
1	SEPARATE BUDGET PRICING SET	11/01/2022
1	PERMIT SET	12/20/2022


Project Status

FIRE ALARM - RETAIL LEVEL PLAN A
Granite Run Apartments

SCALE: AS INDICATED
DATE: 11/01/22


FA2.01A
© The Martin Architectural Group, P.C.

Printed: 1/13/2023 12:04:01 PM

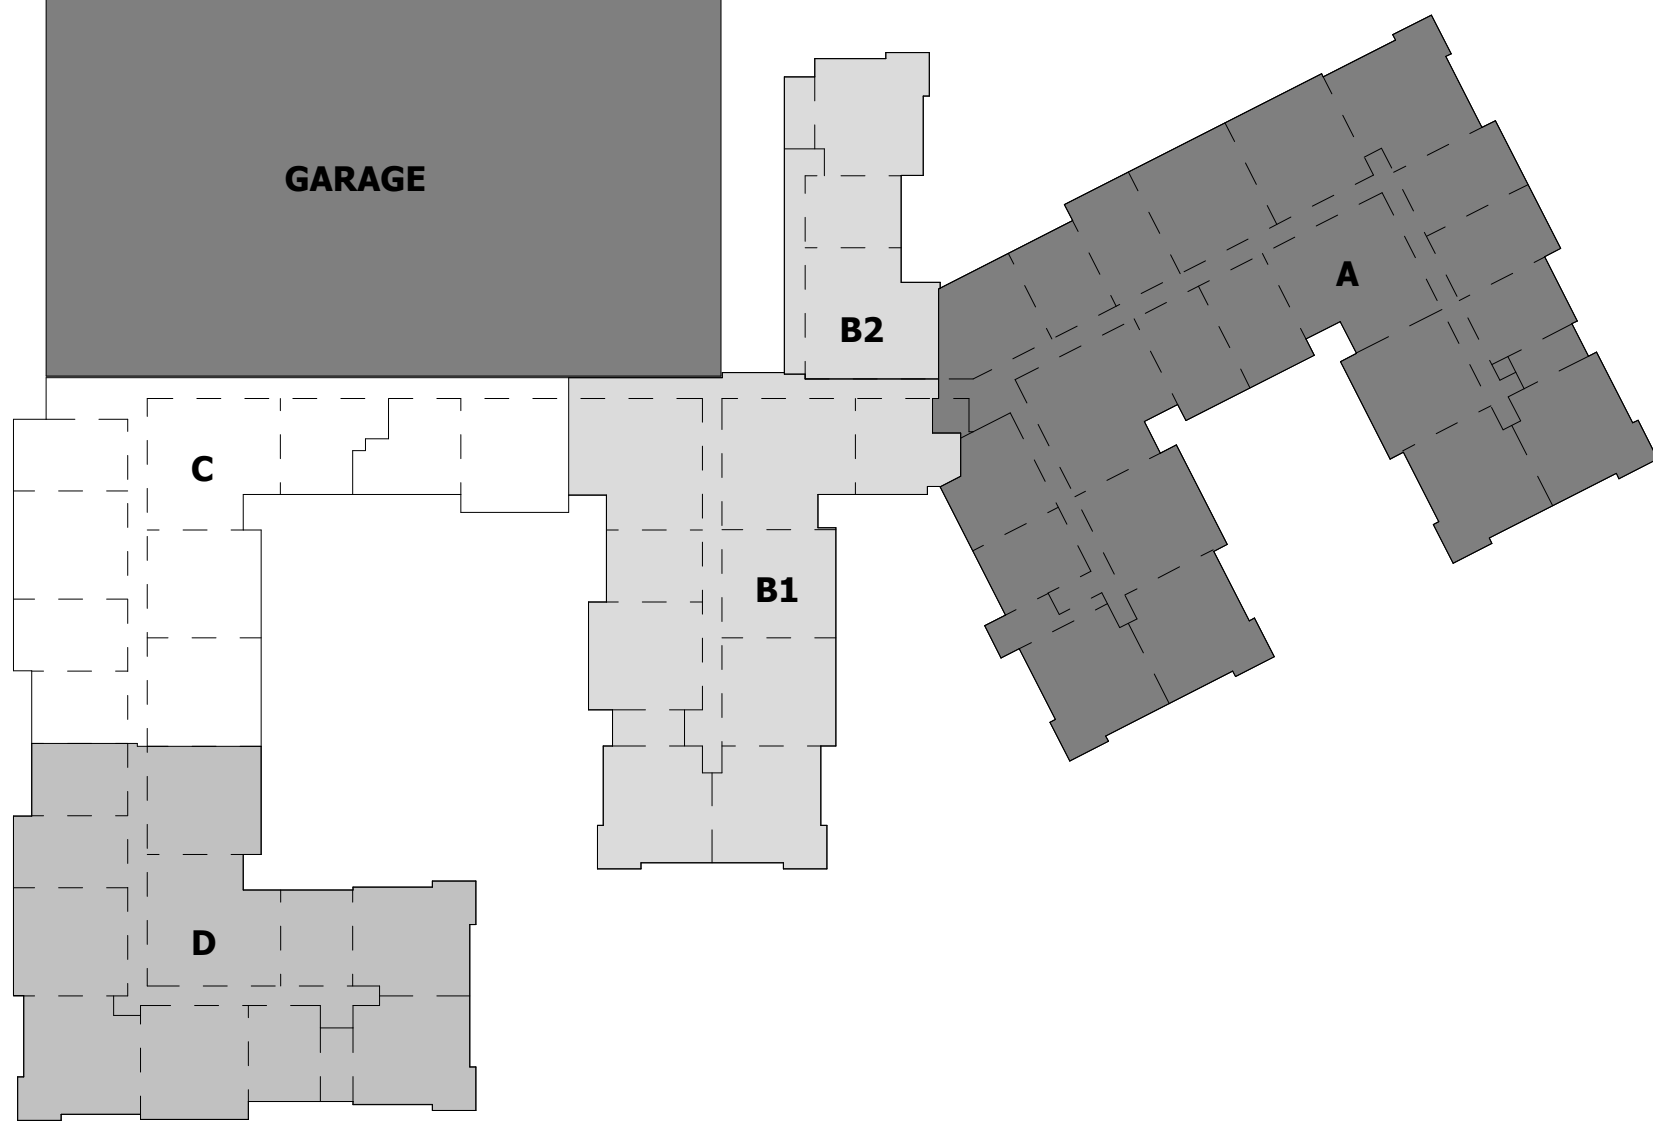


FIRE ALARM GENERAL NOTES

1. REFER TO SHEETS FA0.01 FOR NOTES, SYMBOLS AND ABBREVIATIONS.
2. EC SHALL REFER TO TELECOM, SECURITY & AV DRAWINGS, DETAILS FOR FINAL DEVICE LOCATIONS & RACEWAY REQUIREMENTS.
3. REFER TO MECHANICAL PLANS FOR DUCT SMOKE DETECTOR AND FIRE SMOKE DAMPER LOCATIONS. PROVIDE FA CONNECTION AND WIRE AS REQUIRED.
4. REFER TO FIRE PROTECTION PLANS FOR TAMPER AND FLOW SWITCH LOCATIONS. PROVIDE FA CONNECTION AND WIRE AS REQUIRED.
5. PROVIDE AREA SMOKE DETECTORS IN ELEVATOR LOBBIES AND ELEVATOR MACHINE ROOMS. SMOKE DETECTORS SHALL BE LOCATED ON THE CEILING WITHIN 21 FEET OF THE CENTERLINE OF EACH ELEVATOR DOOR WITHIN THE ELEVATOR BANK UNDER CONTROL OF THE DETECTOR FOR ELEVATOR LOBBIES UP TO 15 FEET IN HEIGHT WITH FLAT AND SMOOTH CEILINGS. FOR HIGHER AND UNEVEN CEILINGS, ADDITIONAL SMOKE DETECTORS MAY BE REQUIRED.
6. MANUAL FIRE ALARM BOXES SHALL BE LOCATED WITHIN 5 FEET OF EACH EXIT DOORWAY ON EACH FLOOR.
7. DUCT SMOKE DETECTORS AND DUCT SMOKE DETECTORS TEST STATIONS LOCATIONS TO BE COORDINATED WITH THE MECHANICAL DRAWINGS.
8. PROVIDE AND INSTALL SYSTEM FIRE ALARM ADDRESSABLE DUCT SMOKE DETECTORS AS INDICATED ON THE MECHANICAL FLOOR PLANS AND RISERS FOR FIRE/SMOKE DAMPERS AND SMOKE DAMPERS. PROVIDE ADDRESSABLE CONTROL RELAY AT EACH DAMPER.
9. PROVIDE 120V EMERGENCY POWER TO ALL FIRE/SMOKE AND SMOKE DAMPERS INDICATED ON THE MECHANICAL DRAWINGS.
10. THESE FIRE ALARM DRAWINGS ARE PERFORMANCE SPECIFICATION ONLY. CONTRACTOR SHALL PROVIDE A COMPLETE SYSTEM DESIGN IN COMPLIANCE WITH NFPA 72, THE IBC, NFPA 101, AND ANY OTHER ENFORCED CODES AND AMENDMENTS, INCLUDING ENGINEERED SIGNED AND SEALED DRAWINGS. POINT TO POINT WIRING WITH PROPOSED CIRCUITING OR CONDUIT ROUTING, ALL APPLICABLE CALCULATIONS, DEVICE MANUFACTURERS AND QUANTITIES, WIRING DIAGRAMS, AND SHOP SUBMITTALS. CONTRACTOR SHALL BE RESPONSIBLE FOR ALL ASSOCIATED PERMITS, INSPECTIONS, AND TESTING. CONSULT LOCAL BUILDING AUTHORITY AND FIRE MARSHAL REGARDING LOCAL AREA'S REQUIREMENTS.
11. CLUB LEVEL 1 AND CLUB LEVEL 2 SHALL BE DESIGN AS PART OF A FUTURE PERMIT ISSUANCE.

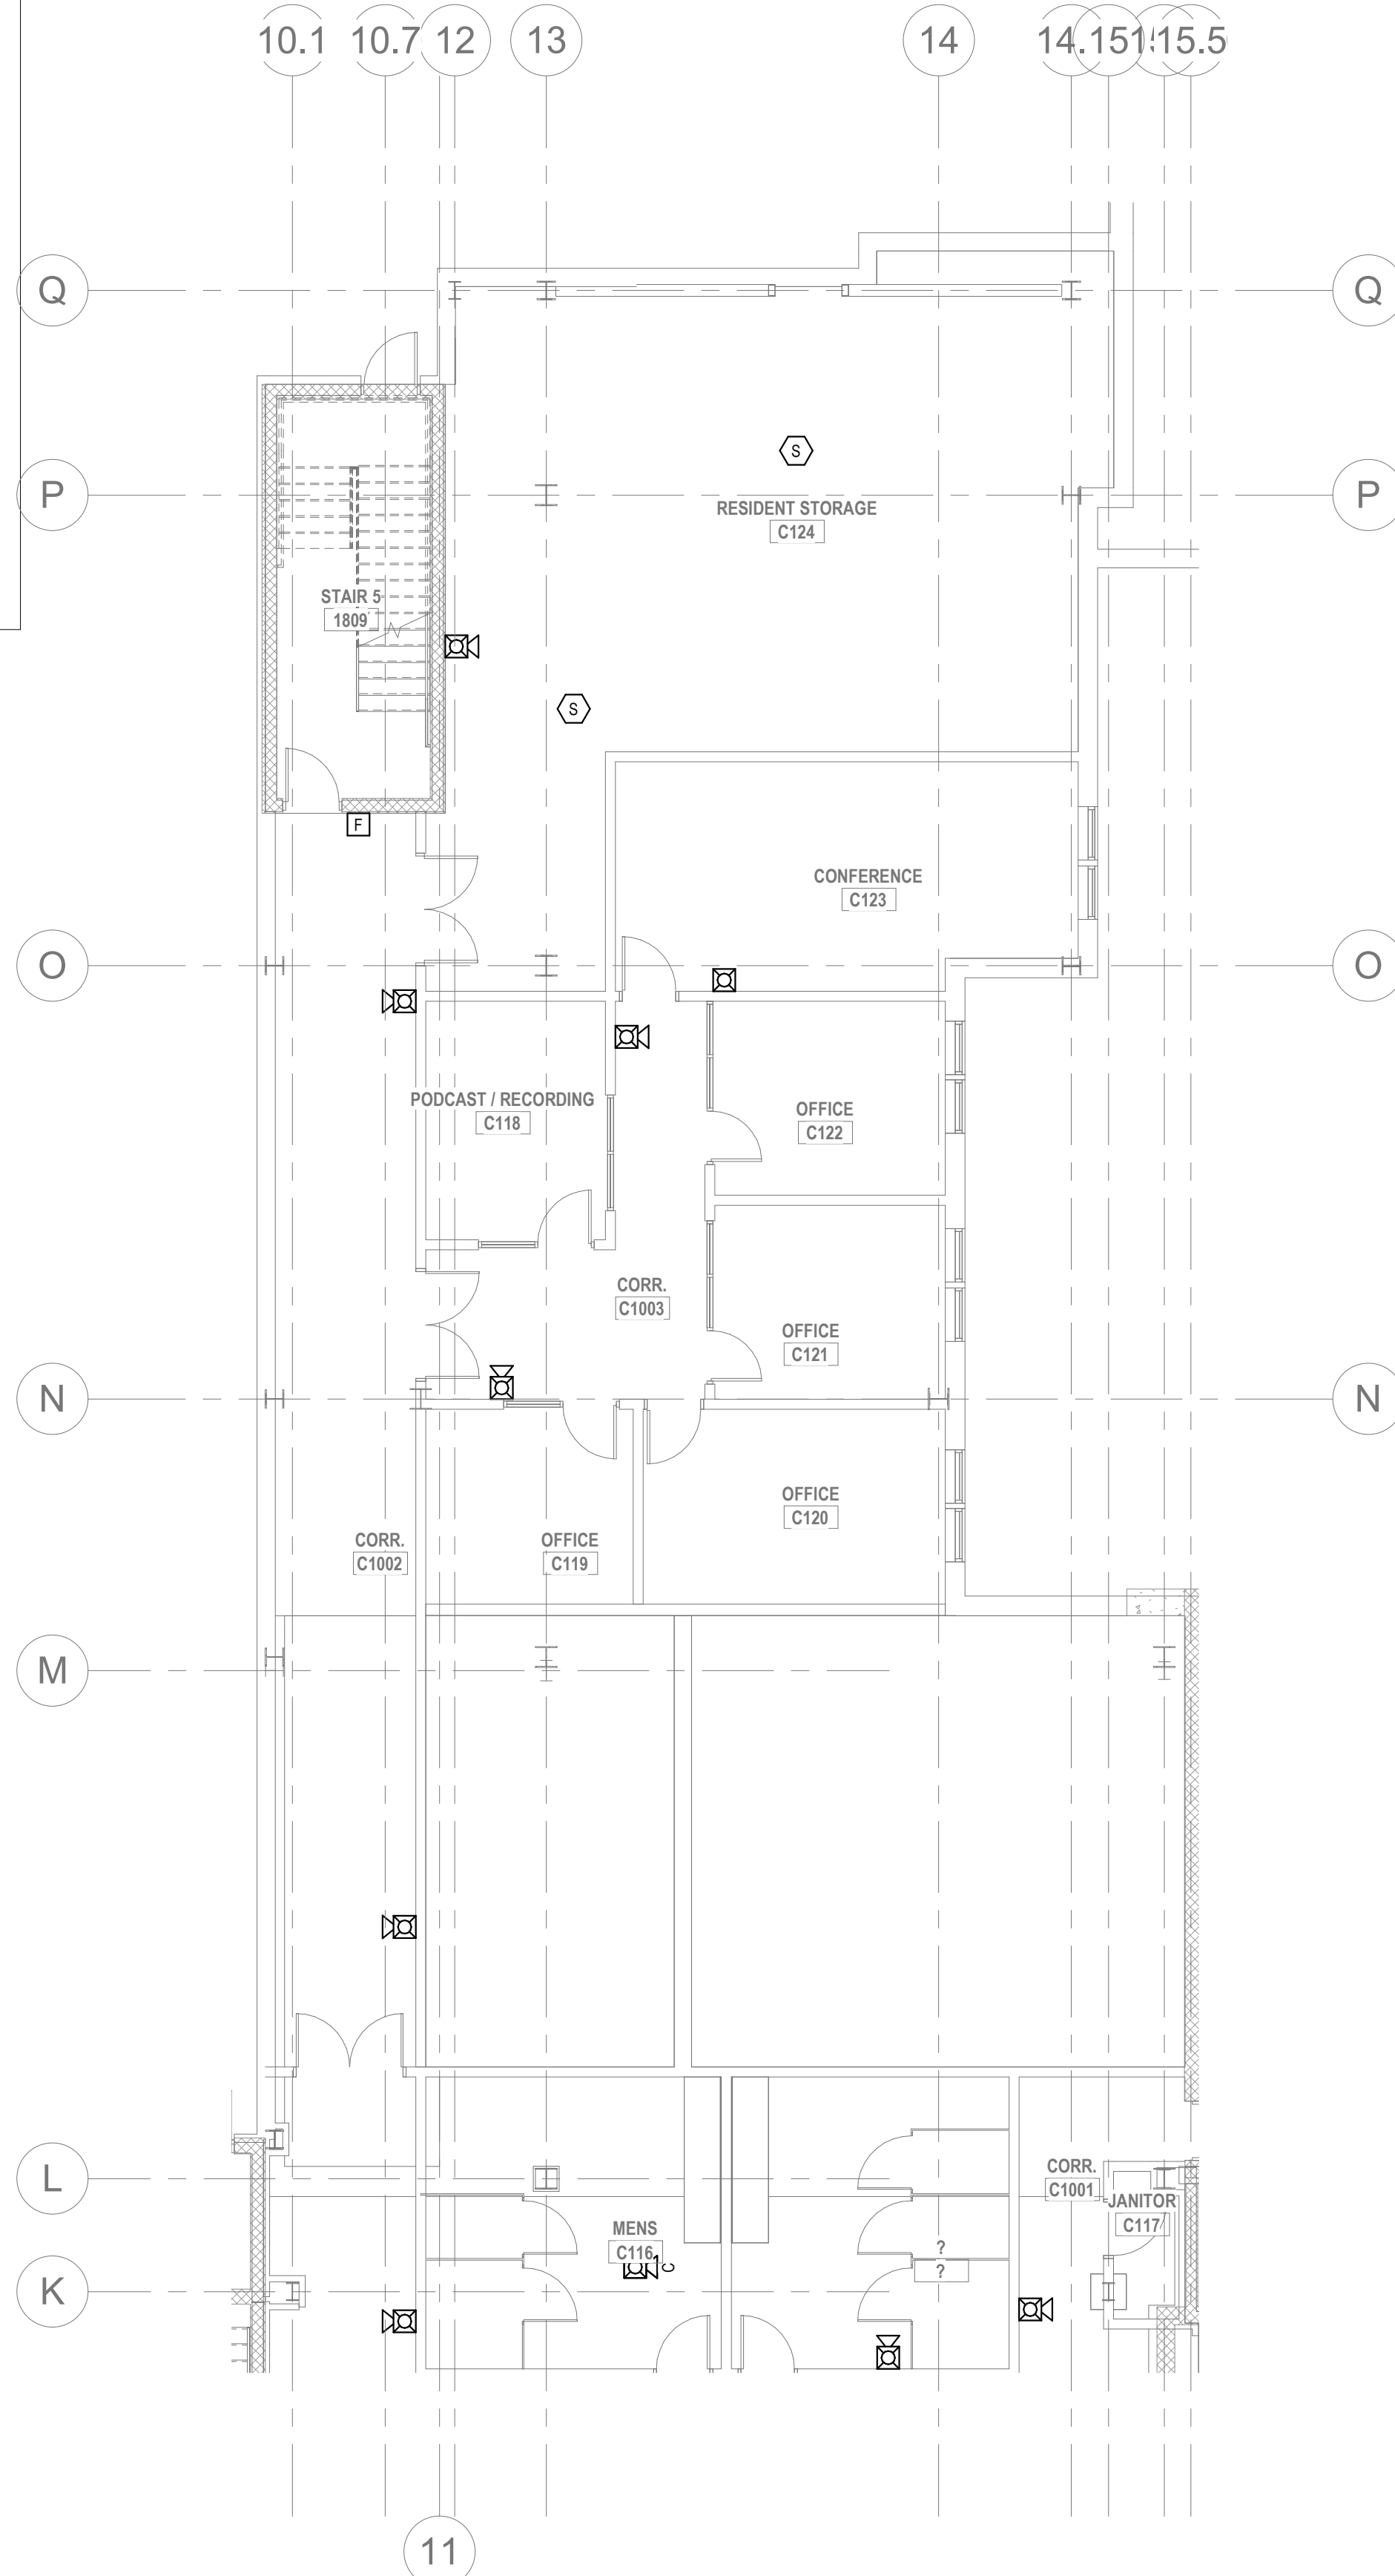

1 FIRE ALARM - CLUB LEVEL 1 PLAN B2
1/8" = 1'-0"

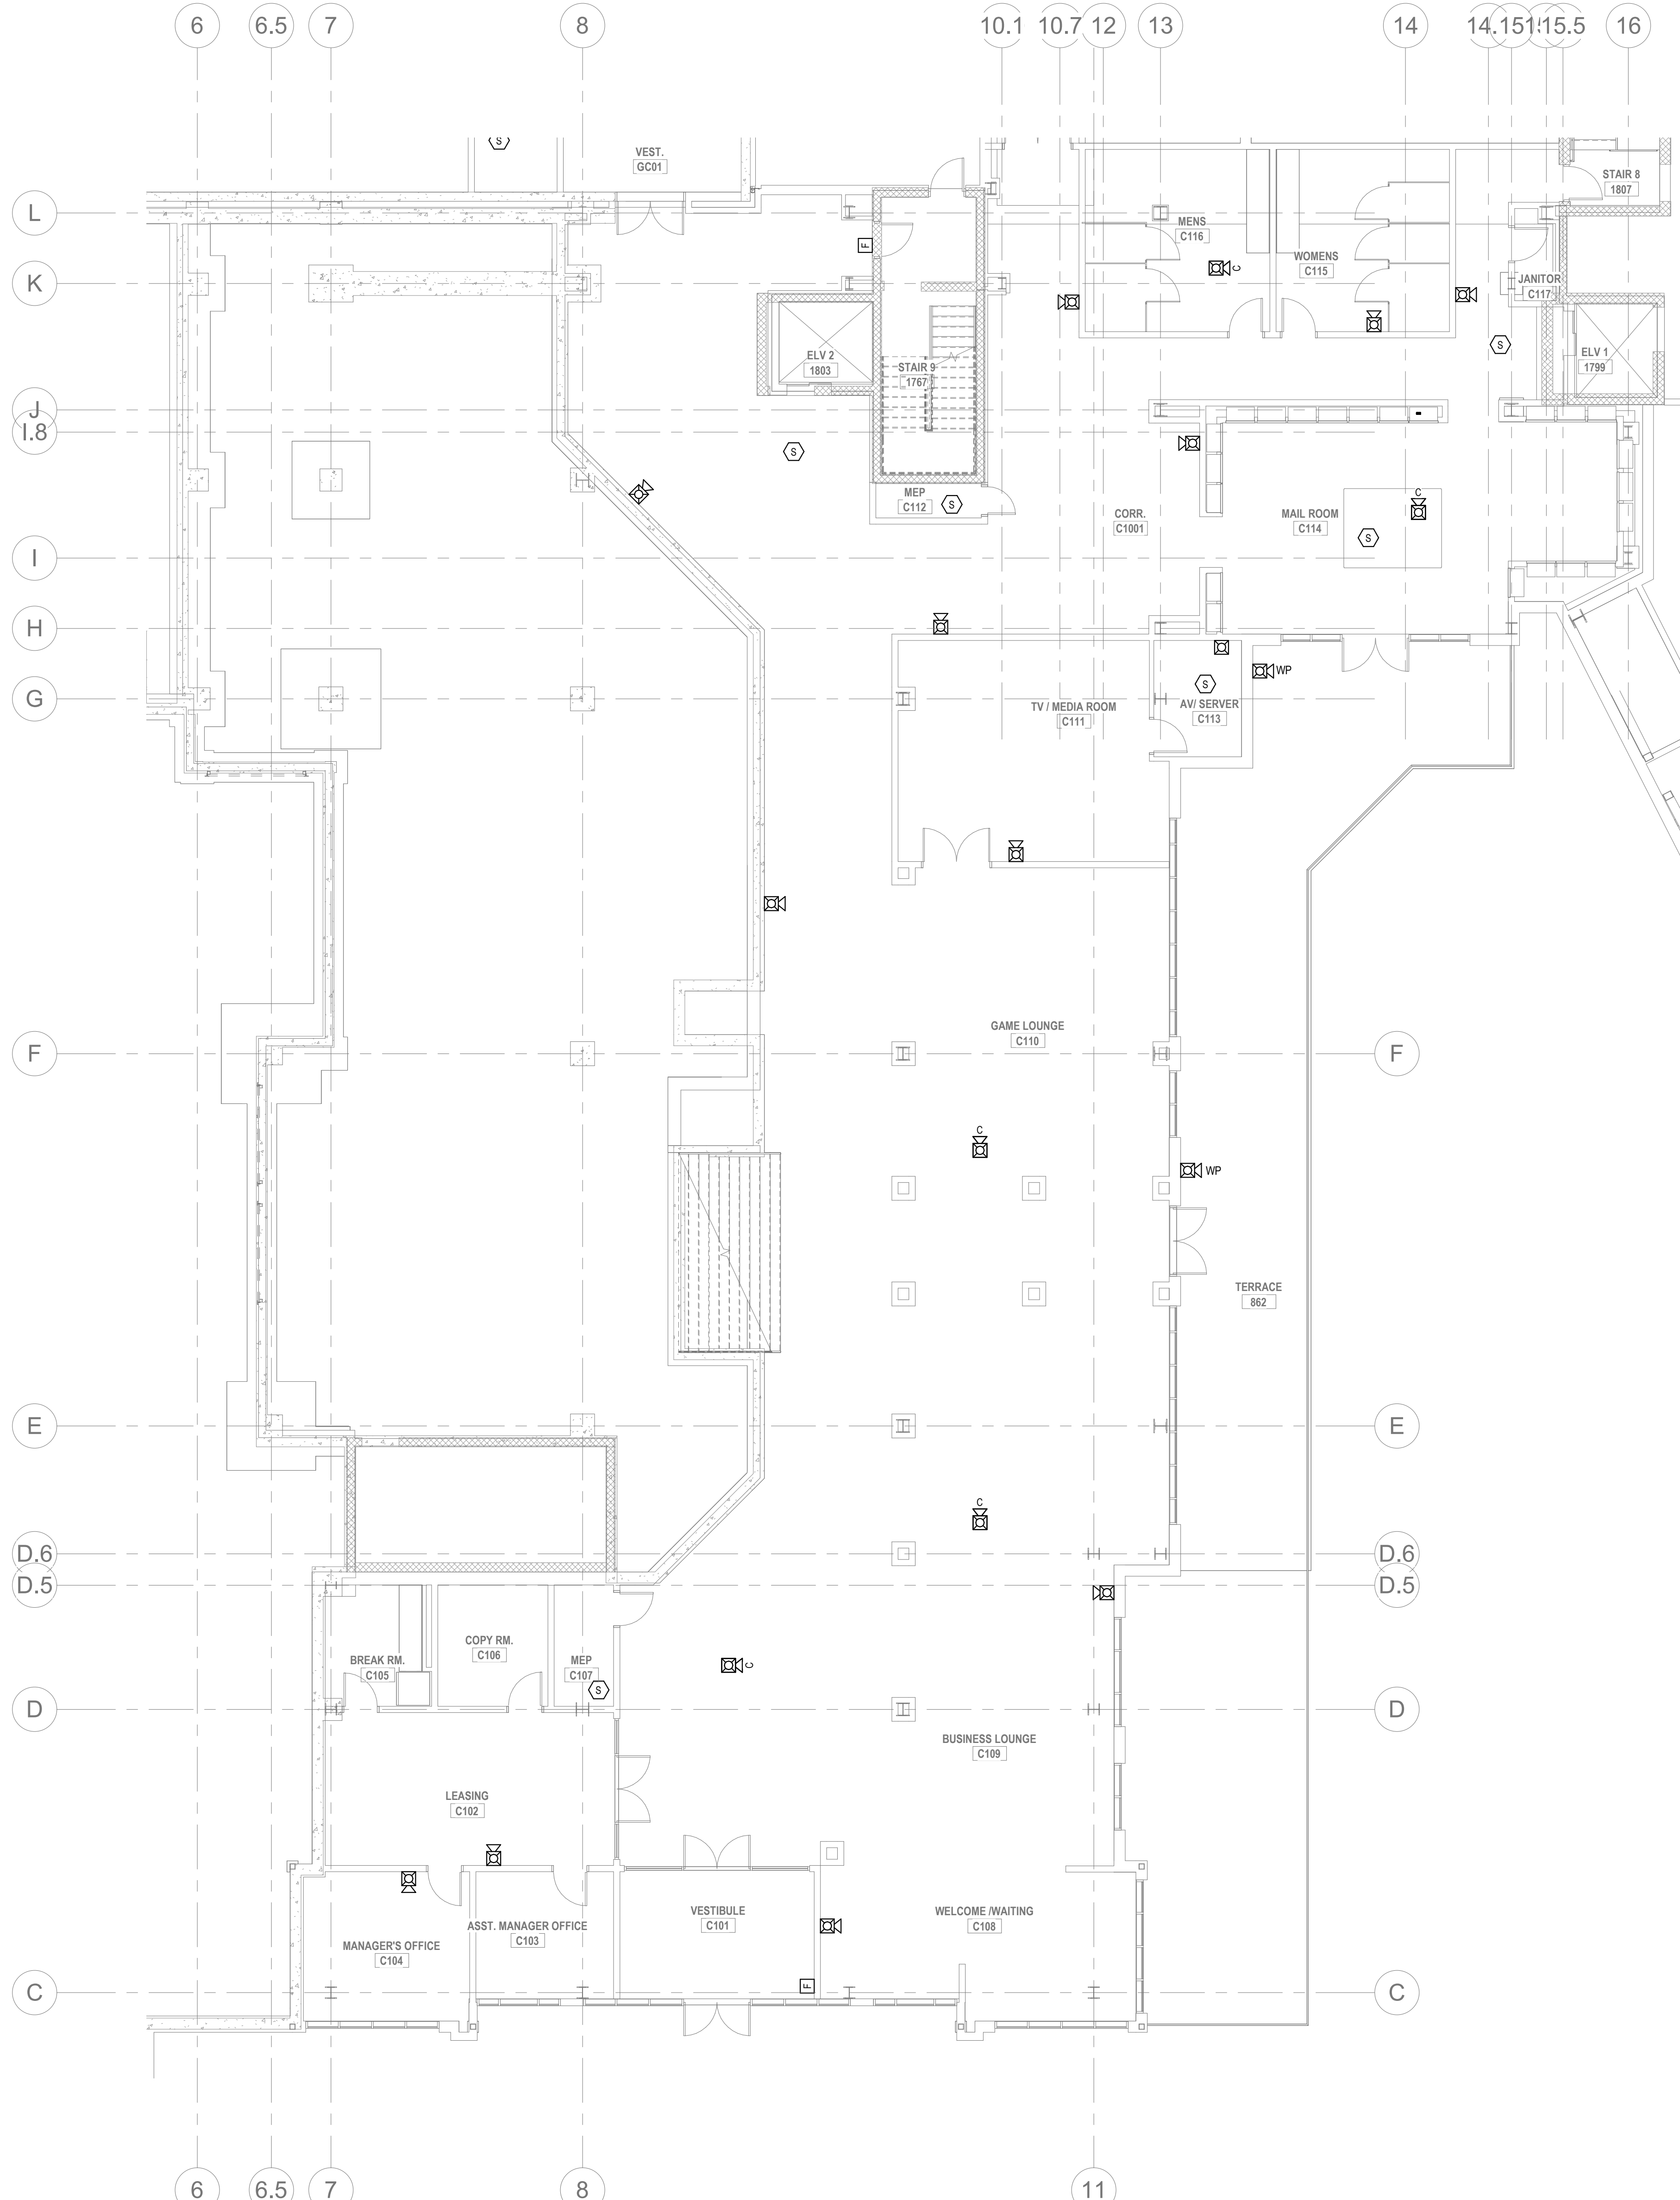

2 FIRE ALARM - CLUB LEVEL 1 PLAN B1
1/8" = 1'-0"

ALL REPORTS, PLANS, SPECIFICATIONS AND COMPUTER FILES RELATING TO THIS PROJECT ARE THE PROPERTY OF THE MARTIN ARCHITECTURAL GROUP. THE MARTIN ARCHITECTURAL GROUP RETAINS ALL COMMON LAW, STATUTE AND OTHER RESERVED RIGHTS INCLUDING THE COPY RIGHT THEREIN. REPRODUCTION OF THE MATERIAL HEREIN OR SUBSTANTIAL USE WITHOUT WRITTEN PERMISSION OF THE MARTIN ARCHITECTURAL GROUP VIOLATES THE COPYRIGHT LAWS OF THE UNITED STATES AND WILL BE SUBJECT TO LEGAL PROSECUTION.
© The Martin Architectural Group, P.C.



THE MARTIN ARCHITECTURAL GROUP, P.C.
ARCHITECTS AND LAND PLANNERS
A PROFESSIONAL CORPORATION
240 NORTH 22ND STREET, PHILADELPHIA, PA 19103
P (215) 665-1060 F (215) 561-5064

P.A.: JTG
P.M.: TRT
DRAWN BY: Author
PROJECT NO: 1022747

NO.	REVISION	DATE
1	SCHEMATIC BUDGET PRICING SET	11/01/2022
1	PERMIT SET	12/20/2022

Project Status


FIRE ALARM - CLUB LEVEL 1 PLAN B
Granite Run Apartments

MIDDLETOWN TOWNSHIP, PA

SCALE: AS INDICATED
DATE: 11/01/22


FA2.02B
© The Martin Architectural Group, P.C.

Printed: 1/13/2023 12:04:06 PM

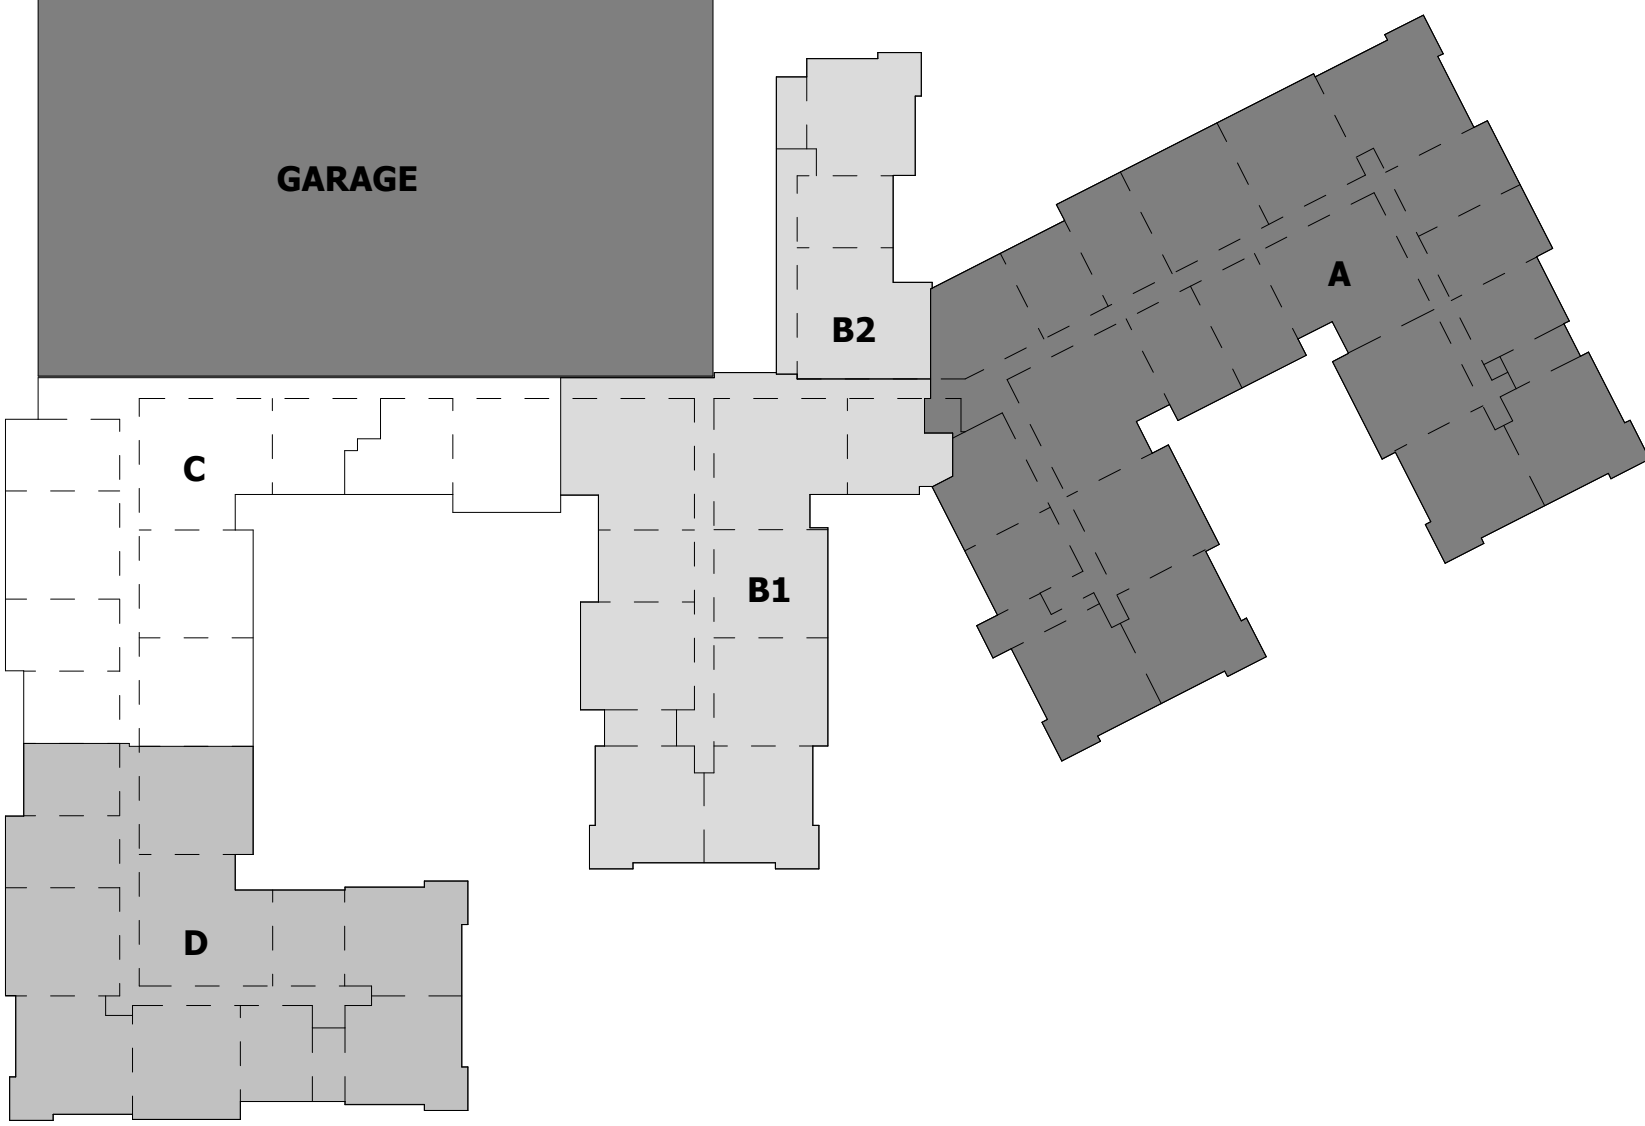


FIRE ALARM GENERAL NOTES

1. REFER TO SHEETS FA0.01 FOR NOTES, SYMBOLS AND ABBREVIATIONS.
2. EC SHALL REFER TO TELECOM, SECURITY & AV DRAWINGS, DETAILS FOR FINAL DEVICE LOCATIONS & RACEWAY REQUIREMENTS.
3. REFER TO MECHANICAL PLANS FOR DUCT SMOKE DETECTOR AND FIRE SMOKE DAMPER LOCATIONS. PROVIDE FA CONNECTION AND WIRE AS REQUIRED.
4. REFER TO FIRE PROTECTION PLANS FOR TAMPER AND FLOW SWITCH LOCATIONS. PROVIDE FA CONNECTION AND WIRE AS REQUIRED.
5. PROVIDE AREA SMOKE DETECTORS IN ELEVATOR LOBBIES AND ELEVATOR MACHINE ROOMS. SMOKE DETECTORS SHALL BE LOCATED ON THE CEILING WITHIN 21 FEET OF THE CENTERLINE OF EACH ELEVATOR DOOR WITHIN THE ELEVATOR BANK UNDER CONTROL OF THE DETECTOR FOR ELEVATOR LOBBIES UP TO 15 FEET IN HEIGHT WITH FLAT AND SMOOTH CEILINGS. FOR HIGHER AND UNEVEN CEILINGS, ADDITIONAL SMOKE DETECTORS MAY BE REQUIRED.
6. MANUAL FIRE ALARM BOXES SHALL BE LOCATED WITHIN 5 FEET OF EACH EXIT DOORWAY ON EACH FLOOR.
7. DUCT SMOKE DETECTORS AND DUCT SMOKE DETECTORS TEST STATIONS LOCATIONS TO BE COORDINATED WITH THE MECHANICAL DRAWINGS.
8. PROVIDE AND INSTALL SYSTEM FIRE ALARM ADDRESSABLE DUCT SMOKE DETECTORS AS INDICATED ON THE MECHANICAL FLOOR PLANS AND RISERS FOR FIRE/SMOKE DAMPERS AND SMOKE DAMPERS. PROVIDE ADDRESSABLE CONTROL RELAY AT EACH DAMPER.
9. PROVIDE 120V EMERGENCY POWER TO ALL FIRE/SMOKE AND SMOKE DAMPERS INDICATED ON THE MECHANICAL DRAWINGS.
10. THESE FIRE ALARM DRAWINGS ARE PERFORMANCE SPECIFICATION ONLY. CONTRACTOR SHALL PROVIDE A COMPLETE SYSTEM DESIGN IN COMPLIANCE WITH NFPA 72, THE IBC, NFPA 101, AND ANY OTHER ENFORCED CODES AND AMENDMENTS, INCLUDING ENGINEERED SIGNED AND SEALED DRAWINGS. POINT TO POINT WIRING WITH PROPOSED CIRCUITING OR CONDUIT ROUTING. ALL APPLICABLE CALCULATIONS, DEVICE MANUFACTURERS AND QUANTITIES, WIRING DIAGRAMS, AND SHOP SUBMITTALS. CONTRACTOR SHALL BE RESPONSIBLE FOR ALL ASSOCIATED PERMITS, INSPECTIONS, AND TESTING. CONSULT LOCAL BUILDING AUTHORITY AND FIRE MARSHAL REGARDING LOCAL AREA'S REQUIREMENTS.
11. CLUB LEVEL 1 AND CLUB LEVEL 2 SHALL BE DESIGN AS PART OF A FUTURE PERMIT ISSUANCE.

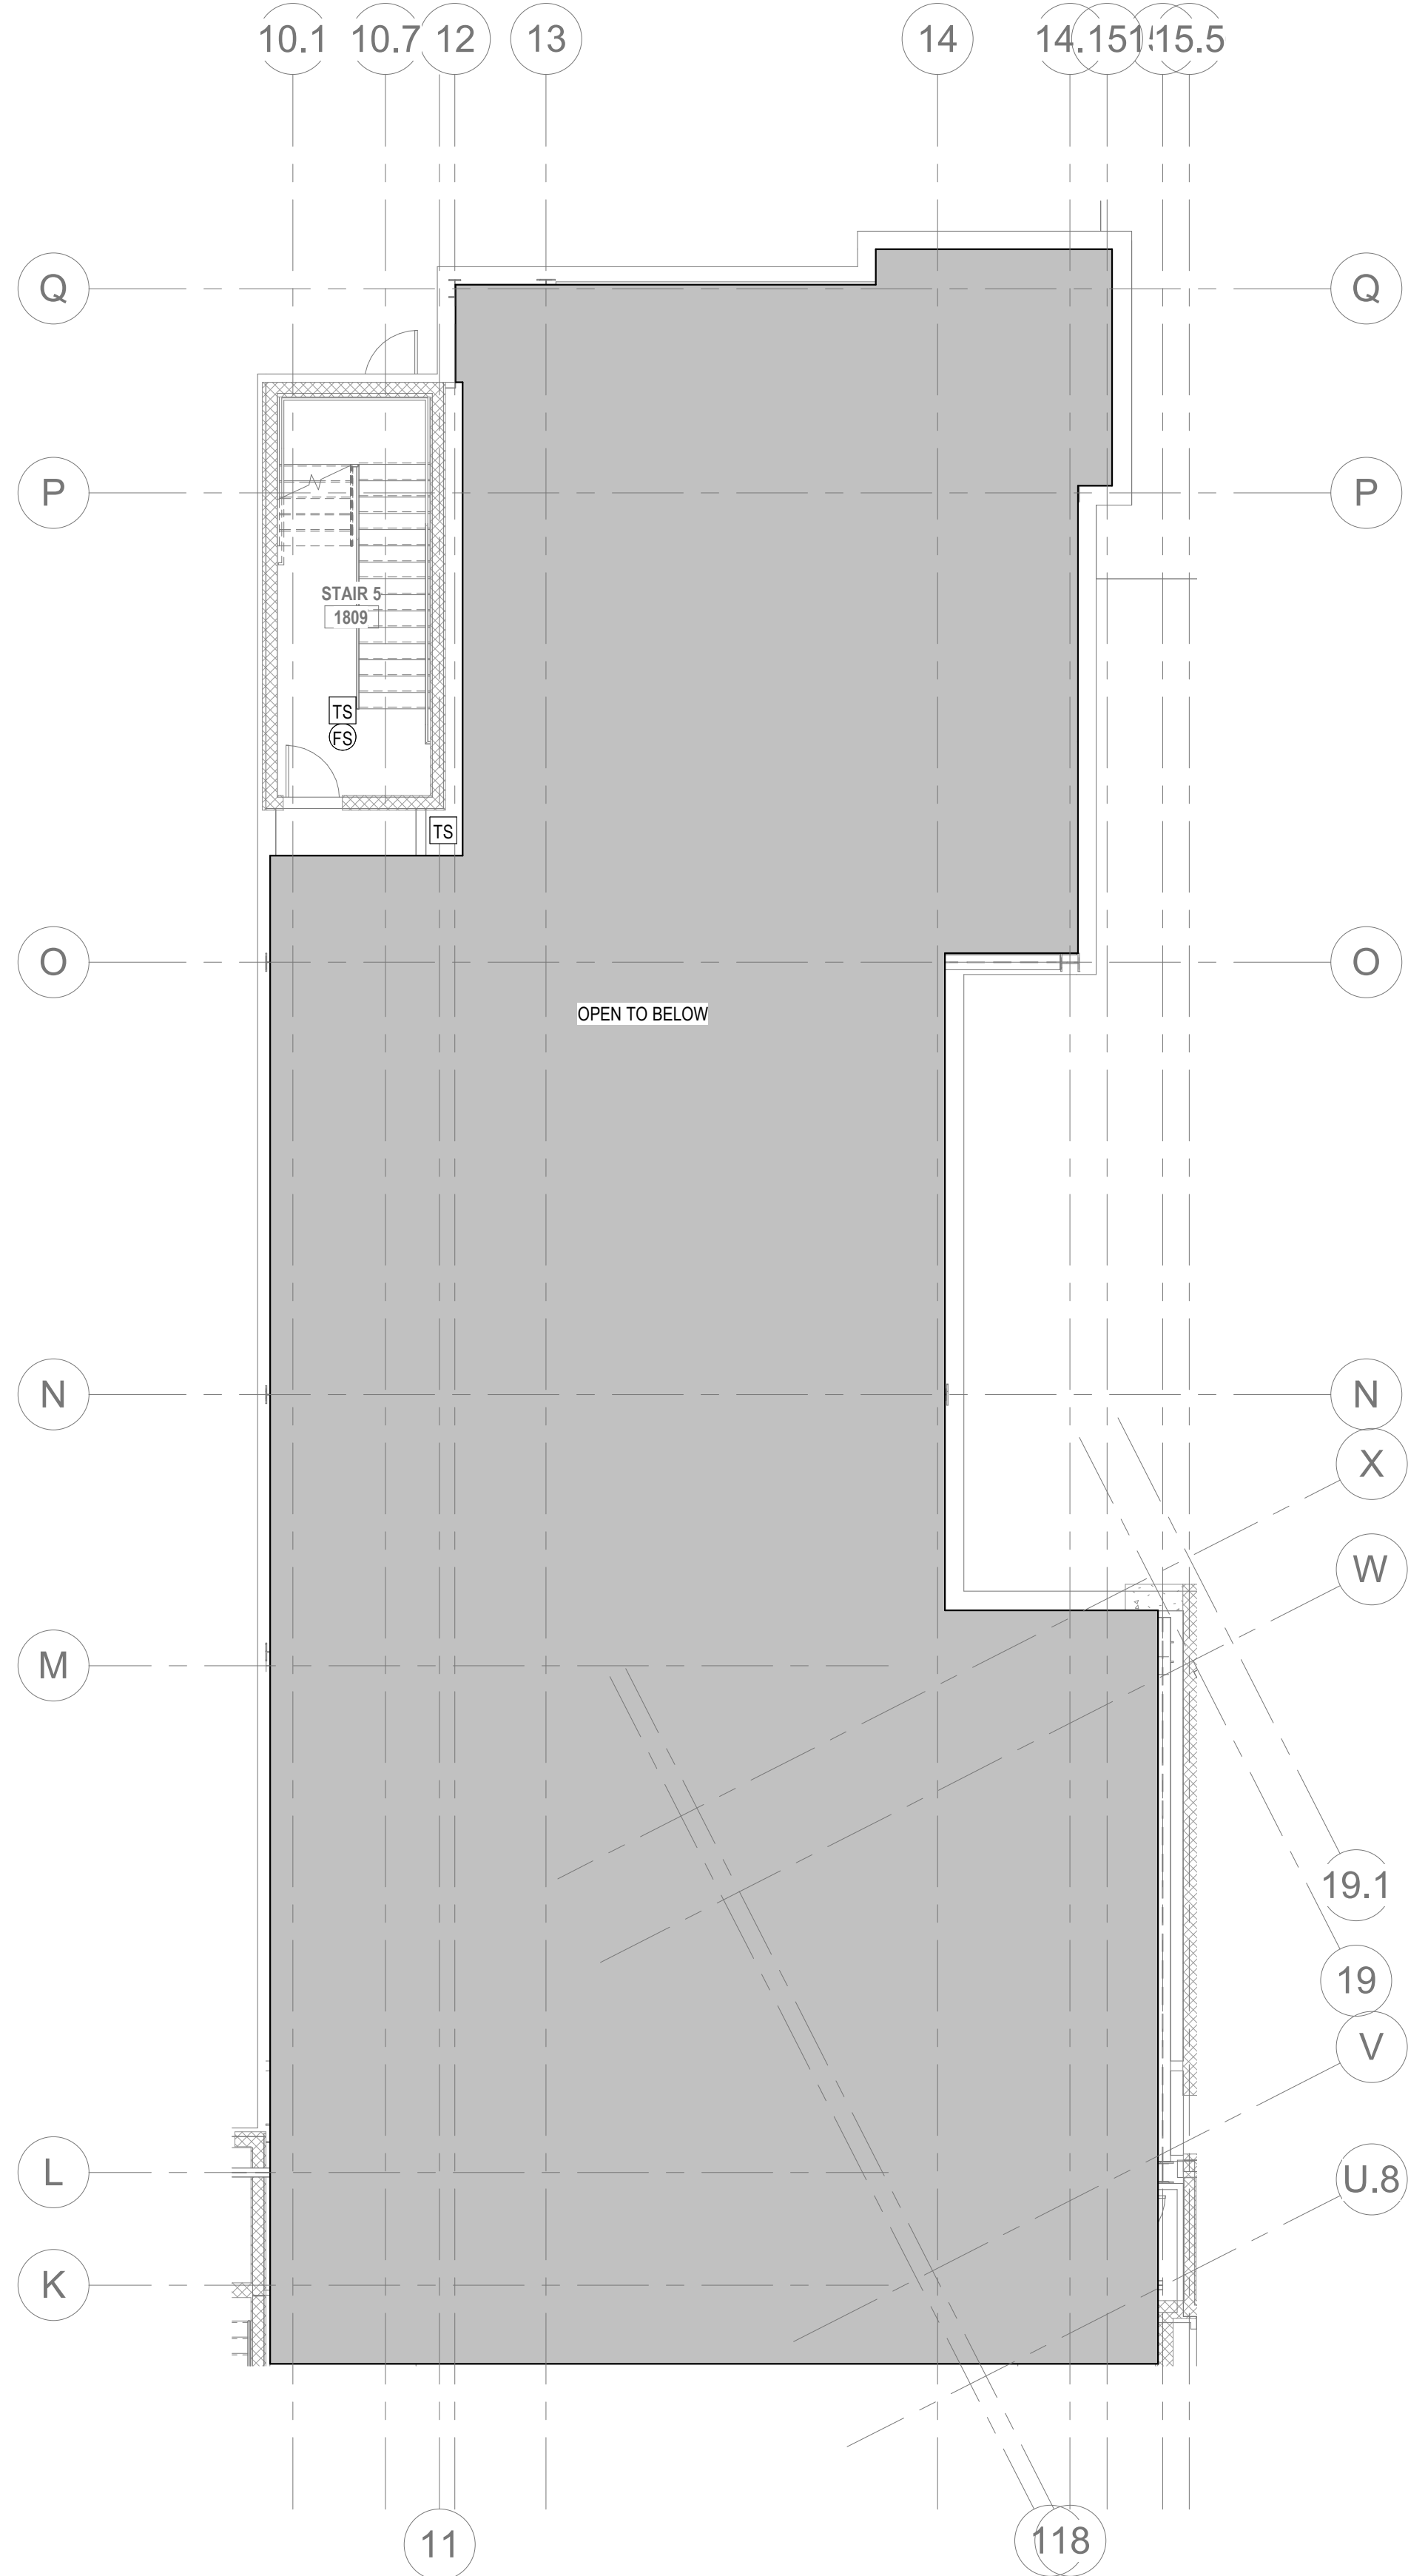


1 FIRE ALARM - CLUB LEVEL 2 PLAN B2
FA2.03B 1/8" = 1'-0"

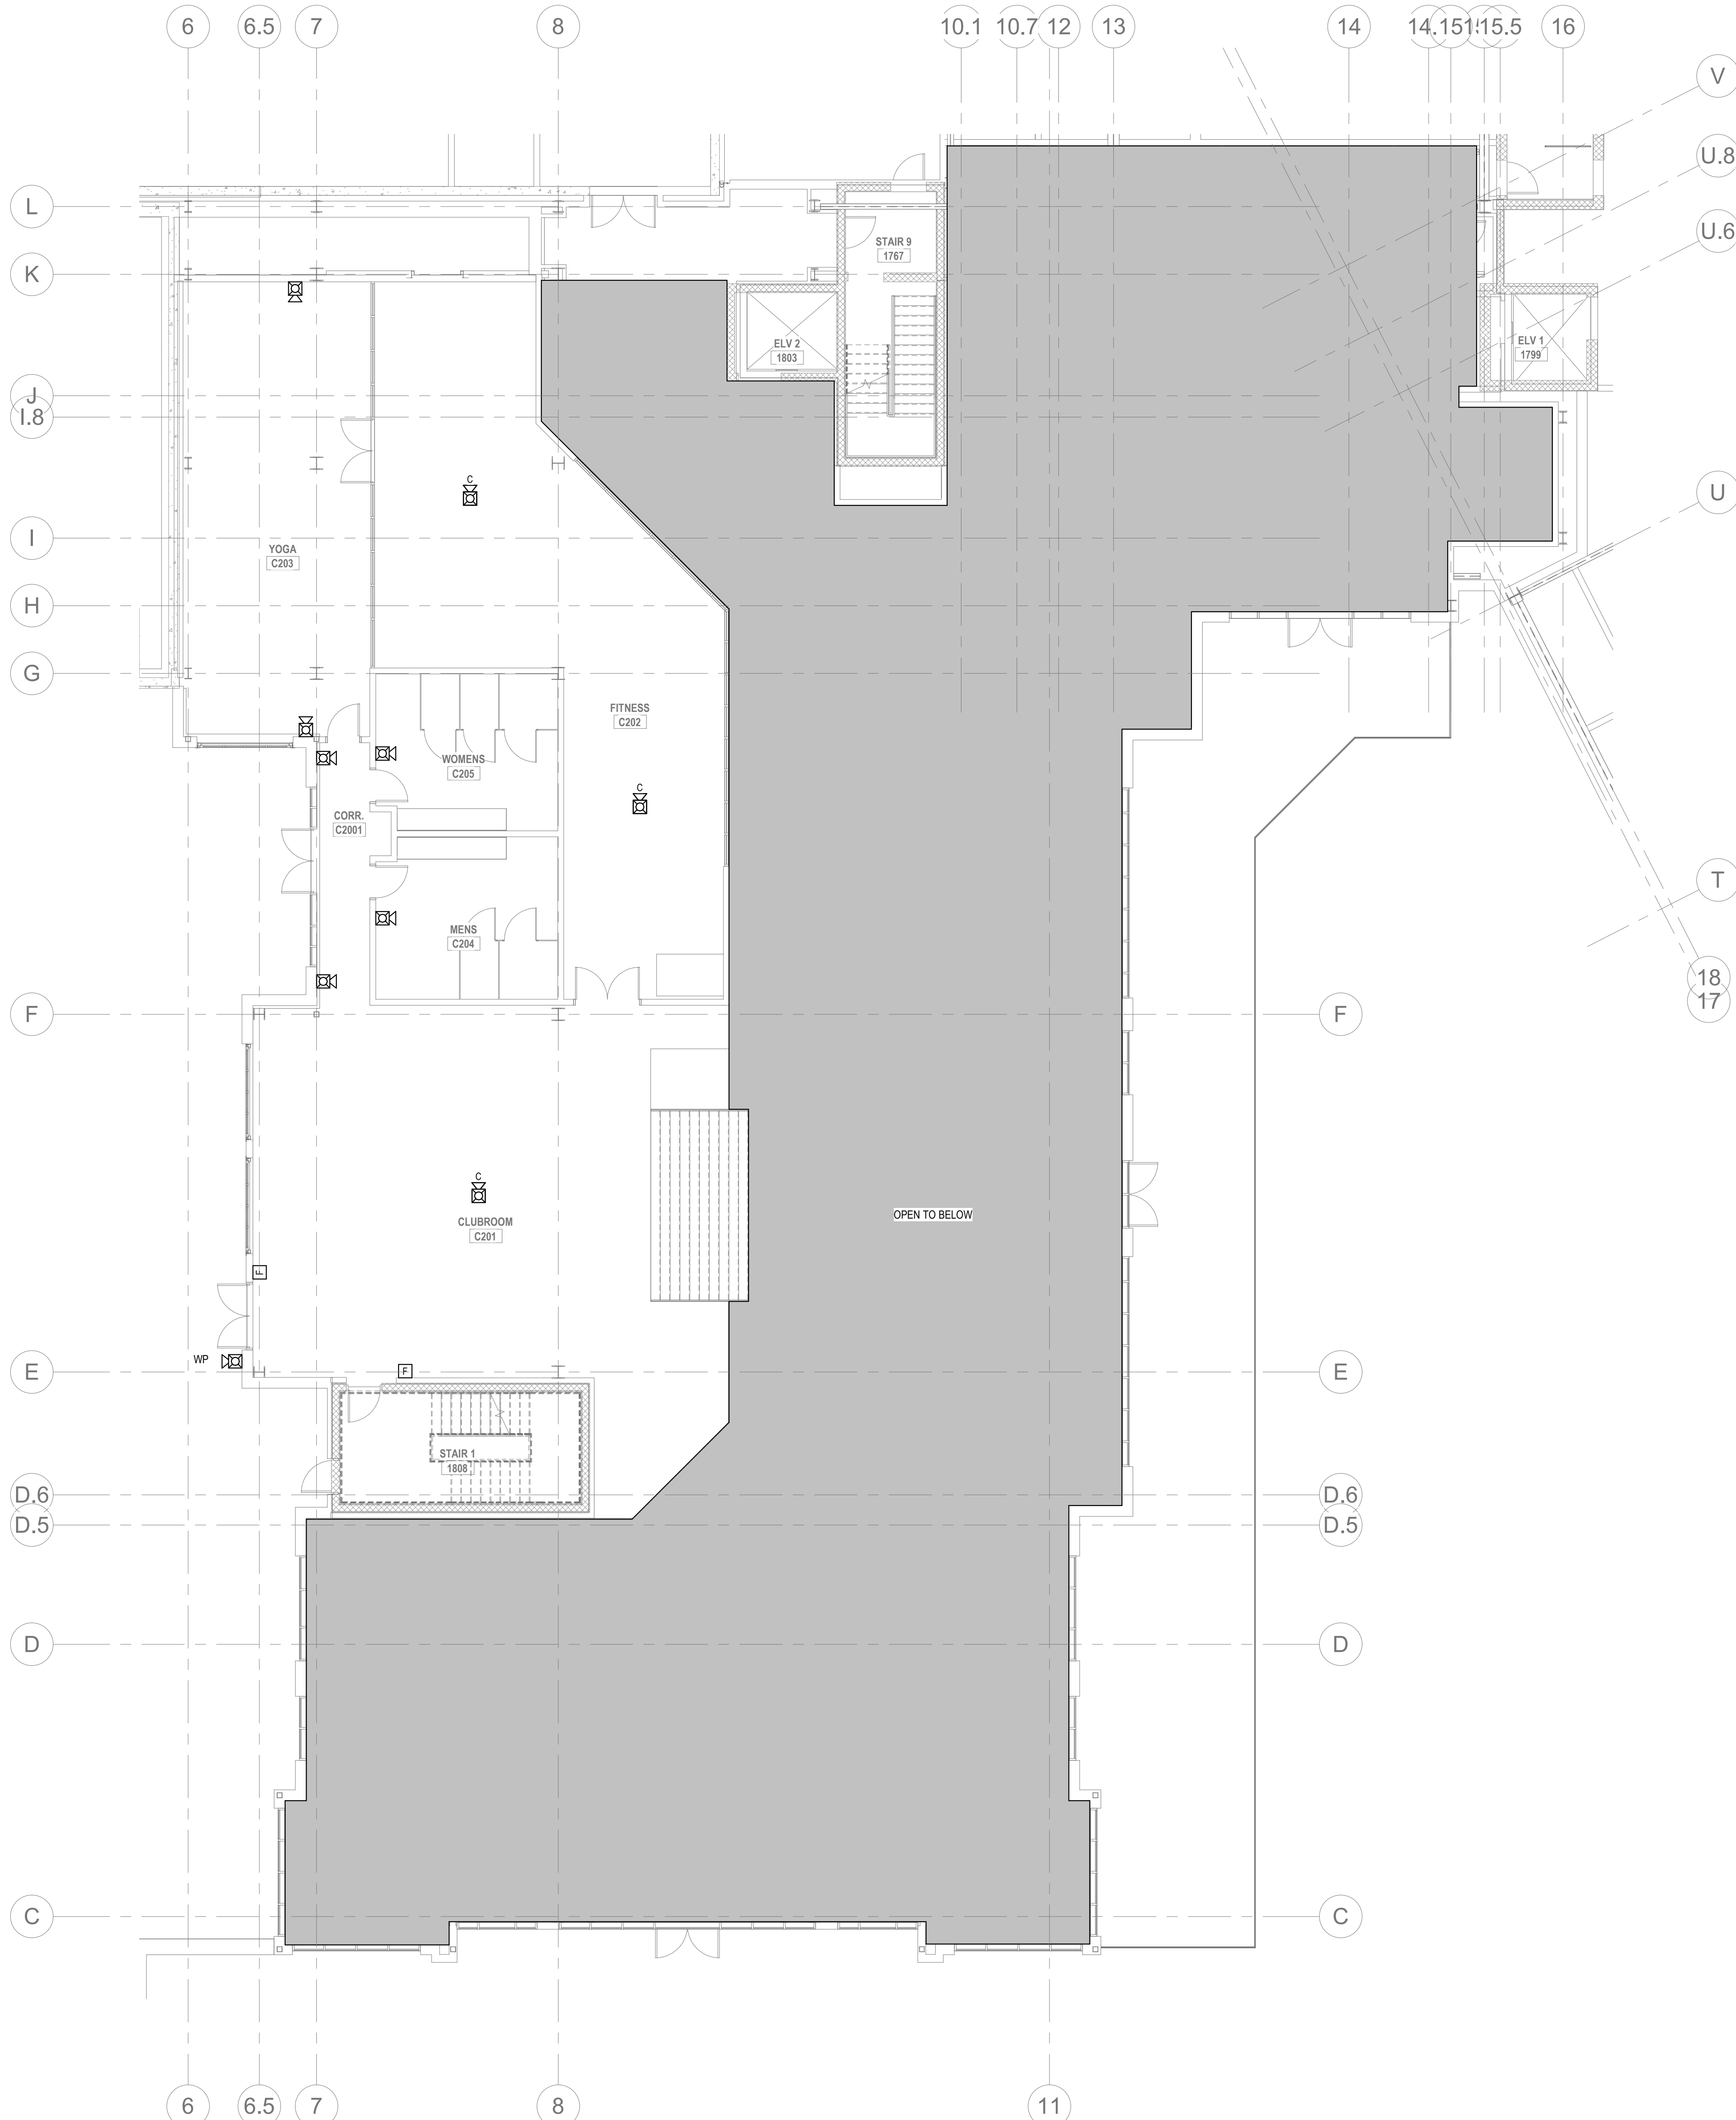

2 FIRE ALARM - CLUB LEVEL 2 PLAN B1
FA2.03B 1/8" = 1'-0"

ALL REPORTS, PLANS, SPECIFICATIONS AND COMPUTER FILES RELATING TO THIS PROJECT ARE THE PROPERTY OF THE MARTIN ARCHITECTURAL GROUP. THE MARTIN ARCHITECTURAL GROUP RETAINS ALL COMMON LAW, STATUTE AND OTHER RESERVED RIGHTS INCLUDING THE COPY RIGHT THEREIN. REPRODUCTION OF THE MATERIAL HEREIN OR SUBSTANTIAL USE WITHOUT WRITTEN PERMISSION OF THE MARTIN ARCHITECTURAL GROUP VIOLATES THE COPYRIGHT LAWS OF THE UNITED STATES AND WILL BE SUBJECT TO LEGAL PROSECUTION.
© The Martin Architectural Group, P.C.

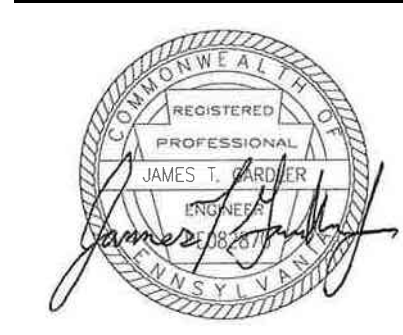

THE MARTIN ARCHITECTURAL GROUP, P.C.
ARCHITECTS AND LAND PLANNERS
A PROFESSIONAL CORPORATION
240 NORTH 22ND STREET, PHILADELPHIA, PA 19103
P (215) 665-1080 F (215) 561-5064

P.A.: JTG
P.M.: TRT
DRAWN BY: Author
PROJECT NO: 1022747

NO.	REVISION	DATE
1	ISSUE FOR PERMIT SET	11/01/2022
2	ISSUE FOR BUDGET SET	12/20/2022
3	ISSUE FOR PERMIT SET	
4	ISSUE FOR BUDGET SET	
5	ISSUE FOR PERMIT SET	
6	ISSUE FOR BUDGET SET	
7	ISSUE FOR PERMIT SET	
8	ISSUE FOR BUDGET SET	
9	ISSUE FOR PERMIT SET	
10	ISSUE FOR BUDGET SET	
11	ISSUE FOR PERMIT SET	
12	ISSUE FOR BUDGET SET	
13	ISSUE FOR PERMIT SET	
14	ISSUE FOR BUDGET SET	
15	ISSUE FOR PERMIT SET	
16	ISSUE FOR BUDGET SET	
17	ISSUE FOR PERMIT SET	
18	ISSUE FOR BUDGET SET	
19	ISSUE FOR PERMIT SET	
20	ISSUE FOR BUDGET SET	


Project Status

FIRE ALARM - CLUB LEVEL 2 PLAN B
Granite Run Apartments
MIDDLETOWN TOWNSHIP, PA

SCALE: AS INDICATED
DATE: 11/01/22

FA2.03B
© The Martin Architectural Group, P.C.

Printed: 1/13/2023 12:04:19 PM

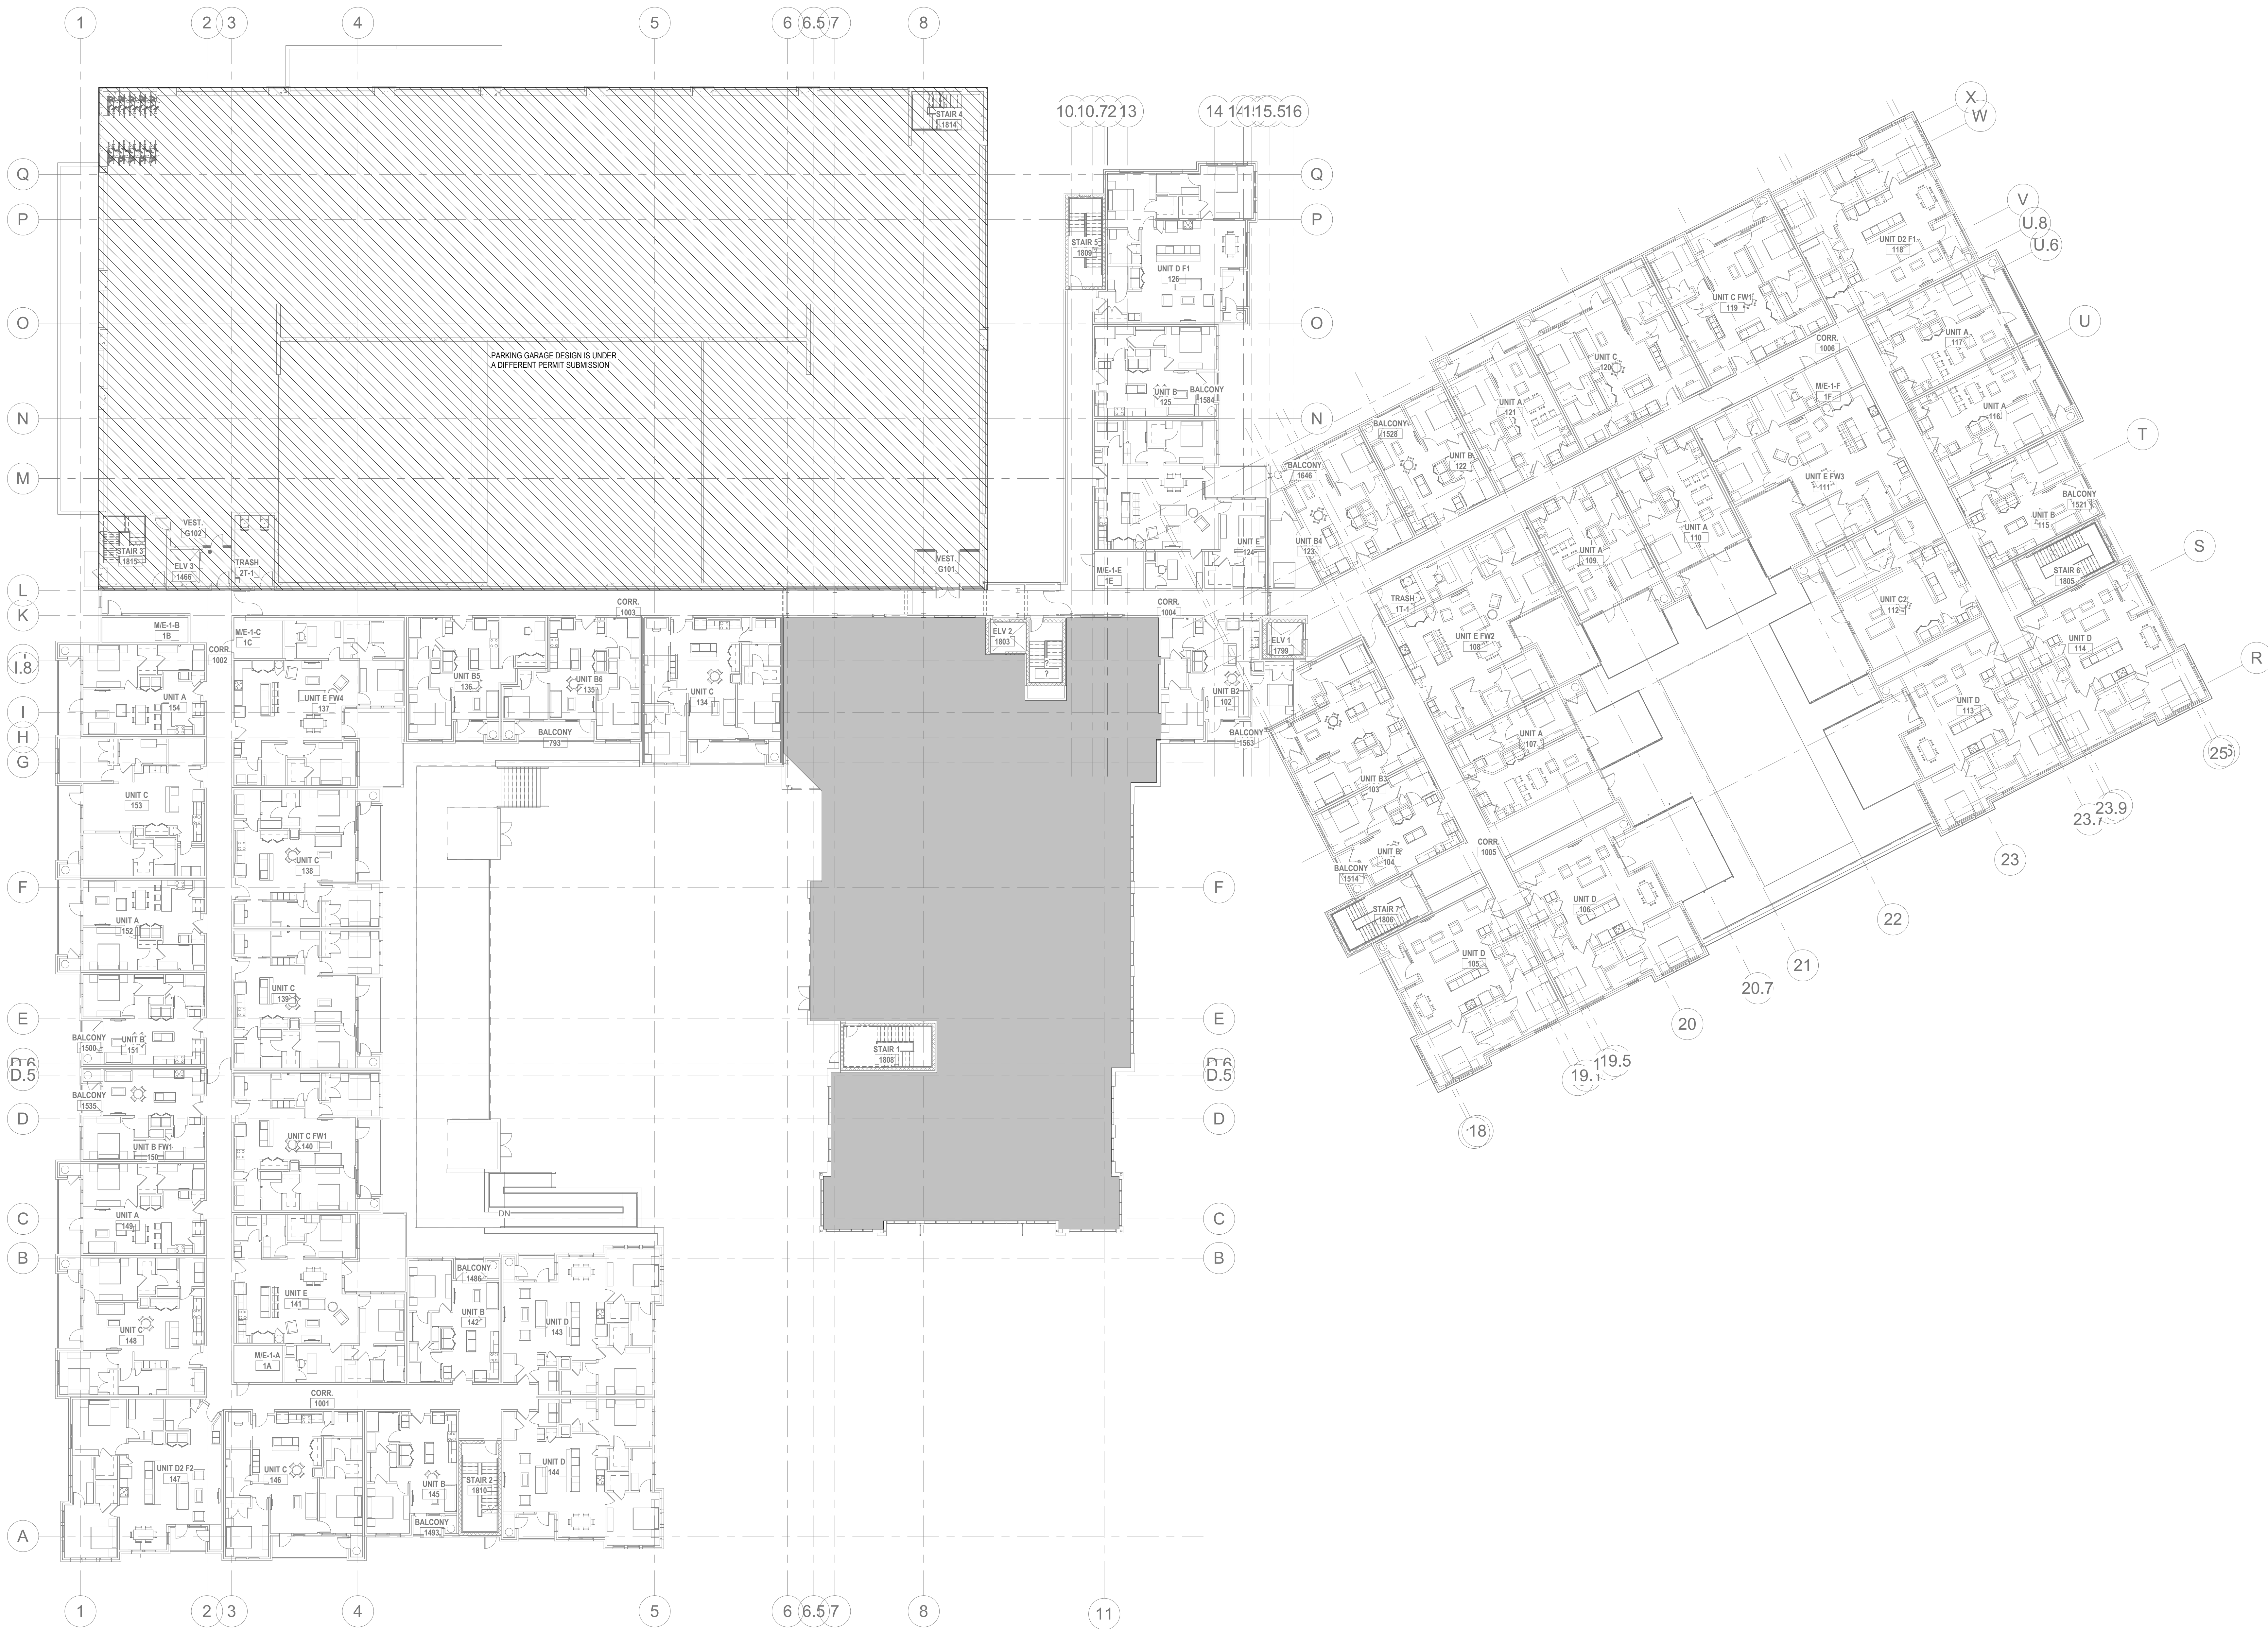

2 FIRE ALARM - FIRST FLOOR PLAN
FA2.04 1/16" = 1'-0"

ALL REPORTS, PLANS, SPECIFICATIONS AND COMPUTER FILES RELATING TO THIS PROJECT ARE THE PROPERTY OF THE MARTIN ARCHITECTURAL GROUP. THE MARTIN ARCHITECTURAL GROUP RETAINS ALL COMMON LAW, STATUTE AND OTHER RESERVED RIGHTS INCLUDING THE COPY RIGHT THEREIN. REPRODUCTION OF THE MATERIAL HEREIN OR SUBSTANTIAL USE WITHOUT WRITTEN PERMISSION OF THE MARTIN ARCHITECTURAL GROUP VIOLATES THE COPYRIGHT LAWS OF THE UNITED STATES AND WILL BE SUBJECT TO LEGAL PROSECUTION.
© The Martin Architectural Group, P.C.



THE MARTIN ARCHITECTURAL GROUP, P.C.
ARCHITECTS AND LAND PLANNERS
A PROFESSIONAL CORPORATION
240 NORTH 22ND STREET, PHILADELPHIA, PA 19103
P (215) 655-1060 F (215) 561-5064

P.A.: JTG
P.M.: TRT
DRAWN BY: Author
PROJECT NO: 1022747

NO.	REVISION	DATE
1	SCHEMATIC BUDGET PRICING SET	11/01/2022
2	PERMIT SET	12/20/2022


Project Status

FIRE ALARM - FIRST FLOOR PLAN
Granite Run Apartments
MIDDLETOWN TOWNSHIP, PA

SCALE: AS INDICATED
DATE: 11/01/22

FA2.04
© The Martin Architectural Group, P.C.

Printed: 1/13/2023 12:04:26 PM

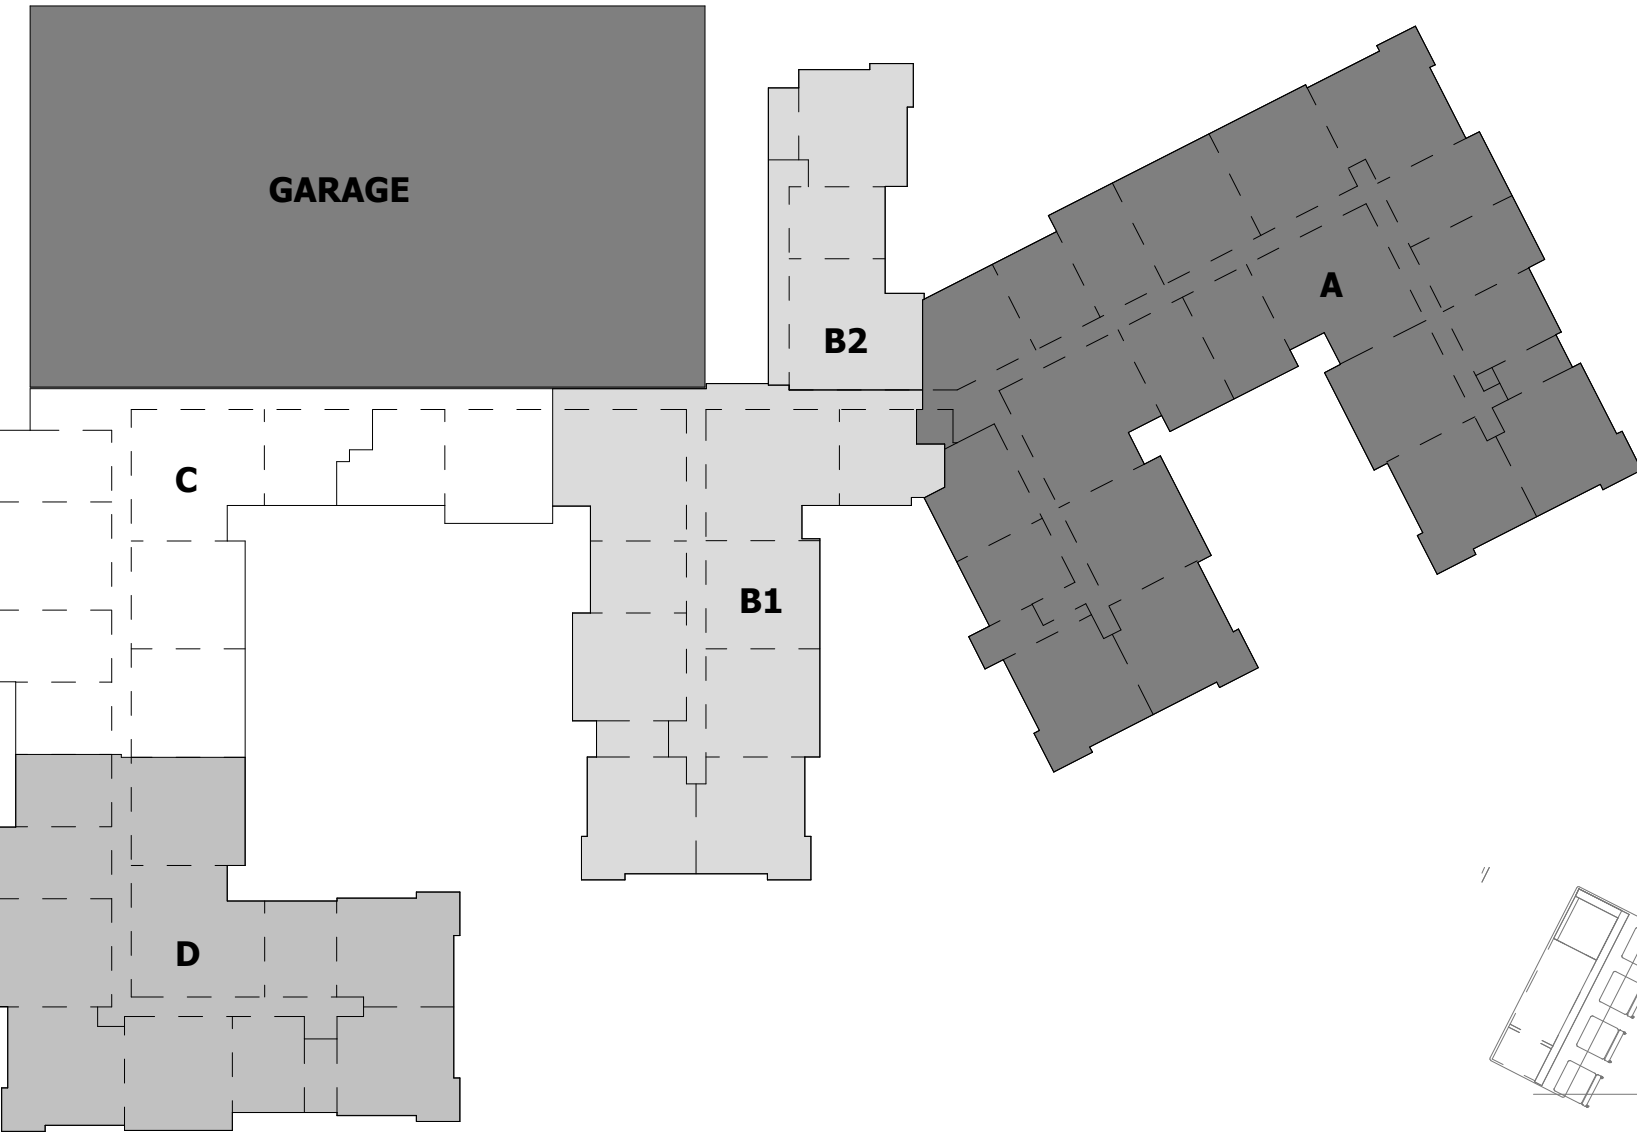

FIRE ALARM GENERAL NOTES

1. REFER TO SHEETS FA0.01 FOR NOTES, SYMBOLS AND ABBREVIATIONS.
2. EC SHALL REFER TO TELECOM, SECURITY & AV DRAWINGS, DETAILS FOR FINAL DEVICE LOCATIONS & RACEWAY REQUIREMENTS.
3. REFER TO MECHANICAL PLANS FOR DUCT SMOKE DETECTOR AND FIRE SMOKE DAMPER LOCATIONS. PROVIDE FA CONNECTION AND WIRE AS REQUIRED.
4. REFER TO FIRE PROTECTION PLANS FOR TAMPER AND FLOW SWITCH LOCATIONS. PROVIDE FA CONNECTION AND WIRE AS REQUIRED.
5. PROVIDE AREA SMOKE DETECTORS IN ELEVATORS LOBBIES AND ELEVATOR MACHINE ROOMS. SMOKE DETECTORS SHALL BE LOCATED ON THE CEILING WITHIN 21 FEET OF THE CENTERLINE OF EACH ELEVATOR DOOR WITHIN THE ELEVATOR BANK UNDER CONTROL OF THE DETECTOR FOR ELEVATOR LOBBIES UP TO 15 FEET IN HEIGHT WITH FLAT AND SMOOTH CEILINGS. FOR HIGHER AND UNEVEN CEILINGS, ADDITIONAL SMOKE DETECTORS MAY BE REQUIRED.
6. MANUAL FIRE ALARM BOXES SHALL BE LOCATED WITHIN 5 FEET OF EACH EXIT DOORWAY ON EACH FLOOR.
7. DUCT SMOKE DETECTORS AND DUCT SMOKE DETECTORS TEST STATIONS LOCATIONS TO BE COORDINATED WITH THE MECHANICAL DRAWINGS.
8. PROVIDE AND INSTALL SYSTEM FIRE ALARM ADDRESSABLE DUCT SMOKE DETECTORS AS INDICATED ON THE MECHANICAL FLOOR PLANS AND RISERS FOR FIRE/SMOKE DAMPERS AND SMOKE DAMPERS. PROVIDE ADDRESSABLE CONTROL RELAY AT EACH DAMPER.
9. PROVIDE 120V EMERGENCY POWER TO ALL FIRE/SMOKE AND SMOKE DAMPERS INDICATED ON THE MECHANICAL DRAWINGS.
10. THESE FIRE ALARM DRAWINGS ARE PERFORMANCE SPECIFICATION ONLY. CONTRACTOR SHALL PROVIDE A COMPLETE SYSTEM DESIGN IN COMPLIANCE WITH NFPA 72, THE IBC, NFPA 101, AND ANY OTHER ENFORCED CODES AND AMENDMENTS, INCLUDING ENGINEERED SIGNED AND SEALED DRAWINGS, POINT TO POINT WIRING WITH PROPOSED CIRCUITING OR CONDUIT ROUTING, ALL APPLICABLE CALCULATIONS, DEVICE MANUFACTURERS AND QUANTITIES, WIRING DIAGRAMS, AND SHOP SUBMITTALS. CONTRACTOR SHALL BE RESPONSIBLE FOR ALL ASSOCIATED PERMITS, INSPECTIONS, AND TESTING. CONSULT LOCAL BUILDING AUTHORITY AND FIRE MARSHAL REGARDING LOCAL AREA'S REQUIREMENTS.



1 FIRE ALARM - FIRST FLOOR ENLARGED PLAN A
FA2.04A 1/8" = 1'-0"

ALL REPORTS, PLANS, SPECIFICATIONS AND COMPUTER FILES RELATING TO THIS PROJECT ARE THE PROPERTY OF THE MARTIN ARCHITECTURAL GROUP. THE MARTIN ARCHITECTURAL GROUP RETAINS ALL COMMON LAW, STATUTE AND OTHER RESERVED RIGHTS INCLUDING THE COPY RIGHT THERE TO. REPRODUCTION OF THE MATERIAL HEREIN OR SUBSTANTIAL USE WITHOUT WRITTEN PERMISSION OF THE MARTIN ARCHITECTURAL GROUP VIOLATES THE COPYRIGHT LAWS OF THE UNITED STATES AND WILL BE SUBJECT TO LEGAL PROSECUTION.
© The Martin Architectural Group, P.C.



THE MARTIN ARCHITECTURAL GROUP, P.C.
ARCHITECTS AND LAND PLANNERS
A PROFESSIONAL CORPORATION
240 NORTH 22ND STREET, PHILADELPHIA, PA 19103
P (215) 665-1060 F (215) 561-5064

P.A.: JTG
P.M.: TRT
DRAWN BY: Author
PROJECT NO: 1022747

NO.	REVISION	DATE
1	SEPARATE BUDGET PRICING SET 1 PERMIT SET	11/01/2022 12/20/2022


Project Status

FIRE ALARM - FIRST FLOOR ENLARGED PLAN A
Granite Run Apartments

SCALE: AS INDICATED
DATE: 11/01/22


FA2.04A
© The Martin Architectural Group, P.C.

Printed: 1/13/2023 12:04:36 PM

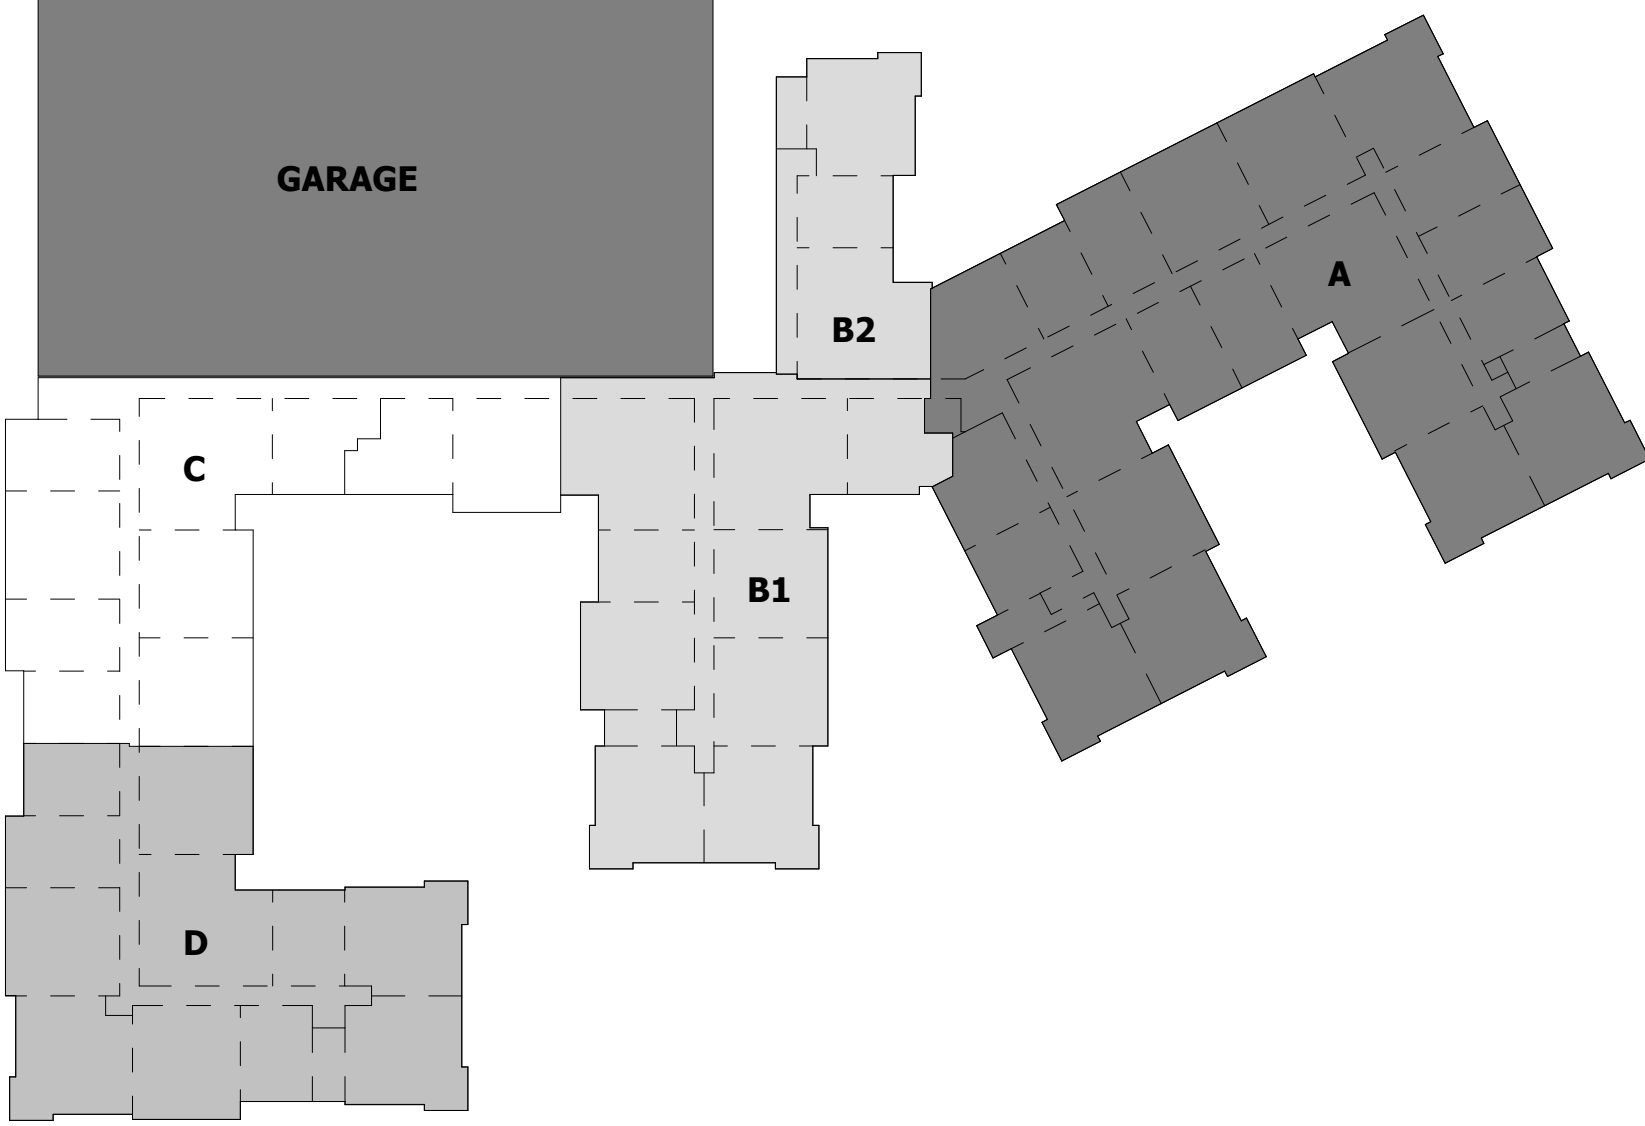


FIRE ALARM GENERAL NOTES

1. REFER TO SHEETS FA0.01 FOR NOTES, SYMBOLS AND ABBREVIATIONS.
2. EC SHALL REFER TO TELECOM, SECURITY & AV DRAWINGS, DETAILS FOR FINAL DEVICE LOCATIONS & RACEWAY REQUIREMENTS.
3. REFER TO MECHANICAL PLANS FOR DUCT SMOKE DETECTOR AND FIRE SMOKE DAMPER LOCATIONS. PROVIDE FA CONNECTION AND WIRE AS REQUIRED.
4. REFER TO FIRE PROTECTION PLANS FOR TAMPER AND FLOW SWITCH LOCATIONS. PROVIDE FA CONNECTION AND WIRE AS REQUIRED.
5. PROVIDE AREA SMOKE DETECTORS IN ELEVATOR LOBBIES AND ELEVATOR MACHINE ROOMS. SMOKE DETECTORS SHALL BE LOCATED ON THE CEILING WITHIN 21 FEET OF THE CENTERLINE OF EACH ELEVATOR DOOR WITHIN THE ELEVATOR BANK UNDER CONTROL OF THE DETECTOR FOR ELEVATOR LOBBIES UP TO 15 FEET IN HEIGHT WITH FLAT AND SMOOTH CEILINGS. FOR HIGHER AND UNEVEN CEILINGS, ADDITIONAL SMOKE DETECTORS MAY BE REQUIRED.
6. MANUAL FIRE ALARM BOXES SHALL BE LOCATED WITHIN 5 FEET OF EACH EXIT DOORWAY ON EACH FLOOR.
7. DUCT SMOKE DETECTORS AND DUCT SMOKE DETECTORS TEST STATIONS LOCATIONS TO BE COORDINATED WITH THE MECHANICAL DRAWINGS.
8. PROVIDE AND INSTALL SYSTEM FIRE ALARM ADDRESSABLE DUCT SMOKE DETECTORS AS INDICATED ON THE MECHANICAL FLOOR PLANS AND RISERS FOR FIRE/SMOKE DAMPERS AND SMOKE DAMPERS. PROVIDE ADDRESSABLE CONTROL RELAY AT EACH DAMPER.
9. PROVIDE 120V EMERGENCY POWER TO ALL FIRE/SMOKE AND SMOKE DAMPERS INDICATED ON THE MECHANICAL DRAWINGS.
10. THESE FIRE ALARM DRAWINGS ARE PERFORMANCE SPECIFICATION ONLY. CONTRACTOR SHALL PROVIDE A COMPLETE SYSTEM DESIGN IN COMPLIANCE WITH NFPA 72, THE IBC, NFPA 101, AND ANY OTHER ENFORCED CODES AND AMENDMENTS, INCLUDING ENGINEERED SIGNED AND SEALED DRAWINGS, POINT TO POINT WIRING WITH PROPOSED CIRCUITING OR CONDUIT ROUTING, ALL APPLICABLE CALCULATIONS, DEVICE MANUFACTURERS AND QUANTITIES, WIRING DIAGRAMS, AND SHOP SUBMITTALS. CONTRACTOR SHALL BE RESPONSIBLE FOR ALL ASSOCIATED PERMITS, INSPECTIONS, AND TESTING. CONSULT LOCAL BUILDING AUTHORITY AND FIRE MARSHAL REGARDING LOCAL AREA'S REQUIREMENTS.

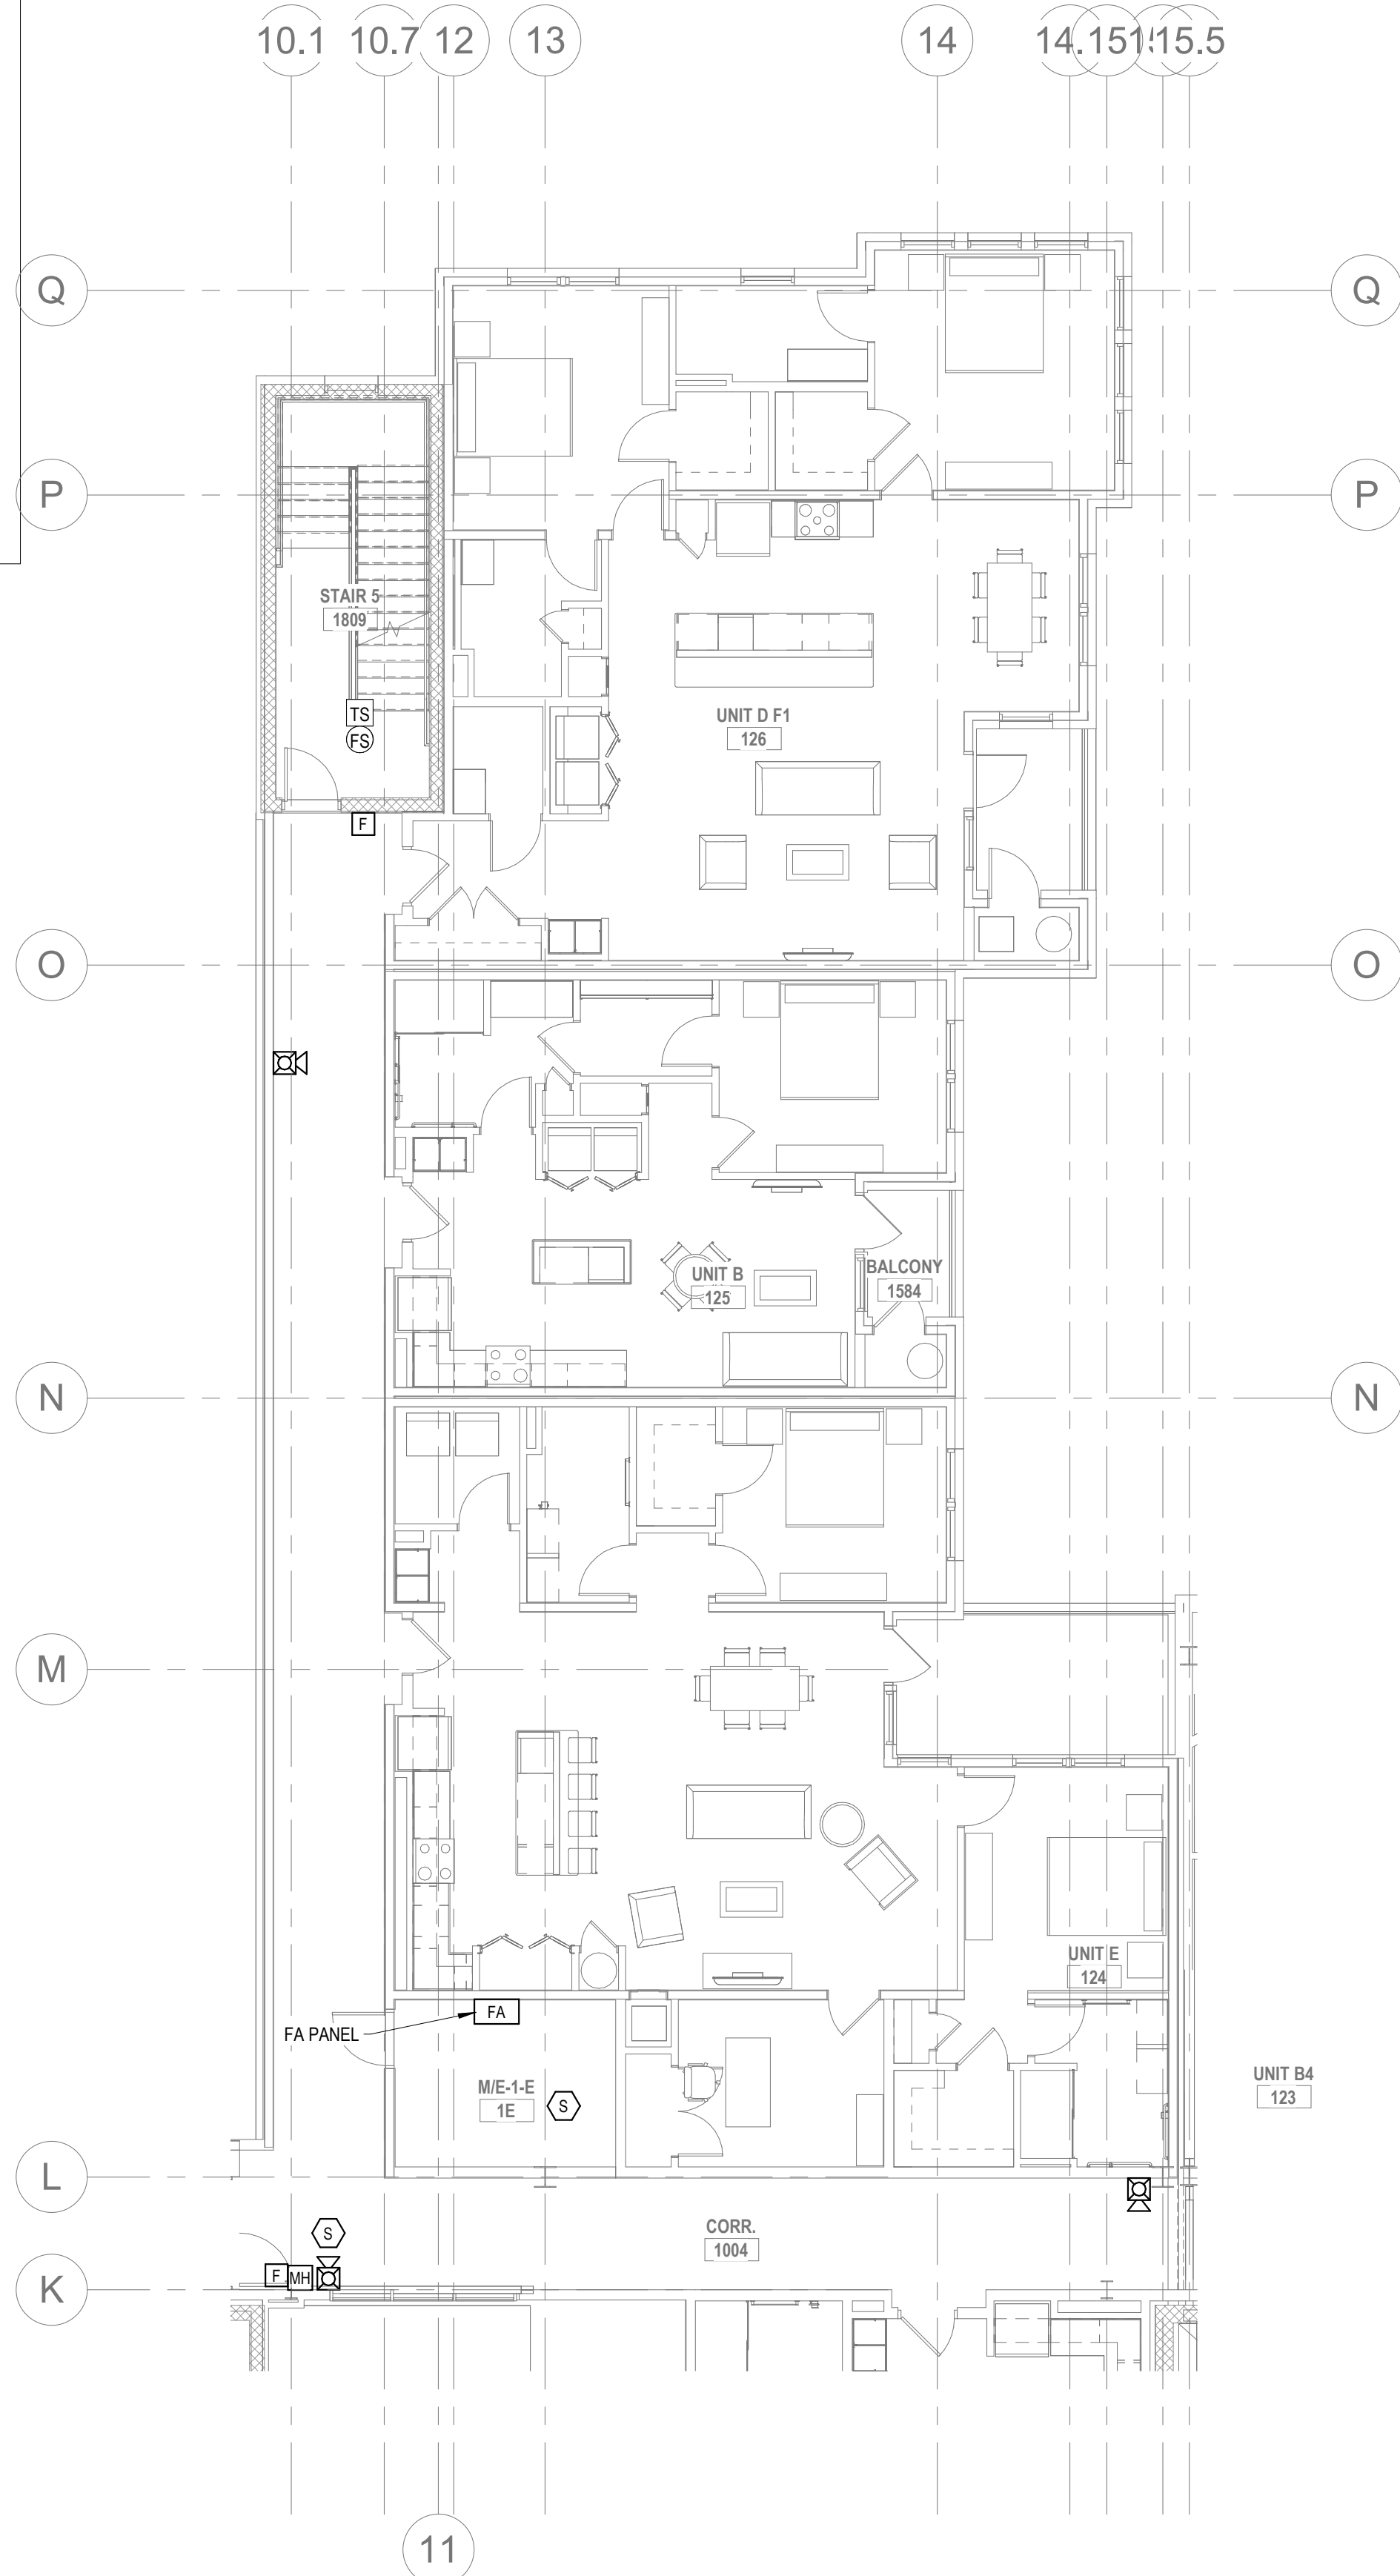

3 FIRE ALARM - FIRST FLOOR ENLARGED PLAN B2
FA2.04B 1/8" = 1'-0"

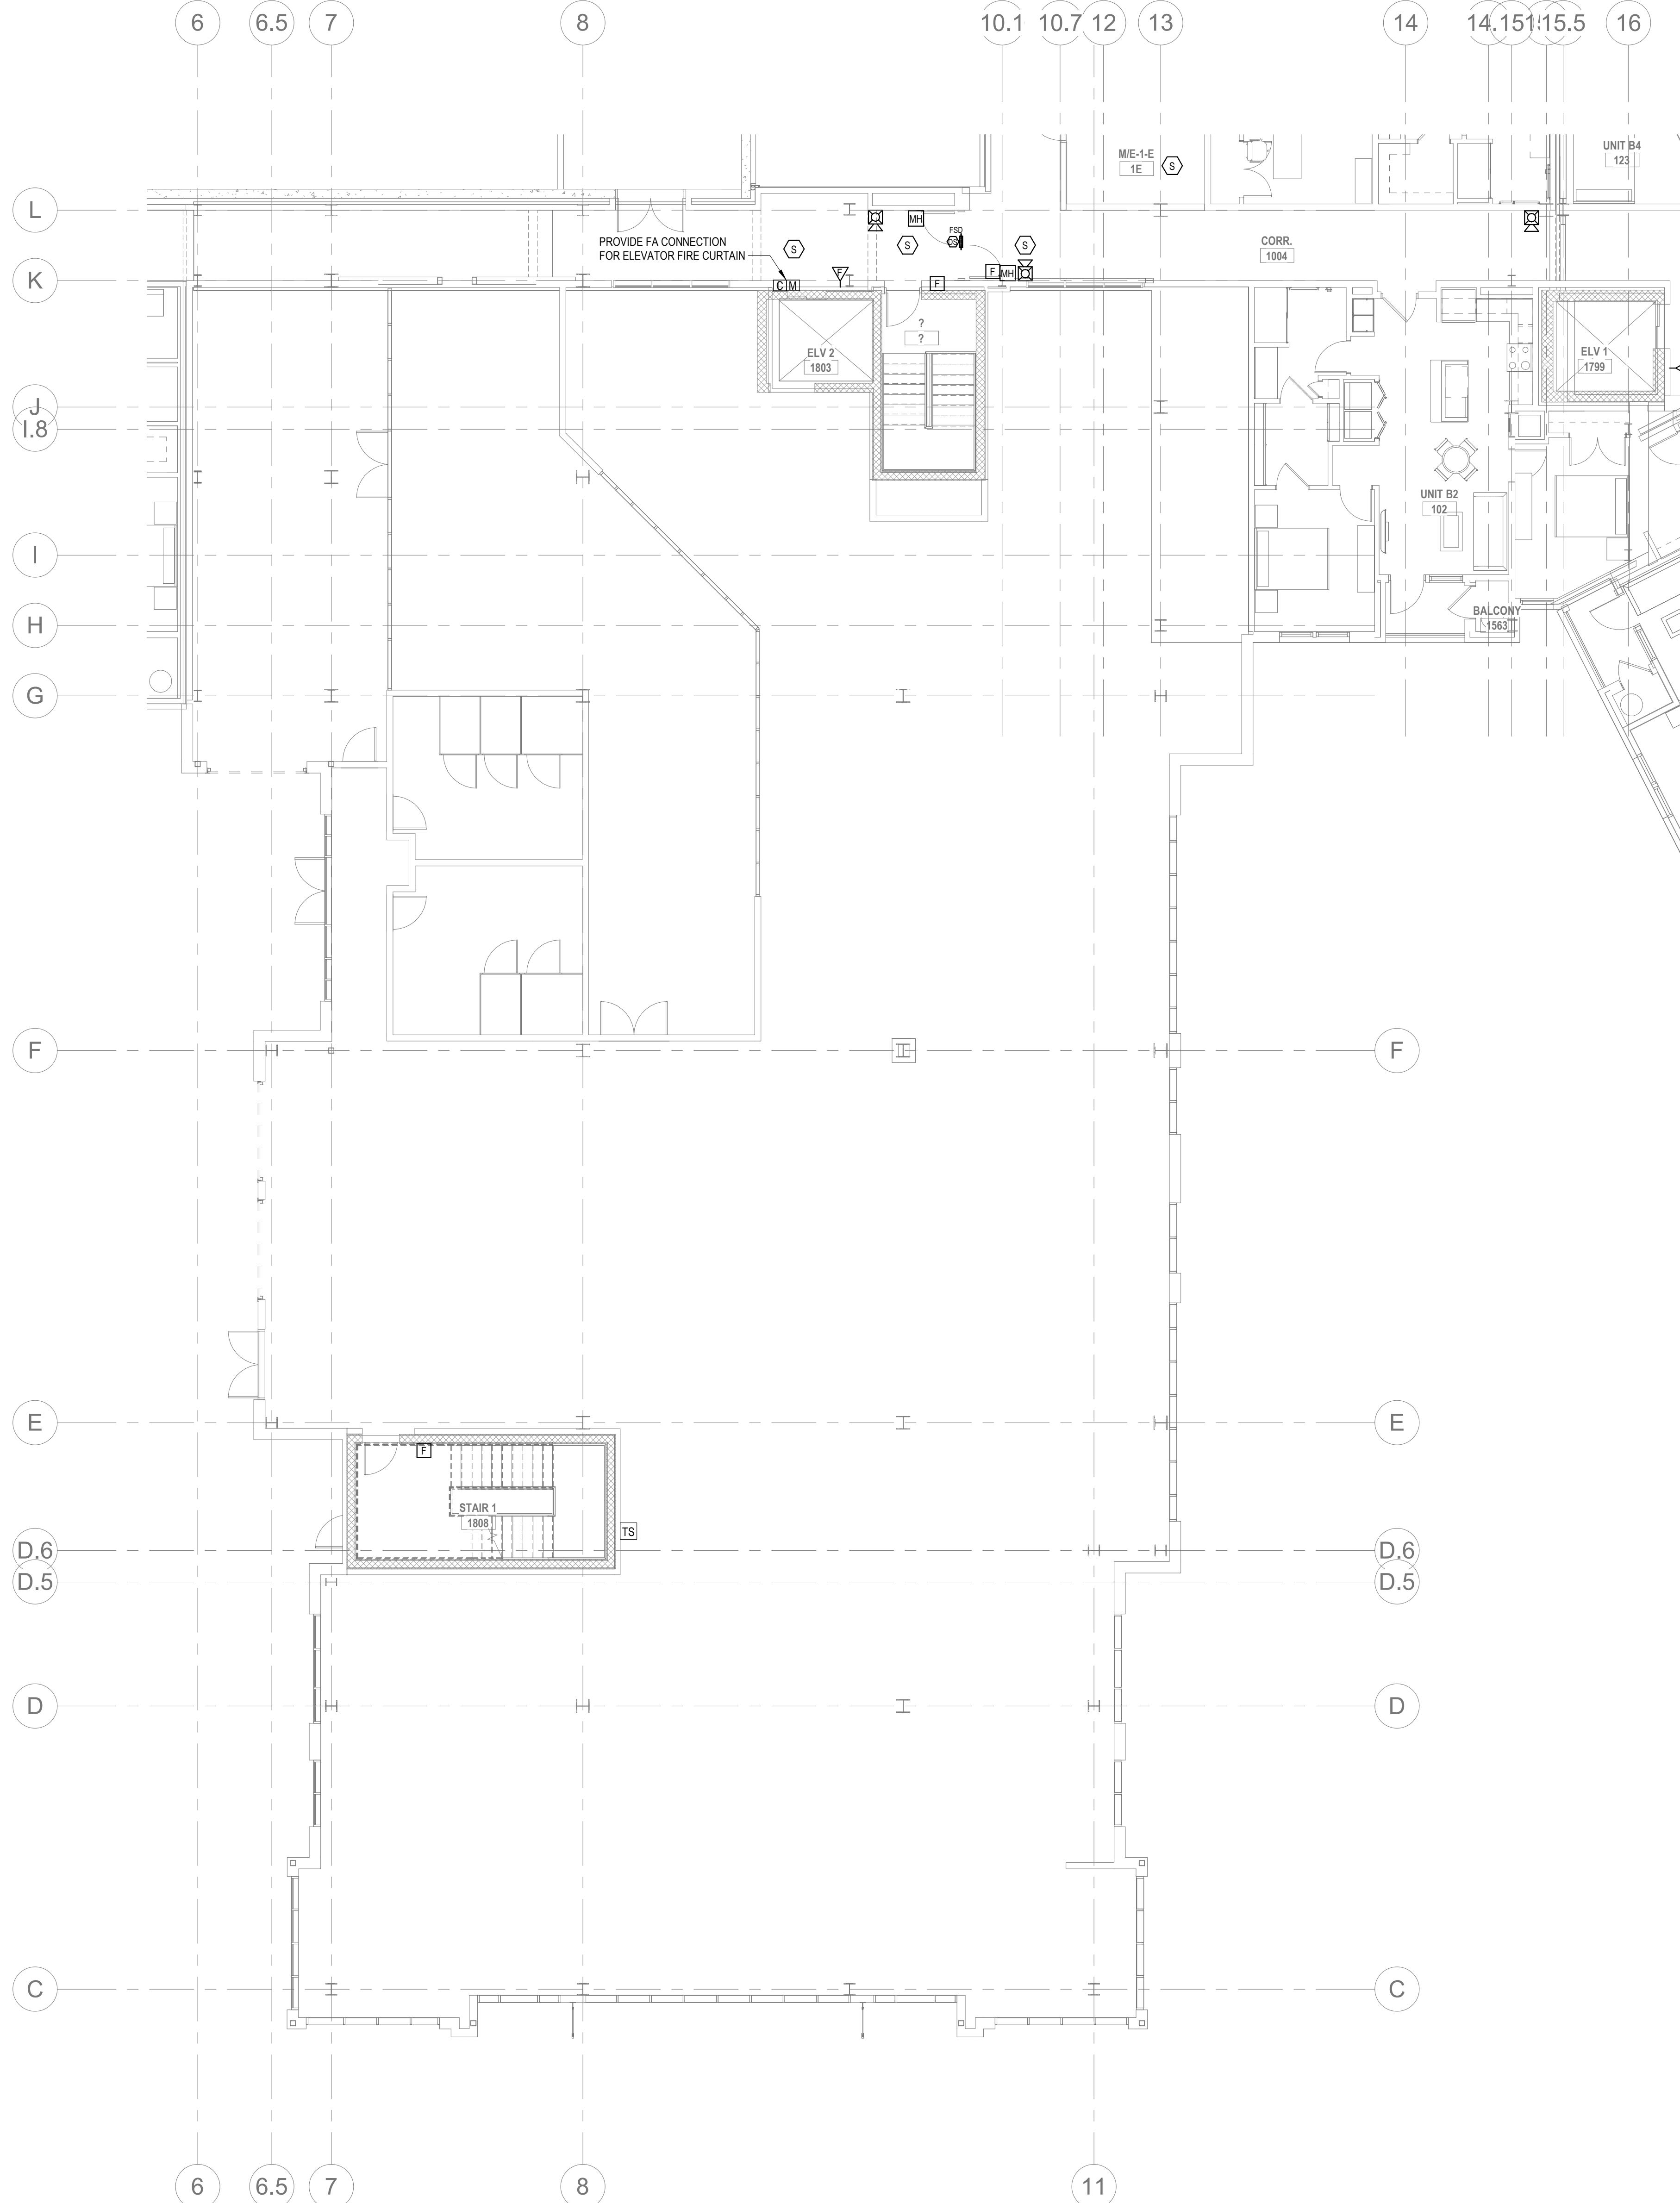

4 FIRE ALARM - FIRST FLOOR ENLARGED PLAN B1
FA2.04B 1/8" = 1'-0"

ALL REPORTS, PLANS, SPECIFICATIONS AND COMPUTER FILES RELATING TO THIS PROJECT ARE THE PROPERTY OF THE MARTIN ARCHITECTURAL GROUP. THE MARTIN ARCHITECTURAL GROUP RETAINS ALL COMMON LAW, STATUTE AND OTHER RESERVED RIGHTS INCLUDING THE COPY RIGHT THEREIN. REPRODUCTION OF THE MATERIAL HEREIN OR SUBSTANTIAL USE WITHOUT WRITTEN PERMISSION OF THE MARTIN ARCHITECTURAL GROUP VIOLATES THE COPYRIGHT LAWS OF THE UNITED STATES AND WILL BE SUBJECT TO LEGAL PROSECUTION.
© The Martin Architectural Group, P.C.



THE MARTIN ARCHITECTURAL GROUP, P.C.
ARCHITECTS AND LAND PLANNERS
A PROFESSIONAL CORPORATION
240 NORTH 22ND STREET, PHILADELPHIA, PA 19103
P (215) 665-1080 F (215) 561-5064

P.A.: JTG
P.M.: TRT
DRAWN BY: Author
PROJECT NO: 1022747


NO.	REVISION	DATE
1	SCHEMATIC BUDGET PRICING SET	11/01/2022
1	PERMIT SET	12/20/2022

Project Status

FIRE ALARM - FIRST FLOOR ENLARGED PLAN B
Granite Run Apartments


SCALE: AS INDICATED
DATE: 11/01/22

FA2.04B
© The Martin Architectural Group, P.C.

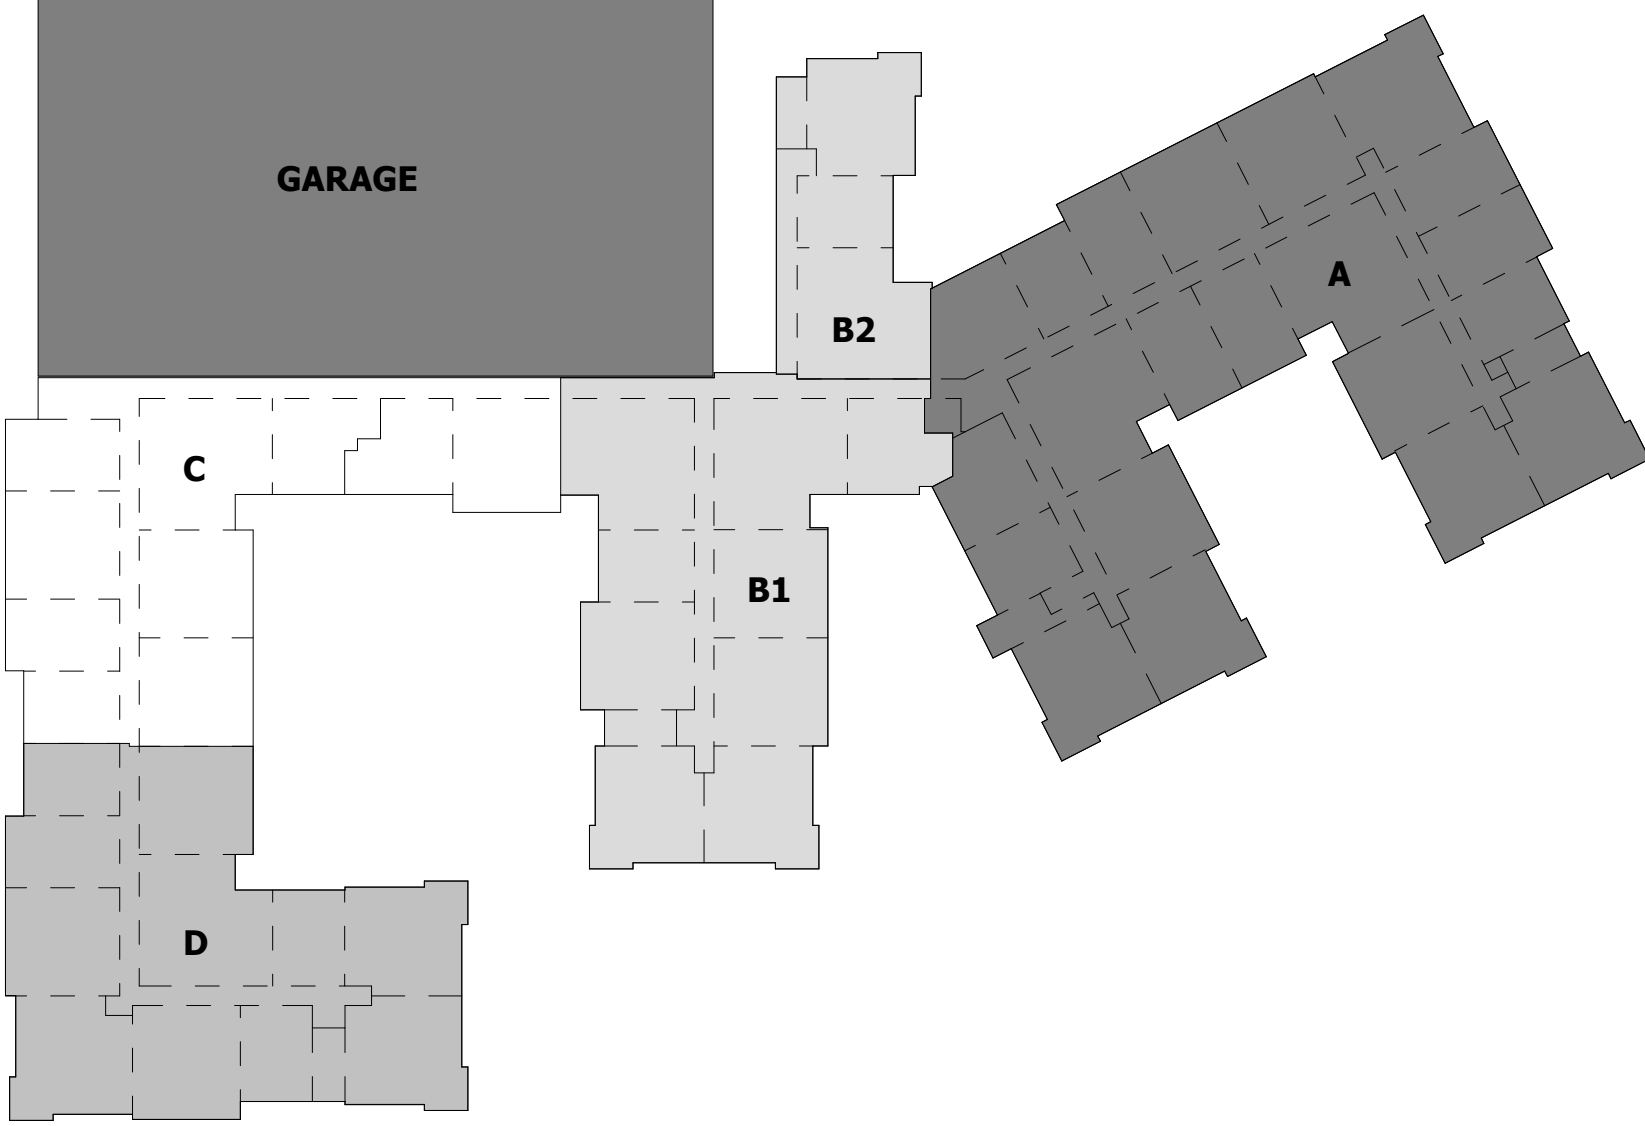

FIRE ALARM GENERAL NOTES

1. REFER TO SHEETS FA0.01 FOR NOTES, SYMBOLS AND ABBREVIATIONS.
2. EC SHALL REFER TO TELECOM, SECURITY & AV DRAWINGS, DETAILS FOR FINAL DEVICE LOCATIONS & RACEWAY REQUIREMENTS.
3. REFER TO MECHANICAL PLANS FOR DUCT SMOKE DETECTOR AND FIRE SMOKE DAMPER LOCATIONS. PROVIDE FA CONNECTION AND WIRE AS REQUIRED.
4. REFER TO FIRE PROTECTION PLANS FOR TAMPER AND FLOW SWITCH LOCATIONS. PROVIDE FA CONNECTION AND WIRE AS REQUIRED.
5. PROVIDE AREA SMOKE DETECTORS IN ELEVATORS LOBBIES AND ELEVATOR MACHINE ROOM(S). SMOKE DETECTORS SHALL BE LOCATED ON THE CEILING WITHIN 21 FEET OF THE CENTERLINE OF EACH ELEVATOR DOOR WITHIN THE ELEVATOR BANK UNDER CONTROL OF THE DETECTOR FOR ELEVATOR LOBBIES UP TO 15 FEET IN HEIGHT WITH FLAT AND SMOOTH CEILINGS. FOR HIGHER AND UNEVEN CEILINGS, ADDITIONAL SMOKE DETECTORS MAY BE REQUIRED.
6. MANUAL FIRE ALARM BOXES SHALL BE LOCATED WITHIN 5 FEET OF EACH EXIT DOORWAY ON EACH FLOOR.
7. DUCT SMOKE DETECTORS AND DUCT SMOKE DETECTORS TEST STATIONS LOCATIONS TO BE COORDINATED WITH THE MECHANICAL DRAWINGS.
8. PROVIDE AND INSTALL SYSTEM FIRE ALARM ADDRESSABLE DUCT SMOKE DETECTORS AS INDICATED ON THE MECHANICAL FLOOR PLANS AND RISERS FOR FIRE/SMOKE DAMPERS AND SMOKE DAMPERS. PROVIDE ADDRESSABLE CONTROL RELAY AT EACH DAMPER.
9. PROVIDE 120V EMERGENCY POWER TO ALL FIRE/SMOKE AND SMOKE DAMPERS INDICATED ON THE MECHANICAL DRAWINGS.
10. THESE FIRE ALARM DRAWINGS ARE PERFORMANCE SPECIFICATION ONLY. CONTRACTOR SHALL PROVIDE A COMPLETE SYSTEM DESIGN IN COMPLIANCE WITH NFPA 72, THE IBC, NFPA 101, AND ANY OTHER ENFORCED CODES AND AMENDMENTS, INCLUDING ENGINEERED SIGNED AND SEALED DRAWINGS, POINT TO POINT WIRING WITH PROPOSED CIRCUITING OR CONDUIT ROUTING, ALL APPLICABLE CALCULATIONS, DEVICE MANUFACTURERS AND QUANTITIES, WIRING DIAGRAMS, AND SHOP SUBMITTALS. CONTRACTOR SHALL BE RESPONSIBLE FOR ALL ASSOCIATED PERMITS, INSPECTIONS, AND TESTING. CONSULT LOCAL BUILDING AUTHORITY AND FIRE MARSHAL REGARDING LOCAL AREA'S REQUIREMENTS.

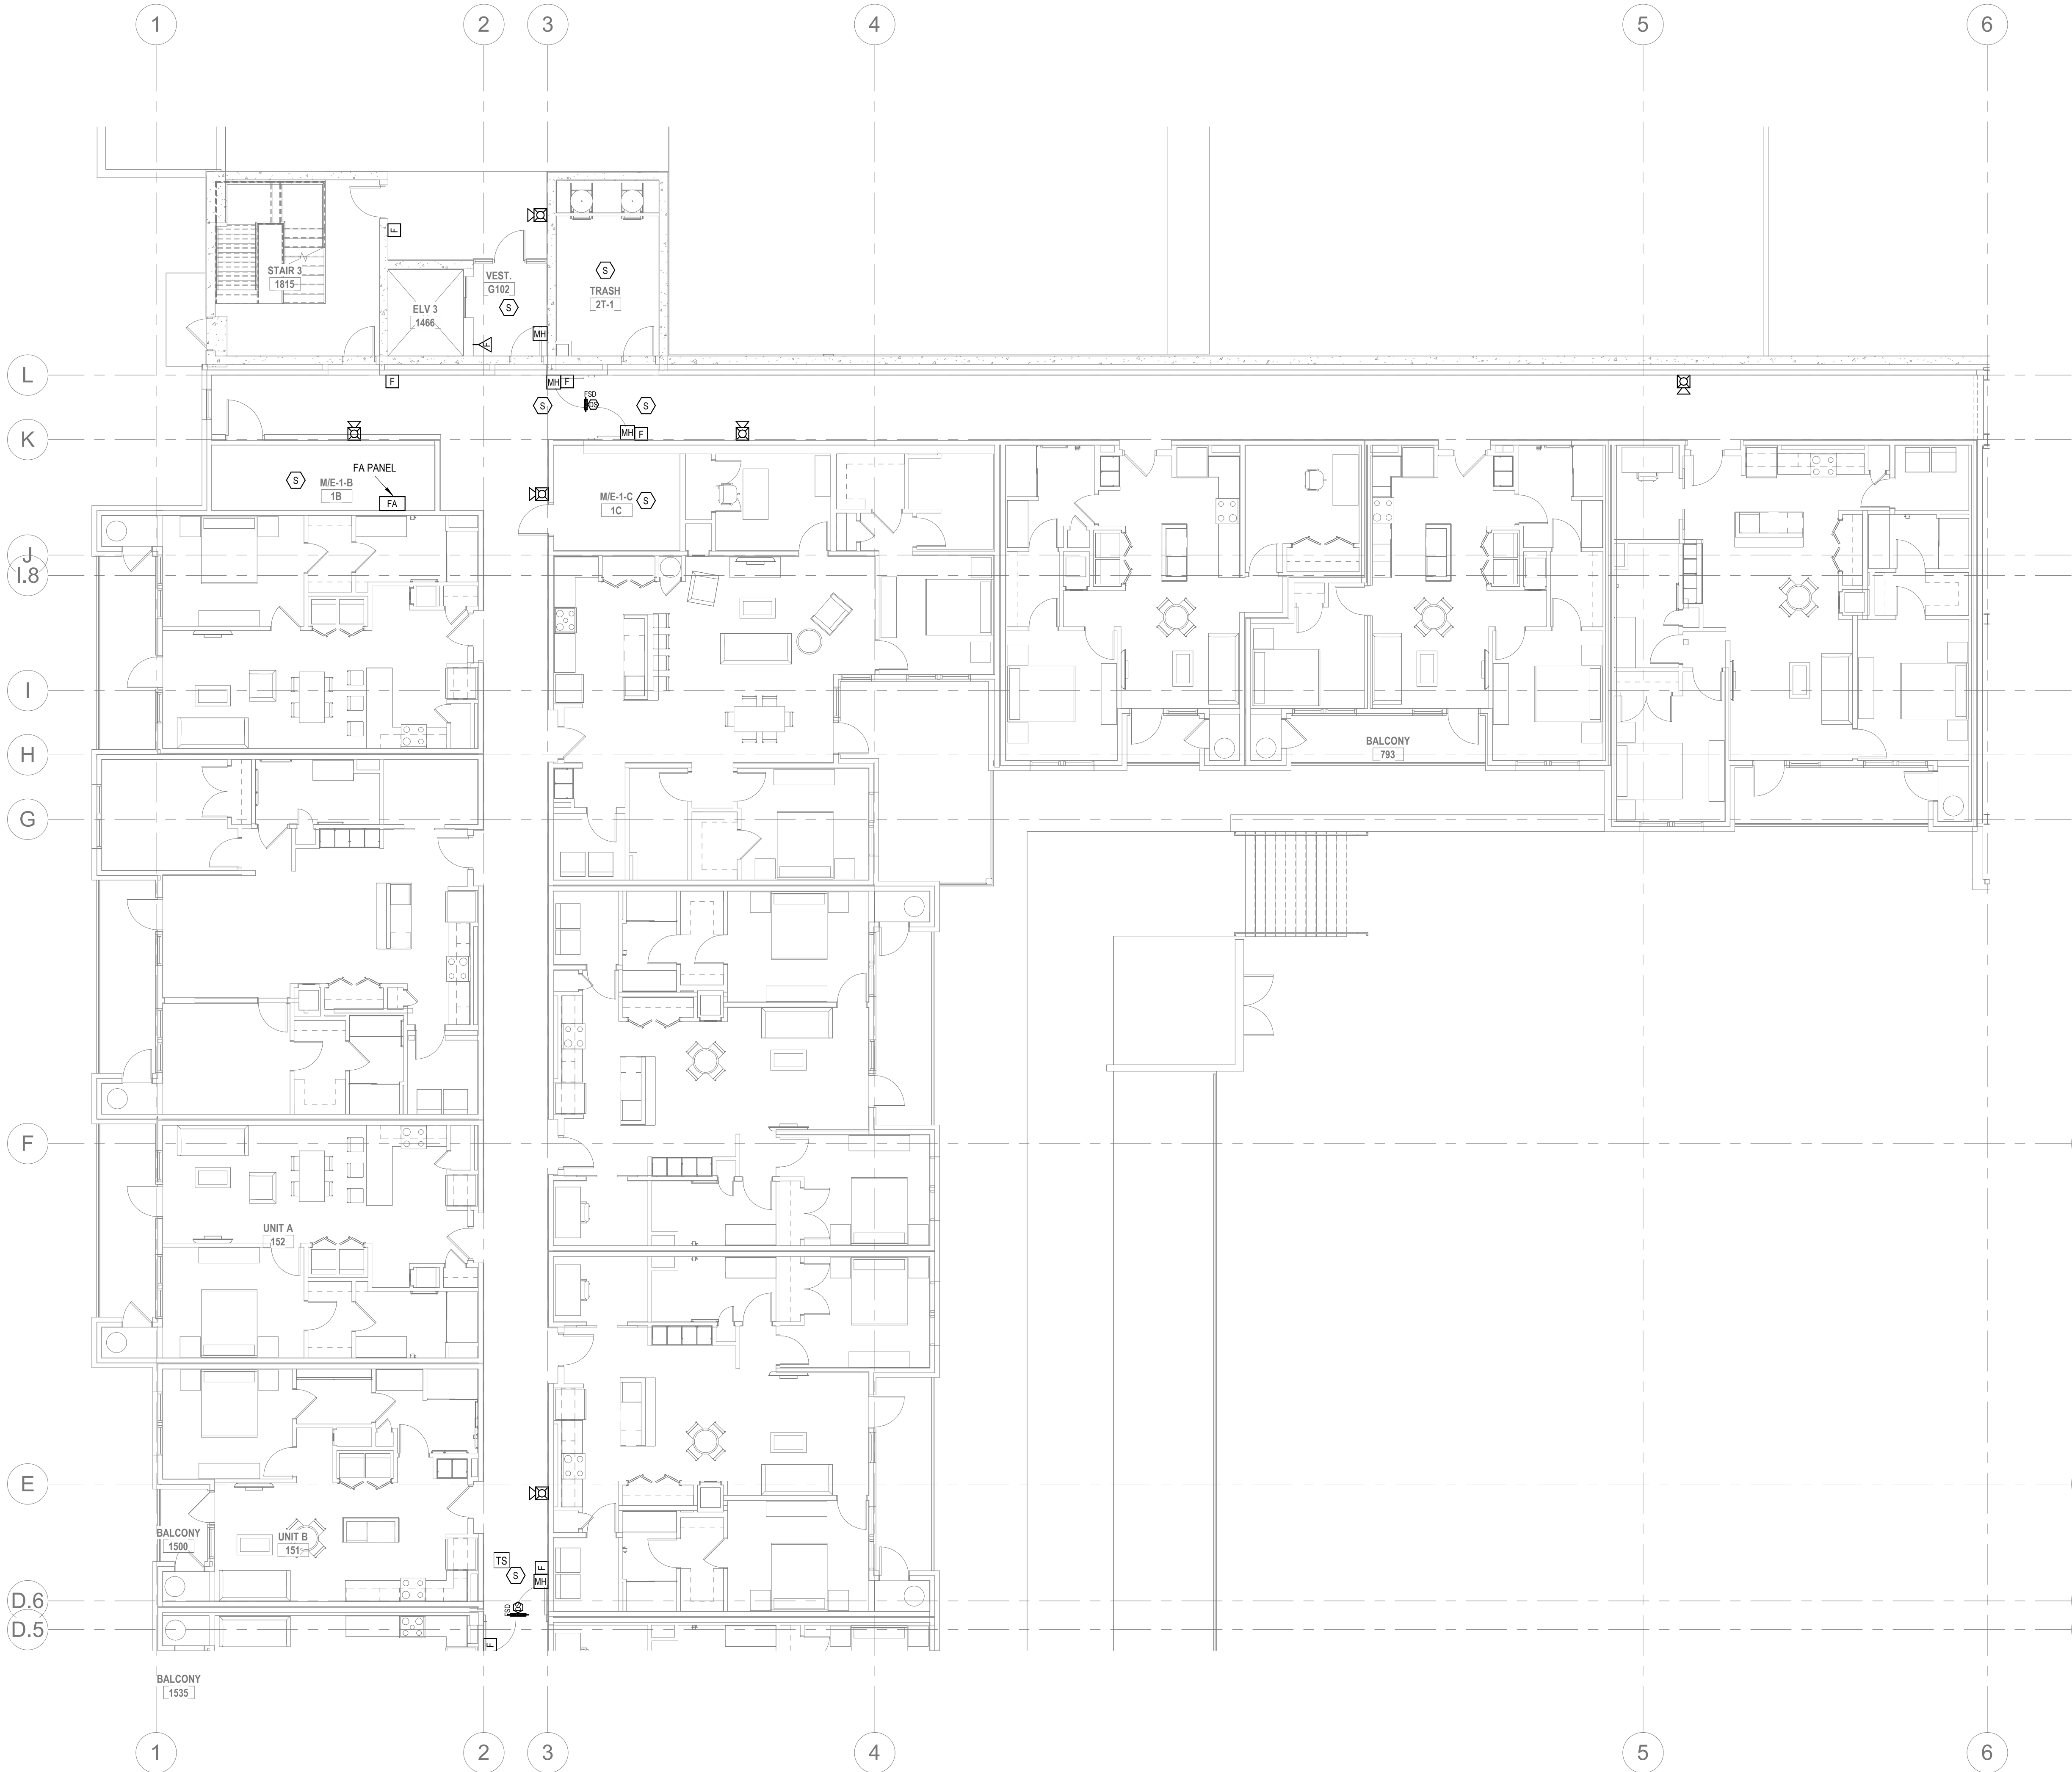

2 FIRE ALARM - FIRST FLOOR ENLARGED PLAN C
1/8" = 1'-0"

ALL REPORTS, PLANS, SPECIFICATIONS AND COMPUTER FILES RELATING TO THIS PROJECT ARE THE PROPERTY OF THE MARTIN ARCHITECTURAL GROUP. THE MARTIN ARCHITECTURAL GROUP RETAINS ALL COMMON LAW, STATUTE AND OTHER RESERVED RIGHTS INCLUDING THE COPY RIGHT THERE TO. REPRODUCTION OF THE MATERIAL HEREIN OR SUBSTANTIAL USE WITHOUT WRITTEN PERMISSION OF THE MARTIN ARCHITECTURAL GROUP VIOLATES THE COPYRIGHT LAWS OF THE UNITED STATES AND WILL BE SUBJECT TO LEGAL PROSECUTION.
© The Martin Architectural Group, P.C.



THE MARTIN ARCHITECTURAL GROUP, P.C.
ARCHITECTS AND LAND PLANNERS
A PROFESSIONAL CORPORATION
240 NORTH 22ND STREET, PHILADELPHIA, PA, 19103
P (215) 665-1060 F (215) 561-5064

P.A.: JTG
P.M.: TRT
DRAWN BY: Author
PROJECT NO: 1022747


NO.	REVISION	DATE
1	SCHEMATIC BUDGET PRICING SET	11/01/2022
1	PERMIT SET	12/20/2022

Project Status

FIRE ALARM - FIRST FLOOR ENLARGED PLAN C
Granite Run Apartments

SCALE: AS INDICATED
DATE: 11/01/22

Printed: 1/13/2023 12:04:50 PM

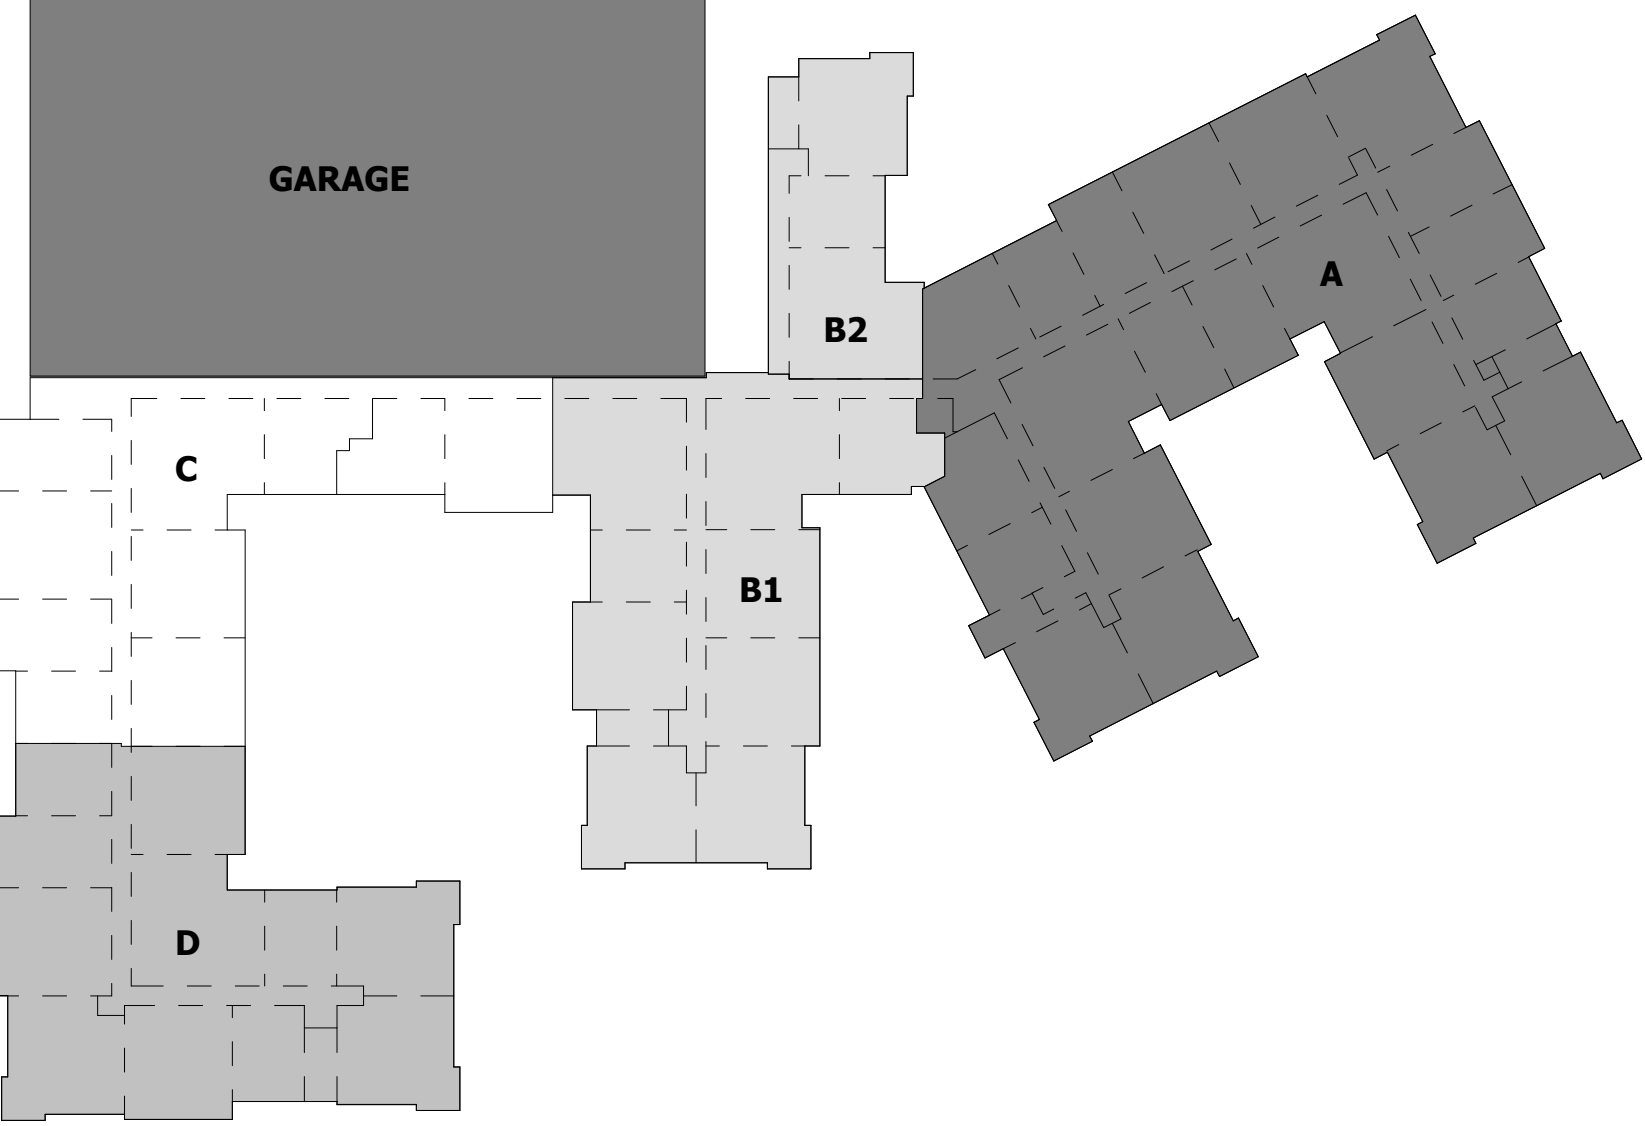

FIRE ALARM GENERAL NOTES

1. REFER TO SHEETS FA0.01 FOR NOTES, SYMBOLS AND ABBREVIATIONS.
2. EC SHALL REFER TO TELECOM, SECURITY & AV DRAWINGS, DETAILS FOR FINAL DEVICE LOCATIONS & RACEWAY REQUIREMENTS.
3. REFER TO MECHANICAL PLANS FOR DUCT SMOKE DETECTOR AND FIRE SMOKE DAMPER LOCATIONS. PROVIDE FA CONNECTION AND WIRE AS REQUIRED.
4. REFER TO FIRE PROTECTION PLANS FOR TAMPER AND FLOW SWITCH LOCATIONS. PROVIDE FA CONNECTION AND WIRE AS REQUIRED.
5. PROVIDE AREA SMOKE DETECTORS IN ELEVATOR LOBBIES AND ELEVATOR MACHINE ROOMS. SMOKE DETECTORS SHALL BE LOCATED ON THE CEILING WITHIN 21 FEET OF THE CENTERLINE OF EACH ELEVATOR DOOR WITHIN THE ELEVATOR BANK UNDER CONTROL OF THE DETECTOR FOR ELEVATOR LOBBIES UP TO 15 FEET IN HEIGHT WITH FLAT AND SMOOTH CEILINGS. FOR HIGHER AND UNEVEN CEILINGS, ADDITIONAL SMOKE DETECTORS MAY BE REQUIRED.
6. MANUAL FIRE ALARM BOXES SHALL BE LOCATED WITHIN 5 FEET OF EACH EXIT DOORWAY ON EACH FLOOR.
7. DUCT SMOKE DETECTORS AND DUCT SMOKE DETECTORS TEST STATIONS LOCATIONS TO BE COORDINATED WITH THE MECHANICAL DRAWINGS.
8. PROVIDE AND INSTALL SYSTEM FIRE ALARM ADDRESSABLE DUCT SMOKE DETECTORS AS INDICATED ON THE MECHANICAL FLOOR PLANS AND RISERS FOR FIRE/SMOKE DAMPERS AND SMOKE DAMPERS. PROVIDE ADDRESSABLE CONTROL RELAY AT EACH DAMPER.
9. PROVIDE 120V EMERGENCY POWER TO ALL FIRE/SMOKE AND SMOKE DAMPERS INDICATED ON THE MECHANICAL DRAWINGS.
10. THESE FIRE ALARM DRAWINGS ARE PERFORMANCE SPECIFICATION ONLY. CONTRACTOR SHALL PROVIDE A COMPLETE SYSTEM DESIGN IN COMPLIANCE WITH NFPA 72, THE IBC, NFPA 101, AND ANY OTHER ENFORCED CODES AND AMENDMENTS, INCLUDING ENGINEERED SIGNED AND SEALED DRAWINGS. POINT TO POINT WIRING WITH PROPOSED CIRCUITING OR CONDUIT ROUTING, ALL APPLICABLE CALCULATIONS, DEVICE MANUFACTURERS AND QUANTITIES, WIRING DIAGRAMS, AND SHOP SUBMITTALS. CONTRACTOR SHALL BE RESPONSIBLE FOR ALL ASSOCIATED PERMITS, INSPECTIONS, AND TESTING. CONSULT LOCAL BUILDING AUTHORITY AND FIRE MARSHAL REGARDING LOCAL AREA'S REQUIREMENTS.



FIRE ALARM - FIRST FLOOR ENLARGED PLAN D

ALL REPORTS, PLANS, SPECIFICATIONS AND COMPUTER FILES RELATING TO THIS PROJECT ARE THE PROPERTY OF THE MARTIN ARCHITECTURAL GROUP. THE MARTIN ARCHITECTURAL GROUP RETAINS ALL COMMON LAW, STATUTE AND OTHER RESERVED RIGHTS INCLUDING THE COPY RIGHT THEREIN. REPRODUCTION OF THE MATERIAL HEREIN OR SUBSTANTIAL USE WITHOUT WRITTEN PERMISSION OF THE MARTIN ARCHITECTURAL GROUP VIOLATES THE COPYRIGHT LAWS OF THE UNITED STATES AND WILL BE SUBJECT TO LEGAL PROSECUTION.



THE MARTIN ARCHITECTURAL GROUP, P.C.
ARCHITECTS AND LAND PLANNERS
A PROFESSIONAL CORPORATION
240 NORTH 22ND STREET, PHILADELPHIA, PA, 19103
P (215) 665-1080 F (215) 561-5064

P.A.: JTG
P.M.: TRT
DRAWN BY: Author
PROJECT NO: 1022747

NO.	REVISION	DATE
1	PERMITS SET	12/20/2022
	SEPARATE BUDGET PRICING SET	

Project Status


FIRE ALARM - FIRST FLOOR ENLARGED PLAN D
Granite Run Apartments

SCALE: AS INDICATED
DATE: 11/01/22

FA2.04D

© The Martin Architectural Group, P.C.

Printed: 1/13/2023 12:05:05 PM

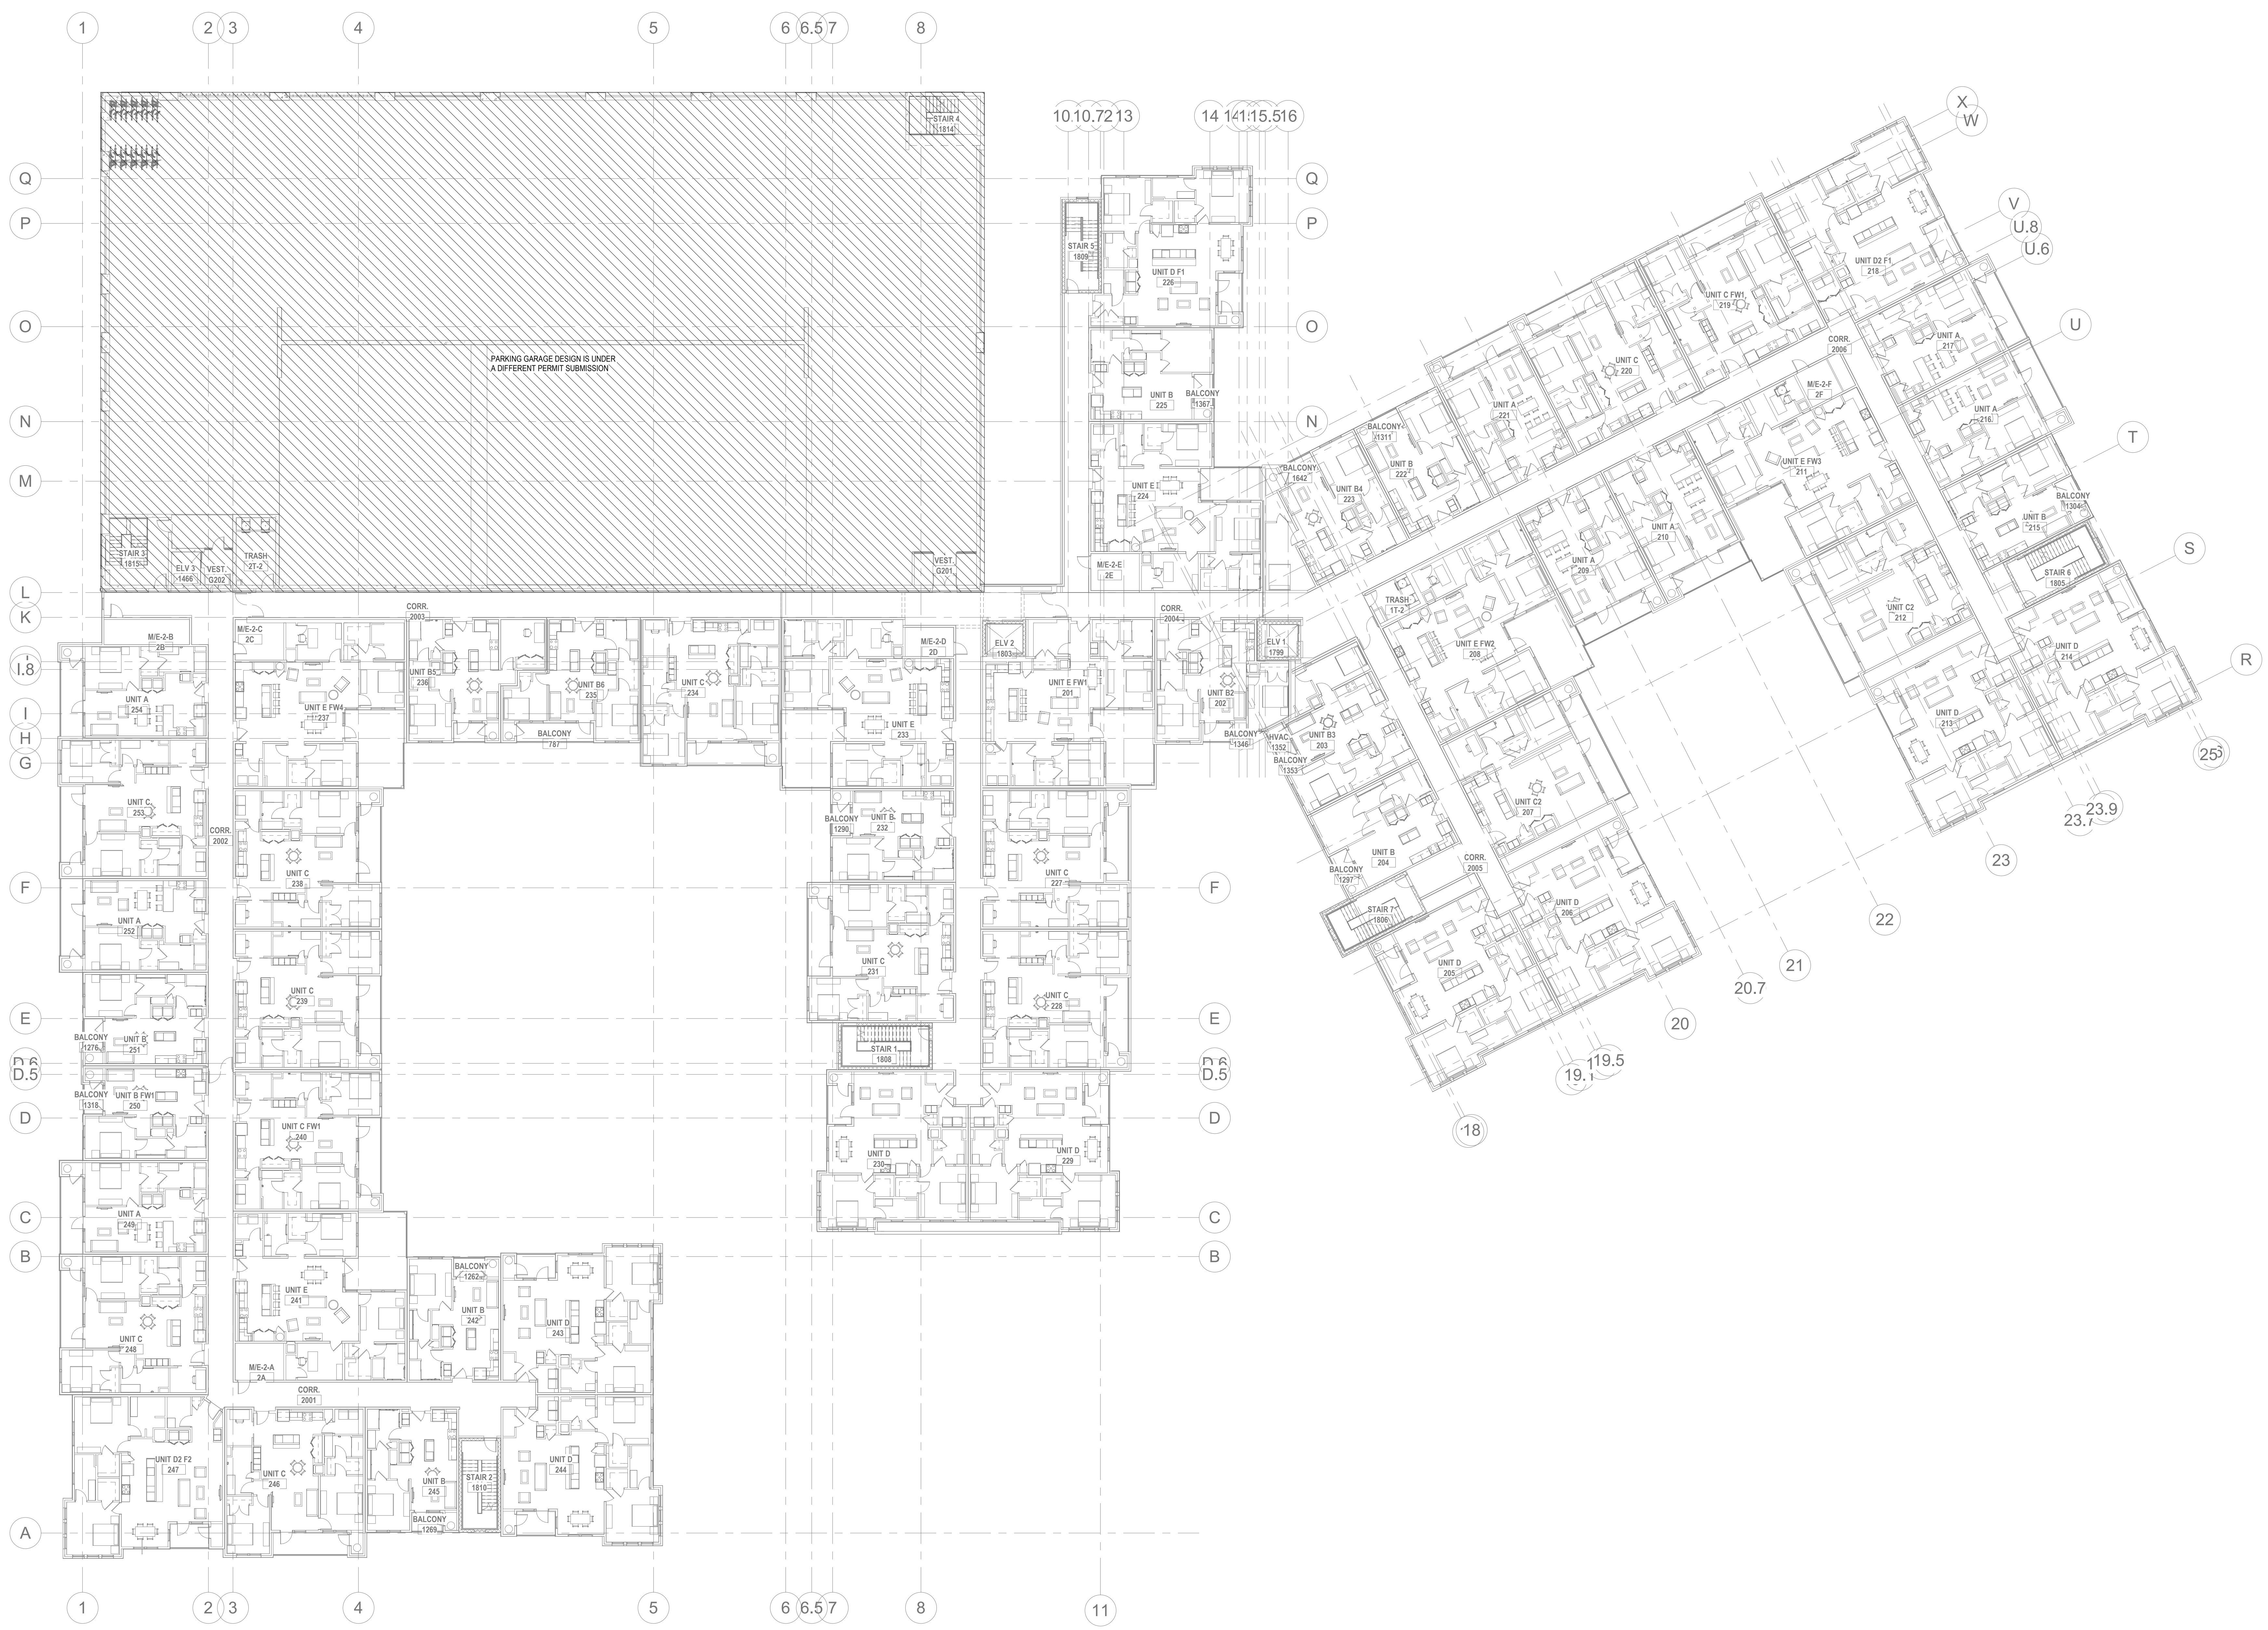

1 FIRE ALARM - SECOND FLOOR PLAN
1/16" = 1'-0"

ALL REPORTS, PLANS, SPECIFICATIONS AND COMPUTER FILES RELATING TO THIS PROJECT ARE THE PROPERTY OF THE MARTIN ARCHITECTURAL GROUP. THE MARTIN ARCHITECTURAL GROUP RETAINS ALL COMMON LAW, STATUTE AND OTHER RESERVED RIGHTS INCLUDING THE COPY RIGHT THEREIN. REPRODUCTION OF THE MATERIAL HEREIN OR SUBSTANTIAL USE WITHOUT WRITTEN PERMISSION OF THE MARTIN ARCHITECTURAL GROUP VIOLATES THE COPYRIGHT LAWS OF THE UNITED STATES AND WILL BE SUBJECT TO LEGAL PROSECUTION.
© The Martin Architectural Group, P.C.



THE MARTIN ARCHITECTURAL GROUP, P.C.
ARCHITECTS AND LAND PLANNERS
A PROFESSIONAL CORPORATION
240 NORTH 22ND STREET, PHILADELPHIA, PA 19103
P (215) 665-1060 F (215) 561-5064

P.A.: JTG
P.M.: TRT
DRAWN BY: Author
PROJECT NO: 1022747


NO.	REVISION	DATE
1	SCHEMATIC BUDGET PRICING SET	11/01/2022
1	PERMIT SET	12/20/2022

Project Status

FIRE ALARM - SECOND FLOOR OVERALL PLAN
Granite Run Apartments
MIDDLETOWN TOWNSHIP, PA

SCALE: AS INDICATED
DATE: 11/01/22

FA2.05
© The Martin Architectural Group, P.C.

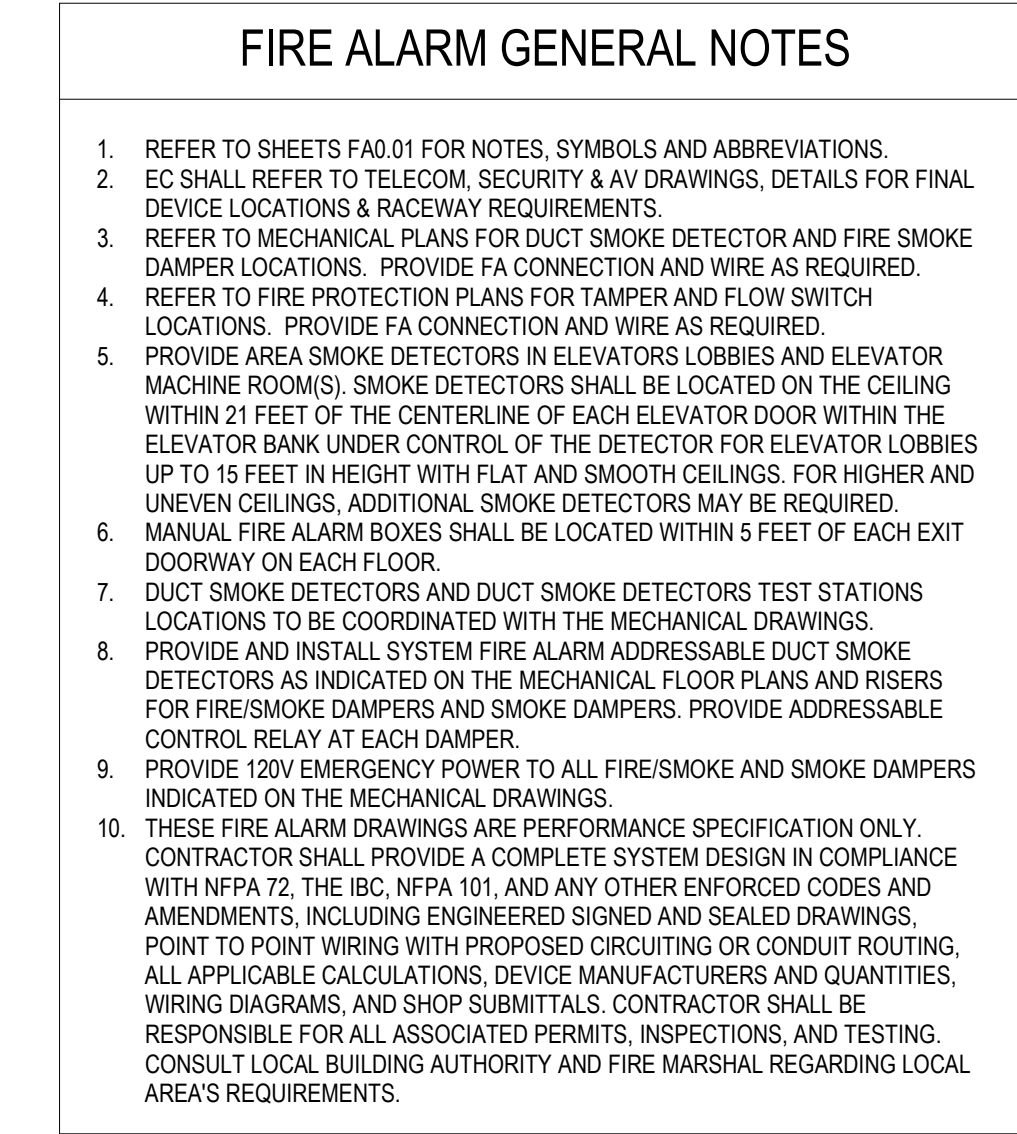

The seal is circular with a double-lined border. The outer ring contains the text "COMMONWEALTH OF PENNSYLVANIA" at the top and "PROFESSIONAL ENGINEER" at the bottom. Inside the ring, there is a shield-shaped emblem. Within the shield, the word "REGISTERED" is at the top, followed by "JAMES T. GARDNER" in the center, and "ENGINEER" below it. A large, stylized signature, which appears to be "James T. Gardner", is written across the entire seal.

THE MARTIN ARCHITECTURAL GROUP, P.C.
ARCHITECTS AND LAND PLANNERS
A PROFESSIONAL CORPORATION

240 NORTH 22ND STREET, PHILADELPHIA, PA, 19103
P (215) 665-1080 F (215) 561-5064


[illegible]

FIRE ALARM - SECOND FLOOR ENLARGED PLAN A

FA2.05A


© The Martin Architectural Group, P.C.

Printed: 1/13/2023 12:05:24 PM

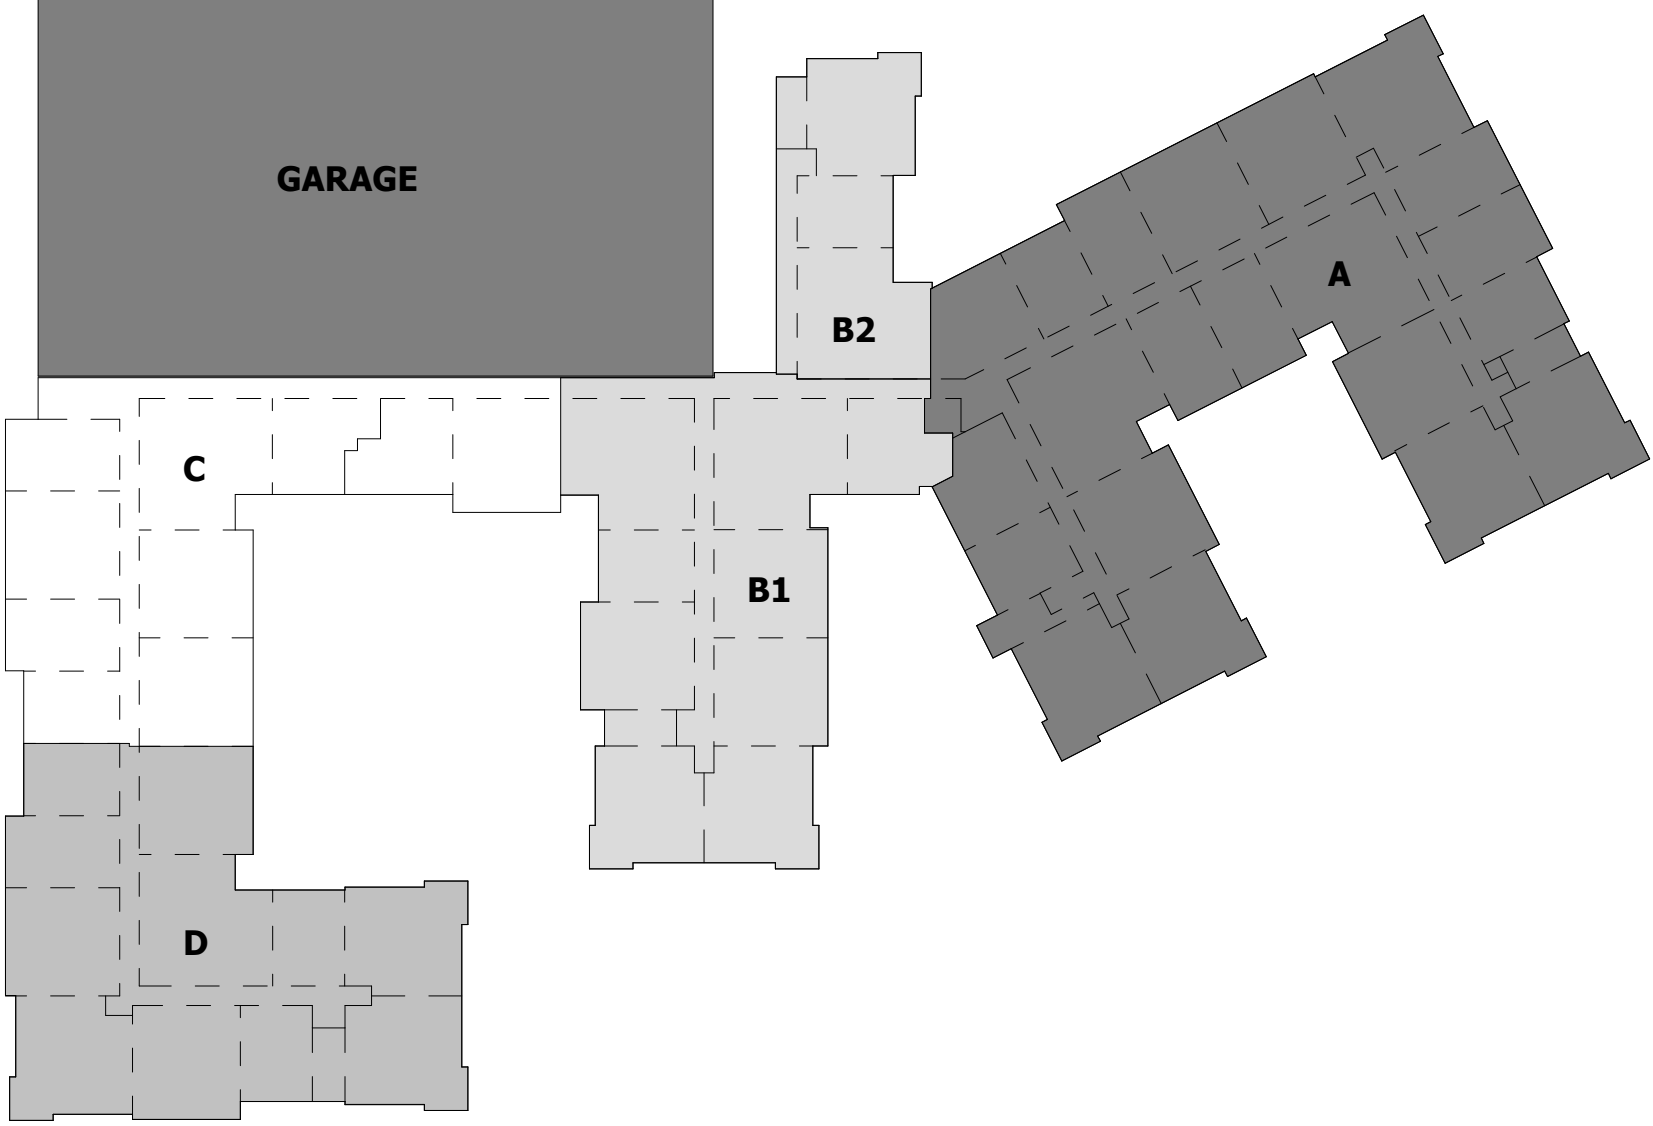


FIRE ALARM GENERAL NOTES

1. REFER TO SHEETS FA0.01 FOR NOTES, SYMBOLS AND ABBREVIATIONS.
2. EC SHALL REFER TO TELECOM, SECURITY & AV DRAWINGS, DETAILS FOR FINAL DEVICE LOCATIONS & RACEWAY REQUIREMENTS.
3. REFER TO MECHANICAL PLANS FOR DUCT SMOKE DETECTOR AND FIRE SMOKE DAMPER LOCATIONS. PROVIDE FA CONNECTION AND WIRE AS REQUIRED.
4. REFER TO FIRE PROTECTION PLANS FOR TAMPER AND FLOW SWITCH LOCATIONS. PROVIDE FA CONNECTION AND WIRE AS REQUIRED.
5. PROVIDE AREA SMOKE DETECTORS IN ELEVATOR LOBBIES AND ELEVATOR MACHINE ROOMS. SMOKE DETECTORS SHALL BE LOCATED ON THE CEILING WITHIN 21 FEET OF THE CENTERLINE OF EACH ELEVATOR DOOR WITHIN THE ELEVATOR BANK UNDER CONTROL OF THE DETECTOR FOR ELEVATOR LOBBIES UP TO 15 FEET IN HEIGHT WITH FLAT AND SMOOTH CEILINGS. FOR HIGHER AND UNEVEN CEILINGS, ADDITIONAL SMOKE DETECTORS MAY BE REQUIRED.
6. MANUAL FIRE ALARM BOXES SHALL BE LOCATED WITHIN 5 FEET OF EACH EXIT DOORWAY ON EACH FLOOR.
7. DUCT SMOKE DETECTORS AND DUCT SMOKE DETECTORS TEST STATIONS LOCATIONS TO BE COORDINATED WITH THE MECHANICAL DRAWINGS.
8. PROVIDE AND INSTALL SYSTEM FIRE ALARM ADDRESSABLE DUCT SMOKE DETECTORS AS INDICATED ON THE MECHANICAL FLOOR PLANS AND RISERS FOR FIRE/SMOKE DAMPERS AND SMOKE DAMPERS. PROVIDE ADDRESSABLE CONTROL RELAY AT EACH DAMPER.
9. PROVIDE 120V EMERGENCY POWER TO ALL FIRE/SMOKE AND SMOKE DAMPERS INDICATED ON THE MECHANICAL DRAWINGS.
10. THESE FIRE ALARM DRAWINGS ARE PERFORMANCE SPECIFICATION ONLY. CONTRACTOR SHALL PROVIDE A COMPLETE SYSTEM DESIGN IN COMPLIANCE WITH NFPA 72, THE IBC, NFPA 101, AND ANY OTHER ENFORCED CODES AND AMENDMENTS, INCLUDING ENGINEERED SIGNED AND SEALED DRAWINGS, POINT TO POINT WIRING WITH PROPOSED CIRCUITING OR CONDUIT ROUTING, ALL APPLICABLE CALCULATIONS, DEVICE MANUFACTURERS AND QUANTITIES, WIRING DIAGRAMS, AND SHOP SUBMITTALS. CONTRACTOR SHALL BE RESPONSIBLE FOR ALL ASSOCIATED PERMITS, INSPECTIONS, AND TESTING. CONSULT LOCAL BUILDING AUTHORITY AND FIRE MARSHAL REGARDING LOCAL AREA'S REQUIREMENTS.

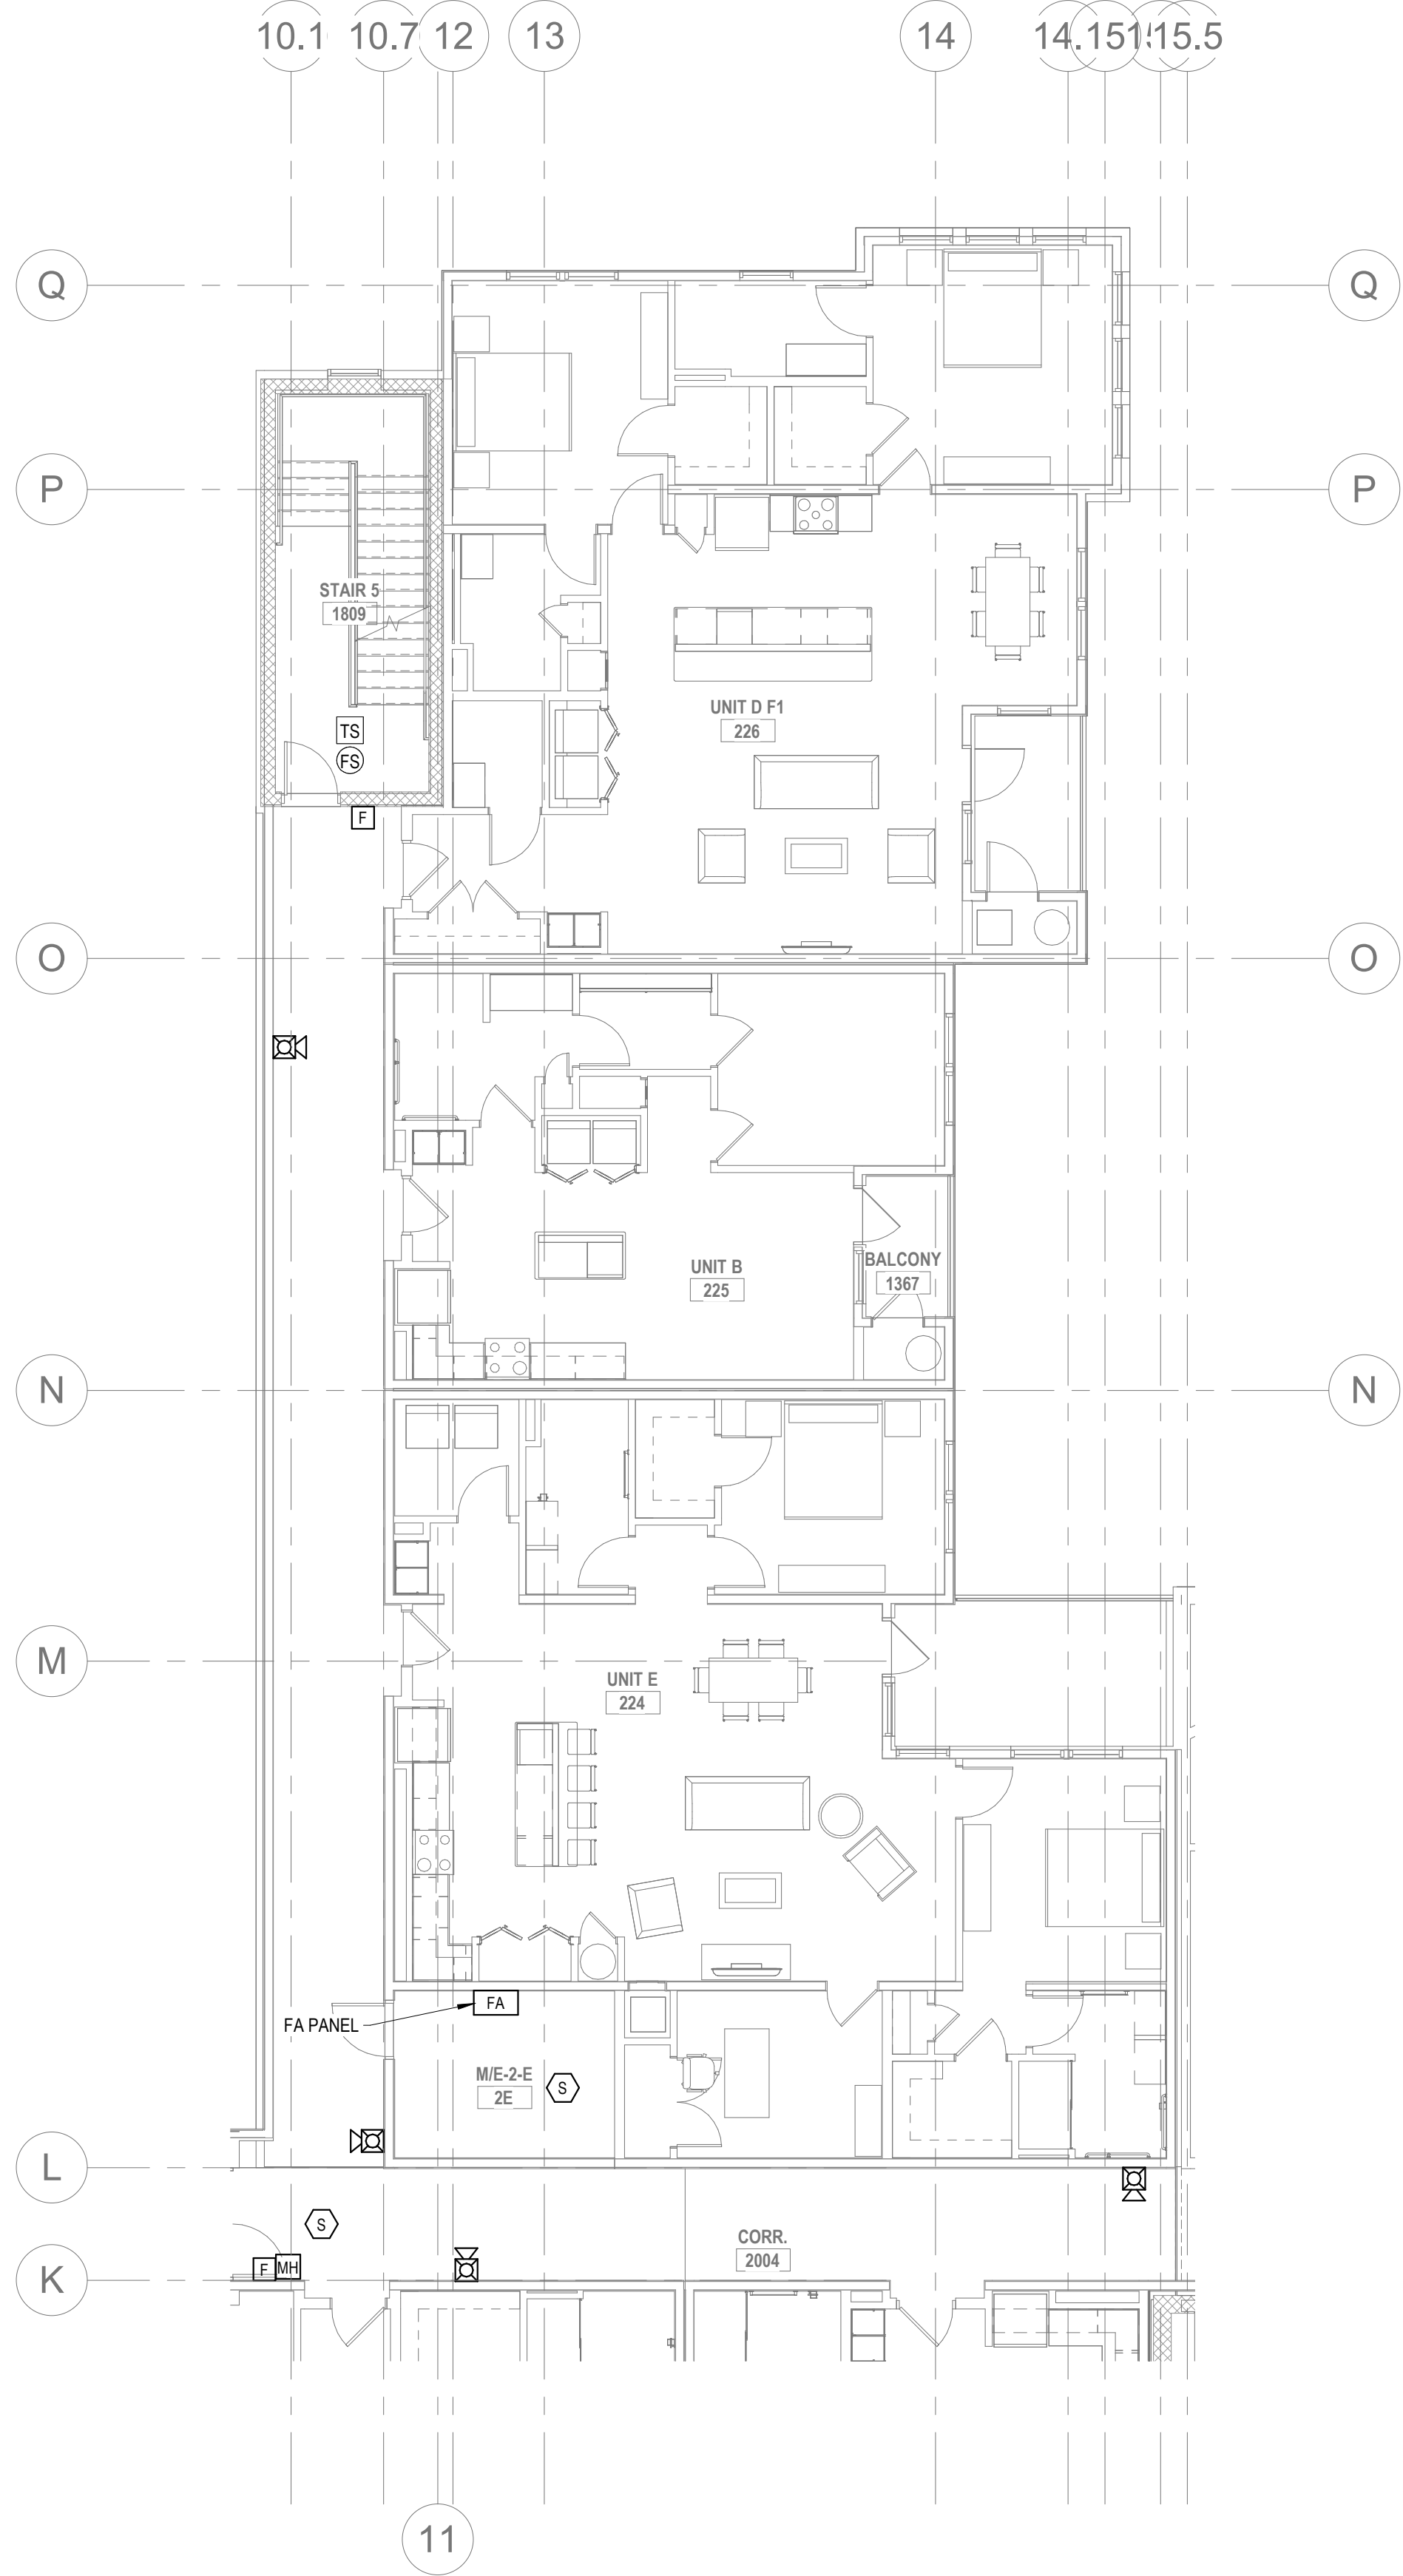

4 FIRE ALARM - SECOND FLOOR ENLARGED PLAN B2
FA2.05B 1/8" = 1'-0"

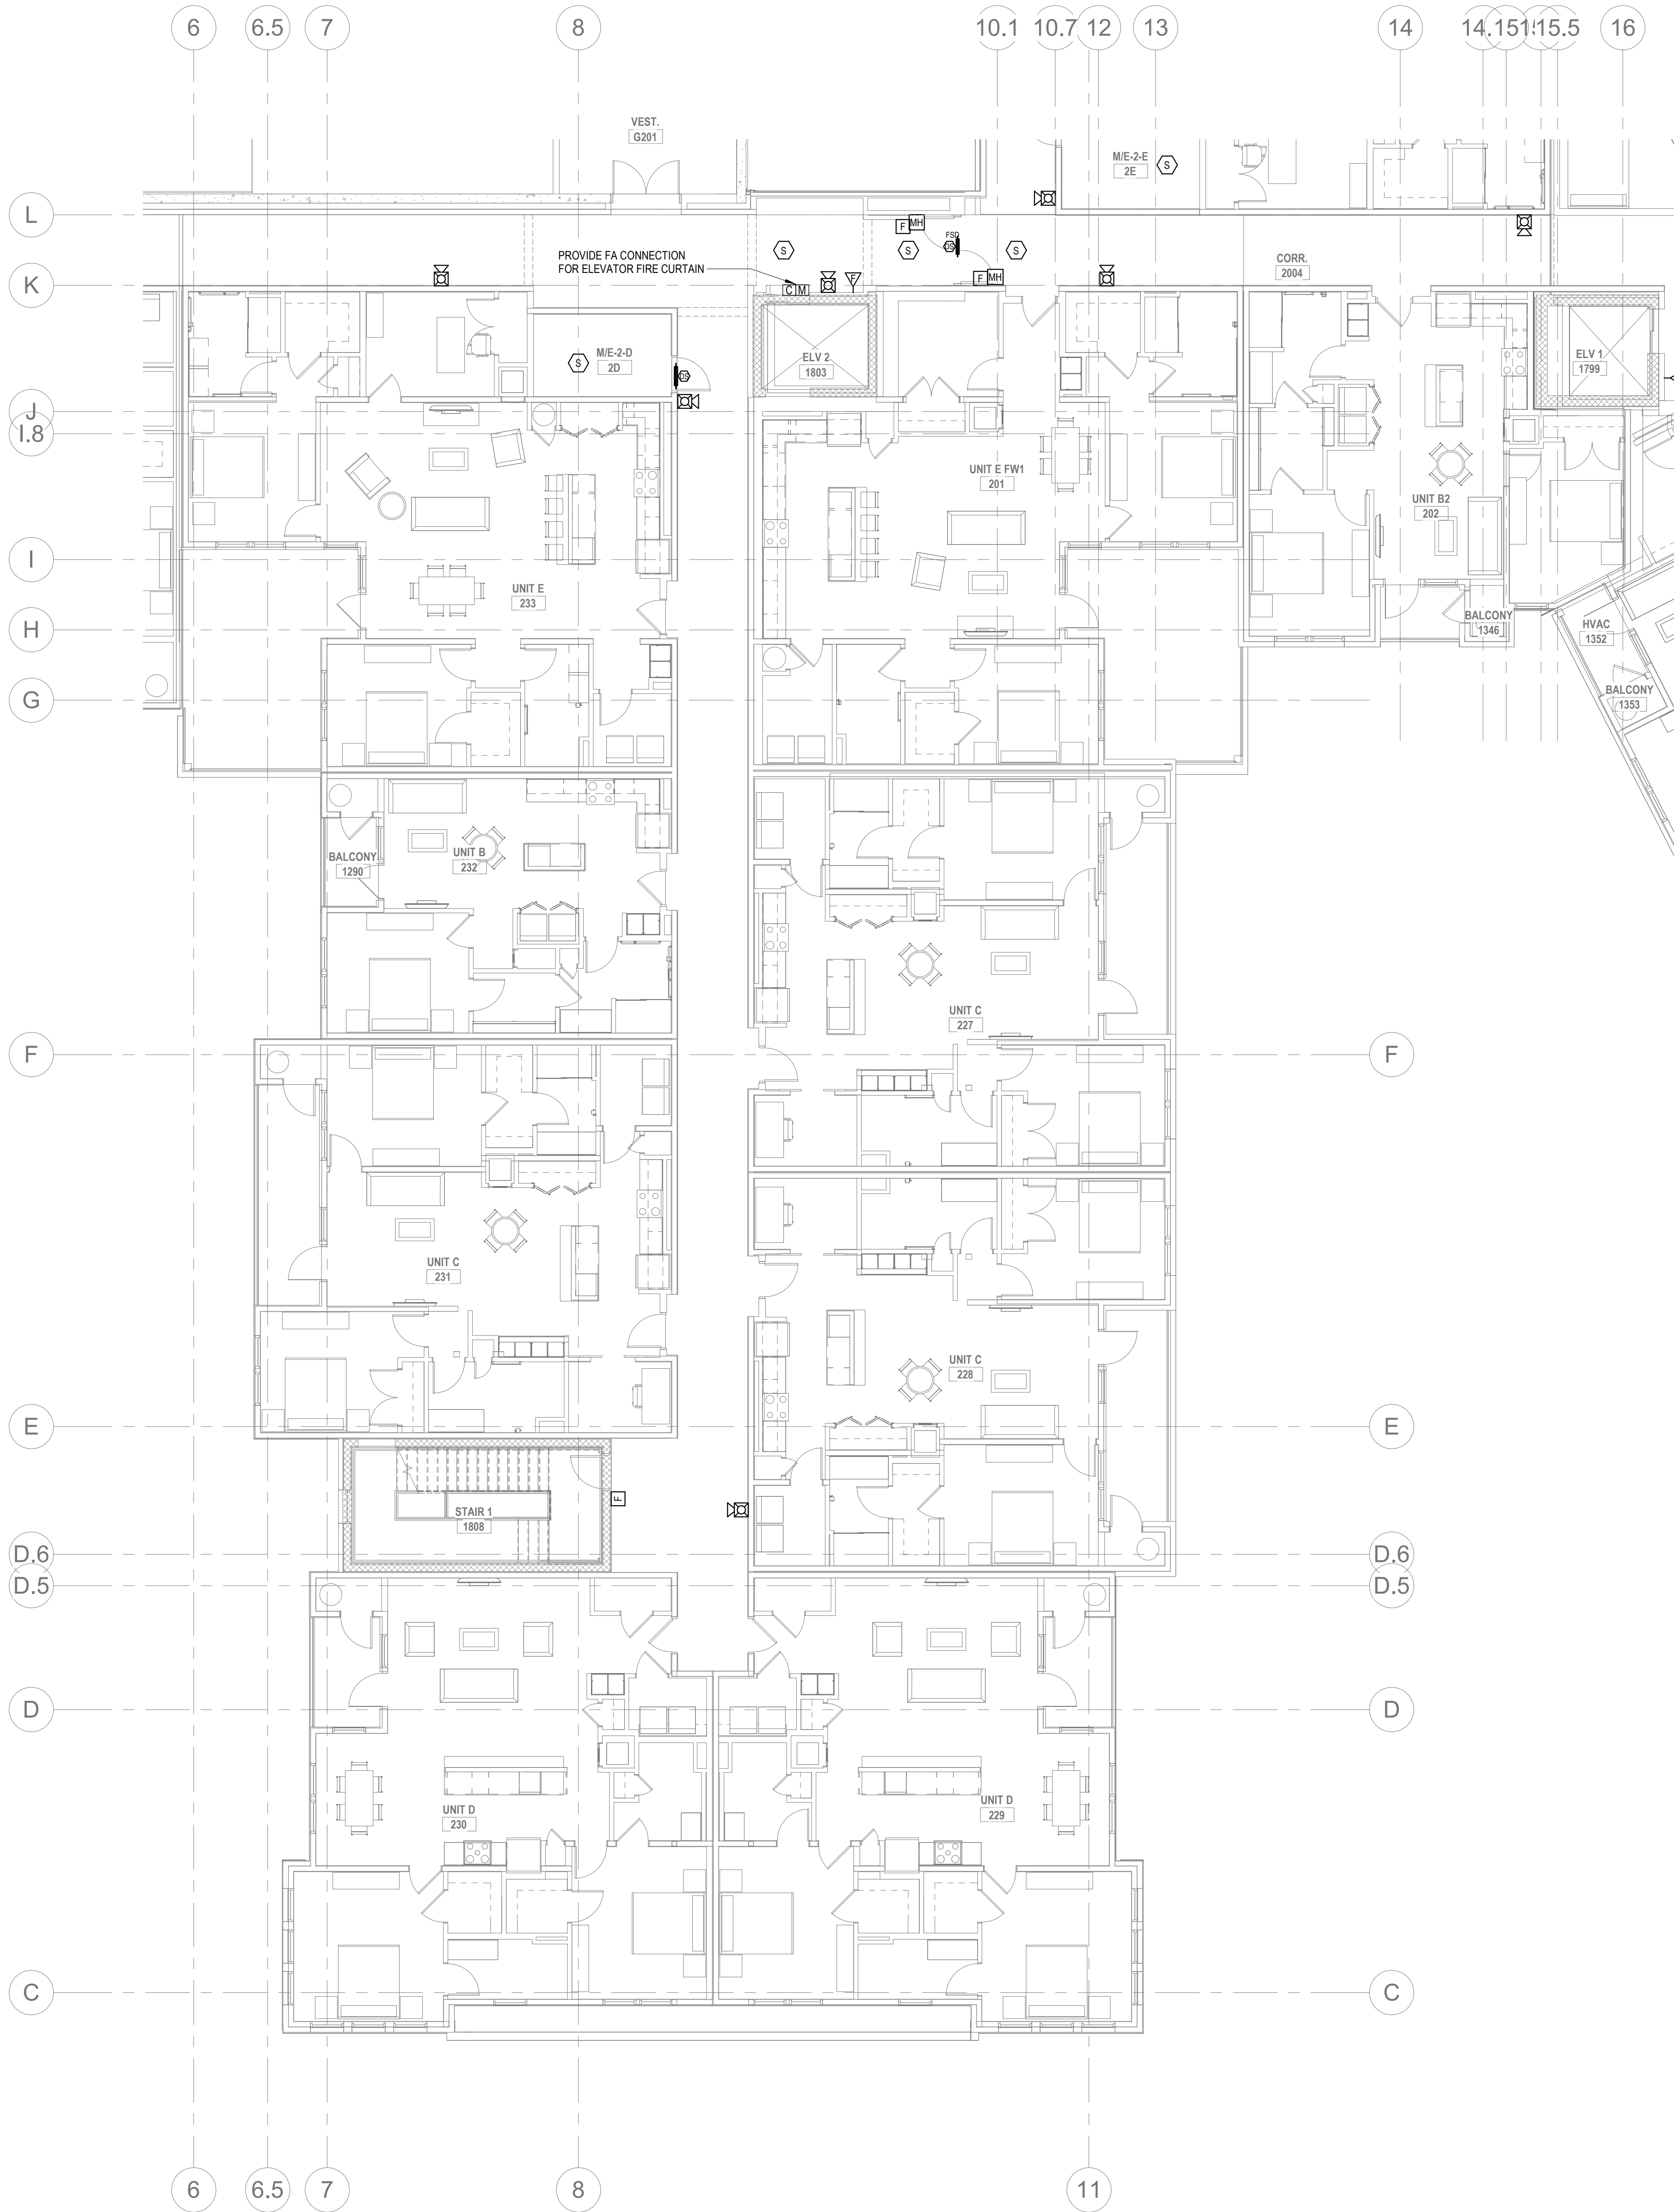

3 FIRE ALARM - SECOND FLOOR ENLARGED PLAN B1
FA2.05B 1/8" = 1'-0"

ALL REPORTS, PLANS, SPECIFICATIONS AND COMPUTER FILES RELATING TO THIS PROJECT ARE THE PROPERTY OF THE MARTIN ARCHITECTURAL GROUP. THE MARTIN ARCHITECTURAL GROUP RETAINS ALL COMMON LAW, STATUTE AND OTHER RESERVED RIGHTS INCLUDING THE COPY RIGHT THEREIN. REPRODUCTION OF THE MATERIAL HEREIN OR SUBSTANTIAL USE WITHOUT WRITTEN PERMISSION OF THE MARTIN ARCHITECTURAL GROUP VIOLATES THE COPYRIGHT LAWS OF THE UNITED STATES AND WILL BE SUBJECT TO LEGAL PROSECUTION.
© The Martin Architectural Group, P.C.



THE MARTIN ARCHITECTURAL GROUP, P.C.
ARCHITECTS AND LAND PLANNERS
A PROFESSIONAL CORPORATION
240 NORTH 22ND STREET, PHILADELPHIA, PA 19103
P (215) 665-1060 F (215) 561-5064

P.A.: JTG
P.M.: TRT
DRAWN BY: Author
PROJECT NO: 1022747

NO.	REVISION	DATE
1	SCHEMATIC BUDGET PRICING SET	11/01/2022
1	PERMIT SET	12/20/2022


Project Status

FIRE ALARM - SECOND FLOOR ENLARGED PLAN B
Granite Run Apartments
MIDDLETOWN TOWNSHIP, PA

SCALE: AS INDICATED
DATE: 11/01/22

FA2.05B
© The Martin Architectural Group, P.C.

Printed: 1/13/2023 12:05:30 PM

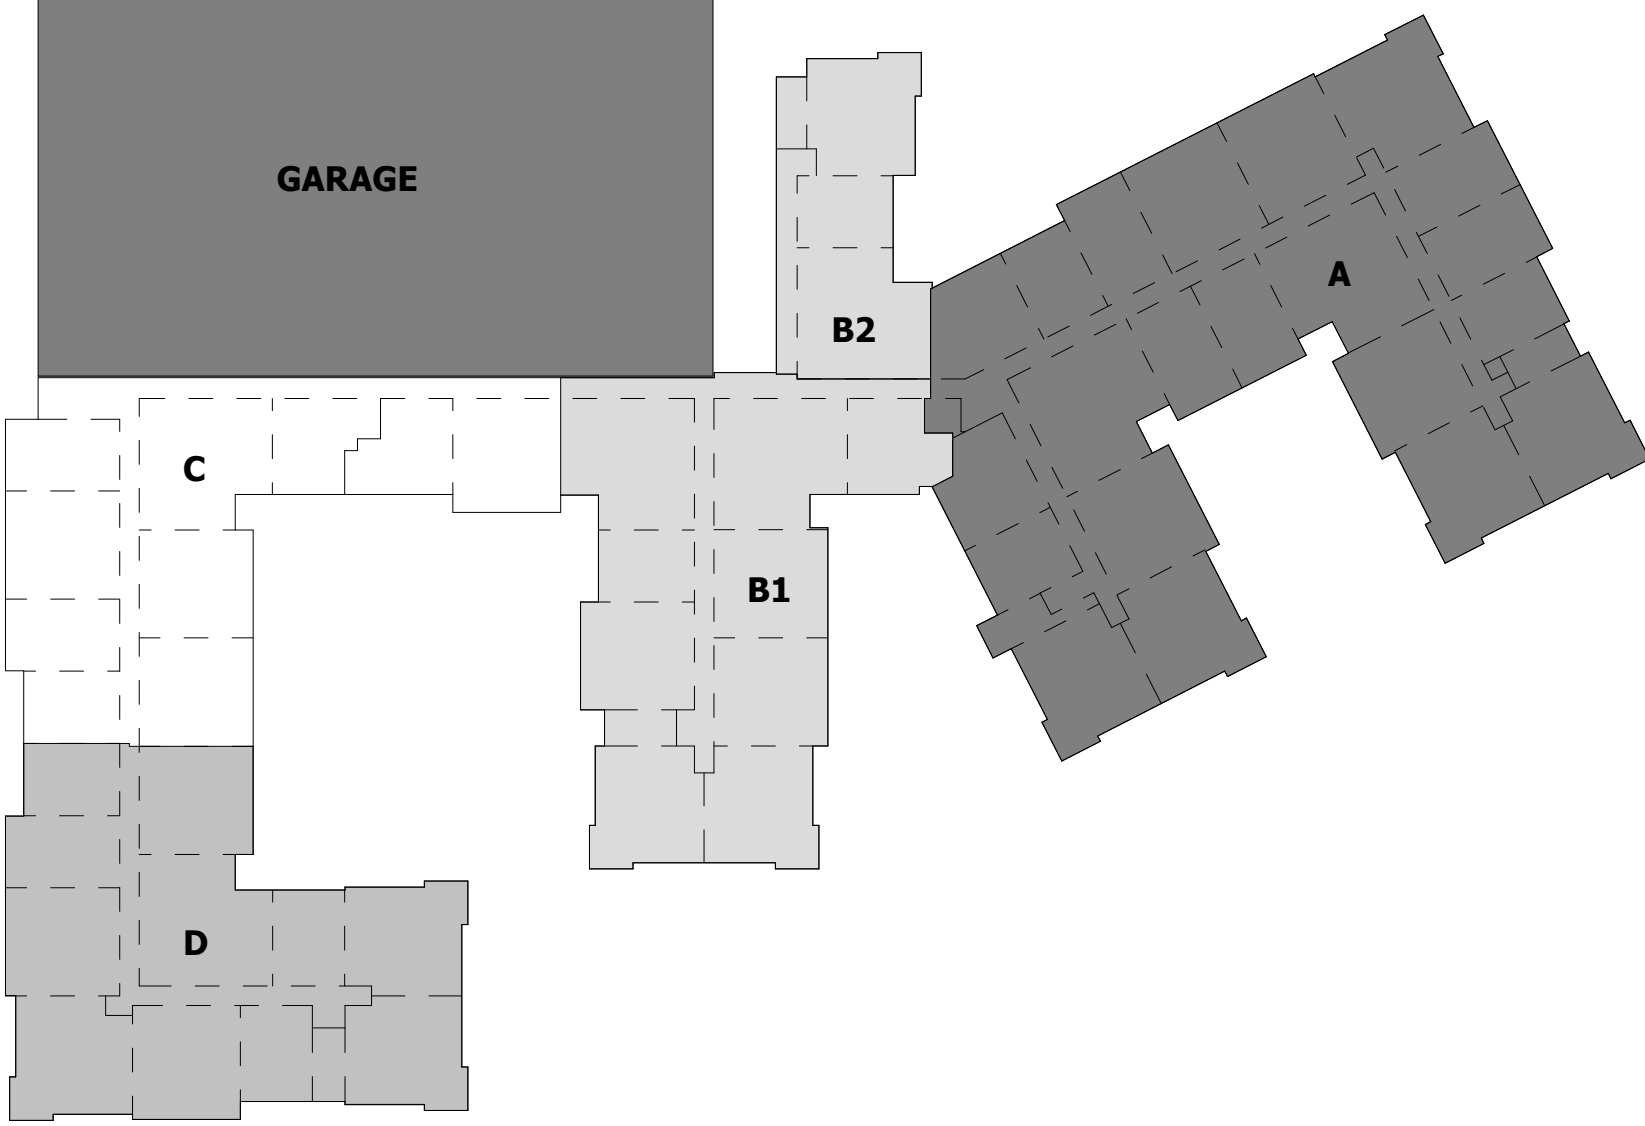

FIRE ALARM GENERAL NOTES

1. REFER TO SHEETS FA0.01 FOR NOTES, SYMBOLS AND ABBREVIATIONS.
2. EC SHALL REFER TO TELECOM, SECURITY & AV DRAWINGS, DETAILS FOR FINAL DEVICE LOCATIONS & RACEWAY REQUIREMENTS.
3. REFER TO MECHANICAL PLANS FOR DUCT SMOKE DETECTOR AND FIRE SMOKE DAMPER LOCATIONS. PROVIDE FA CONNECTION AND WIRE AS REQUIRED.
4. REFER TO FIRE PROTECTION PLANS FOR TAMPER AND FLOW SWITCH LOCATIONS. PROVIDE FA CONNECTION AND WIRE AS REQUIRED.
5. PROVIDE AREA SMOKE DETECTORS IN ELEVATOR LOBBIES AND ELEVATOR MACHINE ROOMS. SMOKE DETECTORS SHALL BE LOCATED ON THE CEILING WITHIN 21 FEET OF THE CENTERLINE OF EACH ELEVATOR DOOR WITHIN THE ELEVATOR BANK UNDER CONTROL OF THE DETECTOR FOR ELEVATOR LOBBIES UP TO 15 FEET IN HEIGHT WITH FLAT AND SMOOTH CEILINGS. FOR HIGHER AND UNEVEN CEILINGS, ADDITIONAL SMOKE DETECTORS MAY BE REQUIRED.
6. MANUAL FIRE ALARM BOXES SHALL BE LOCATED WITHIN 5 FEET OF EACH EXIT DOORWAY ON EACH FLOOR.
7. DUCT SMOKE DETECTORS AND DUCT SMOKE DETECTORS TEST STATIONS LOCATIONS TO BE COORDINATED WITH THE MECHANICAL DRAWINGS.
8. PROVIDE AND INSTALL SYSTEM FIRE ALARM ADDRESSABLE DUCT SMOKE DETECTORS AS INDICATED ON THE MECHANICAL FLOOR PLANS AND RISERS FOR FIRE/SMOKE DAMPERS AND SMOKE DAMPERS. PROVIDE ADDRESSABLE CONTROL RELAY AT EACH DAMPER.
9. PROVIDE 120V EMERGENCY POWER TO ALL FIRE/SMOKE AND SMOKE DAMPERS INDICATED ON THE MECHANICAL DRAWINGS.
10. THESE FIRE ALARM DRAWINGS ARE PERFORMANCE SPECIFICATION ONLY. CONTRACTOR SHALL PROVIDE A COMPLETE SYSTEM DESIGN IN COMPLIANCE WITH NFPA 72, THE IBC, NFPA 101, AND ANY OTHER ENFORCED CODES AND AMENDMENTS, INCLUDING ENGINEERED SIGNED AND SEALED DRAWINGS, POINT TO POINT WIRING WITH PROPOSED CIRCUITING OR CONDUIT ROUTING, ALL APPLICABLE CALCULATIONS, DEVICE MANUFACTURERS AND QUANTITIES, WIRING DIAGRAMS, AND SHOP SUBMITTALS. CONTRACTOR SHALL BE RESPONSIBLE FOR ALL ASSOCIATED PERMITS, INSPECTIONS, AND TESTING. CONSULT LOCAL BUILDING AUTHORITY AND FIRE MARSHAL REGARDING LOCAL AREA'S REQUIREMENTS.



2 FIRE ALARM - SECOND FLOOR ENLARGED PLAN C
1/8" = 1'-0"

ALL REPORTS, PLANS, SPECIFICATIONS AND COMPUTER FILES RELATING TO THIS PROJECT ARE THE PROPERTY OF THE MARTIN ARCHITECTURAL GROUP. THE MARTIN ARCHITECTURAL GROUP RETAINS ALL COMMON LAW, STATUTE AND OTHER RESERVED RIGHTS INCLUDING THE COPY RIGHT THERE TO. REPRODUCTION OF THE MATERIAL HEREIN OR SUBSTANTIAL USE WITHOUT WRITTEN PERMISSION OF THE MARTIN ARCHITECTURAL GROUP VIOLATES THE COPYRIGHT LAWS OF THE UNITED STATES AND WILL BE SUBJECT TO LEGAL PROSECUTION.
© The Martin Architectural Group, P.C.



THE MARTIN ARCHITECTURAL GROUP, P.C.
ARCHITECTS AND LAND PLANNERS
A PROFESSIONAL CORPORATION
240 NORTH 22ND STREET, PHILADELPHIA, PA, 19103
P (215) 665-1060 F (215) 561-5064

P.A.: JTG
P.M.: TRT
DRAWN BY: Author
PROJECT NO: 1022747

NO.	REVISION	DATE
1	SCHEMATIC BUDGET PRICING SET	11/01/2022
	PERMIT SET	12/20/2022


Project Status

FIRE ALARM - SECOND FLOOR ENLARGED PLAN C
Granite Run Apartments

MIDDLETOWN TOWNSHIP, PA

SCALE: AS INDICATED
DATE: 11/01/2022

Printed: 1/13/2023 12:05:37 PM

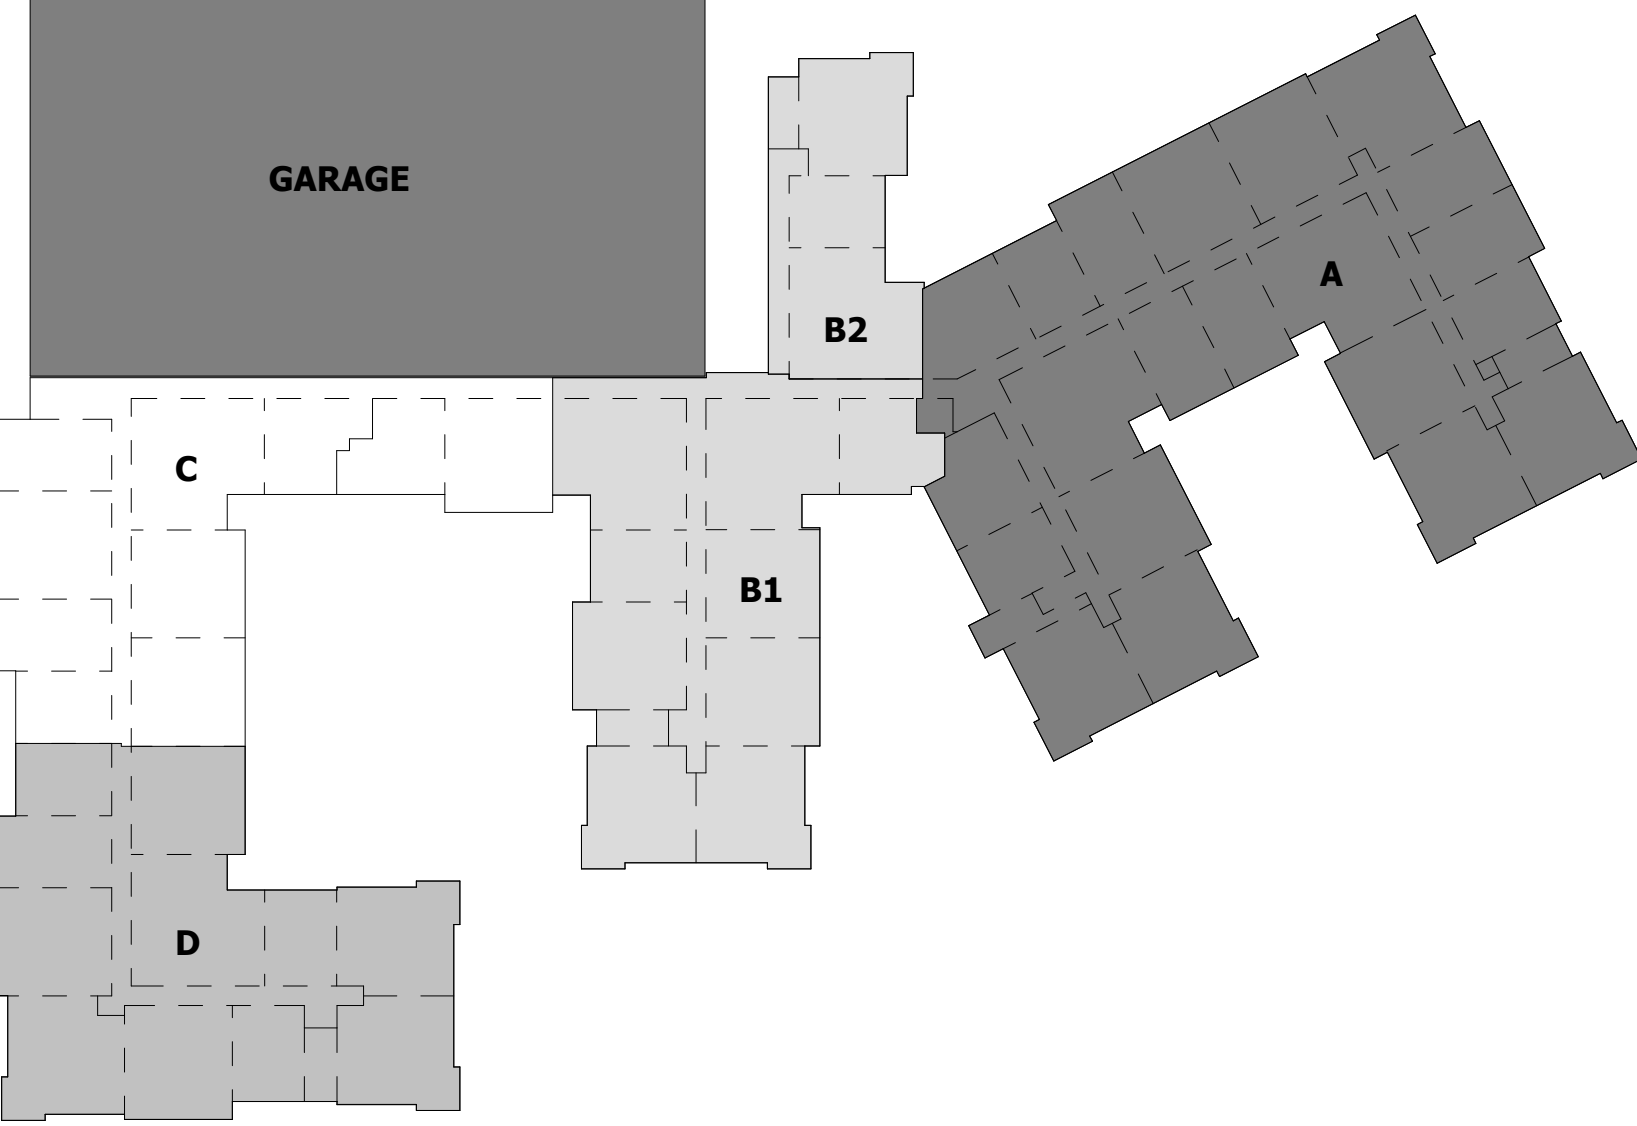

FIRE ALARM GENERAL NOTES

1. REFER TO SHEETS FA0.01 FOR NOTES, SYMBOLS AND ABBREVIATIONS.
2. EC SHALL REFER TO TELECOM, SECURITY & AV DRAWINGS, DETAILS FOR FINAL DEVICE LOCATIONS & RACEWAY REQUIREMENTS.
3. REFER TO MECHANICAL PLANS FOR DUCT SMOKE DETECTOR AND FIRE SMOKE DAMPER LOCATIONS. PROVIDE FA CONNECTION AND WIRE AS REQUIRED.
4. REFER TO FIRE PROTECTION PLANS FOR TAMPER AND FLOW SWITCH LOCATIONS. PROVIDE FA CONNECTION AND WIRE AS REQUIRED.
5. PROVIDE AREA SMOKE DETECTORS IN ELEVATORS LOBBIES AND ELEVATOR MACHINE ROOM(S). SMOKE DETECTORS SHALL BE LOCATED ON THE CEILING WITHIN 21 FEET OF THE CENTERLINE OF EACH ELEVATOR DOOR WITHIN THE ELEVATOR BANK UNDER CONTROL OF THE DETECTOR FOR ELEVATOR LOBBIES UP TO 15 FEET IN HEIGHT WITH FLAT AND SMOOTH CEILINGS. FOR HIGHER AND UNEVEN CEILINGS, ADDITIONAL SMOKE DETECTORS MAY BE REQUIRED.
6. MANUAL FIRE ALARM BOXES SHALL BE LOCATED WITHIN 5 FEET OF EACH EXIT DOORWAY ON EACH FLOOR.
7. DUCT SMOKE DETECTORS AND DUCT SMOKE DETECTORS TEST STATIONS LOCATIONS TO BE COORDINATED WITH THE MECHANICAL DRAWINGS.
8. PROVIDE AND INSTALL SYSTEM FIRE ALARM ADDRESSABLE DUCT SMOKE DETECTORS AS INDICATED ON THE MECHANICAL FLOOR PLANS AND RISERS FOR FIRE/SMOKE DAMPERS AND SMOKE DAMPERS. PROVIDE ADDRESSABLE CONTROL RELAY AT EACH DAMPER.
9. PROVIDE 120V EMERGENCY POWER TO ALL FIRE/SMOKE AND SMOKE DAMPERS INDICATED ON THE MECHANICAL DRAWINGS.
10. THESE FIRE ALARM DRAWINGS ARE PERFORMANCE SPECIFICATION ONLY. CONTRACTOR SHALL PROVIDE A COMPLETE SYSTEM DESIGN IN COMPLIANCE WITH NFPA 72, THE IBC, NFPA 101, AND ANY OTHER ENFORCED CODES AND AMENDMENTS, INCLUDING ENGINEERED SIGNED AND SEALED DRAWINGS. POINT TO POINT WIRING WITH PROPOSED CIRCUITING OR CONDUIT ROUTING. ALL APPLICABLE CALCULATIONS, DEVICE MANUFACTURERS AND QUANTITIES, WIRING DIAGRAMS, AND SHOP SUBMITTALS. CONTRACTOR SHALL BE RESPONSIBLE FOR ALL ASSOCIATED PERMITS, INSPECTIONS, AND TESTING. CONSULT LOCAL BUILDING AUTHORITY AND FIRE MARSHAL REGARDING LOCAL AREA'S REQUIREMENTS.



2 FIRE ALARM - SECOND FLOOR ENLARGED PLAN D
FA2.05D
1/8" = 1'-0"

ALL REPORTS, PLANS, SPECIFICATIONS AND COMPUTER FILES RELATING TO THIS PROJECT ARE THE PROPERTY OF THE MARTIN ARCHITECTURAL GROUP. THE MARTIN ARCHITECTURAL GROUP RETAINS ALL COMMON LAW, STATUTE AND OTHER RESERVED RIGHTS INCLUDING THE COPY RIGHT THERE TO. REPRODUCTION OF THE MATERIAL HEREIN OR SUBSTANTIAL USE WITHOUT WRITTEN PERMISSION OF THE MARTIN ARCHITECTURAL GROUP VIOLATES THE COPYRIGHT LAWS OF THE UNITED STATES AND WILL BE SUBJECT TO LEGAL PROSECUTION.
© The Martin Architectural Group, P.C.



THE MARTIN ARCHITECTURAL GROUP, P.C.
ARCHITECTS AND LAND PLANNERS
A PROFESSIONAL CORPORATION
240 NORTH 22ND STREET, PHILADELPHIA, PA, 19103
P (215) 665-1060 F (215) 561-5064

P.A.: JTG
P.M.: TRT
DRAWN BY: Author
PROJECT NO: 1022747

NO.	REVISION	DATE
1	SEPARATE BUDGET PRICING SET PERMIT SET	11/01/2022 12/20/2022

Project Status

FIRE ALARM - SECOND FLOOR ENLARGED PLAN D
Granite Run Apartments

MIDDLETOWN TOWNSHIP, PA


SCALE: AS INDICATED
DATE: 11/01/22

Printed: 1/13/2023 12:05:52 PM



2 FIRE ALARM - THIRD FLOOR PLAN
1/16" = 1'-0"

ALL REPORTS, PLANS, SPECIFICATIONS AND COMPUTER FILES RELATING TO THIS PROJECT ARE THE PROPERTY OF THE MARTIN ARCHITECTURAL GROUP. THE MARTIN ARCHITECTURAL GROUP RETAINS ALL COMMON LAW, STATUTE AND OTHER RESERVED RIGHTS INCLUDING THE COPY RIGHT THEREIN. REPRODUCTION OF THE MATERIAL HEREIN OR SUBSTANTIAL USE WITHOUT WRITTEN PERMISSION OF THE MARTIN ARCHITECTURAL GROUP VIOLATES THE COPYRIGHT LAWS OF THE UNITED STATES AND WILL BE SUBJECT TO LEGAL PROSECUTION.
© The Martin Architectural Group, P.C.

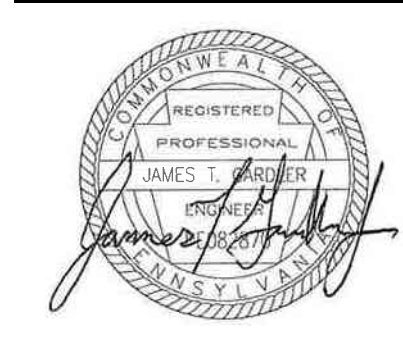

THE MARTIN ARCHITECTURAL GROUP, P.C.
ARCHITECTS AND LAND PLANNERS
A PROFESSIONAL CORPORATION
240 NORTH 22ND STREET, PHILADELPHIA, PA. 19103
P (215) 665-1060 F (215) 561-5064

P.A.: JTG
P.M.: TRT
DRAWN BY: Author
PROJECT NO: 1022747


NO.	REVISION	DATE
1	SCHEMATIC BUDGET PRICING SET	11/01/2022
1	PERMIT SET	12/20/2022

Project Status

FIRE ALARM - THIRD FLOOR OVERALL PLAN
Granite Run Apartments
MIDDLETOWN TOWNSHIP, PA

SCALE: AS INDICATED
DATE: 11/01/22

FA2.06
© The Martin Architectural Group, P.C.

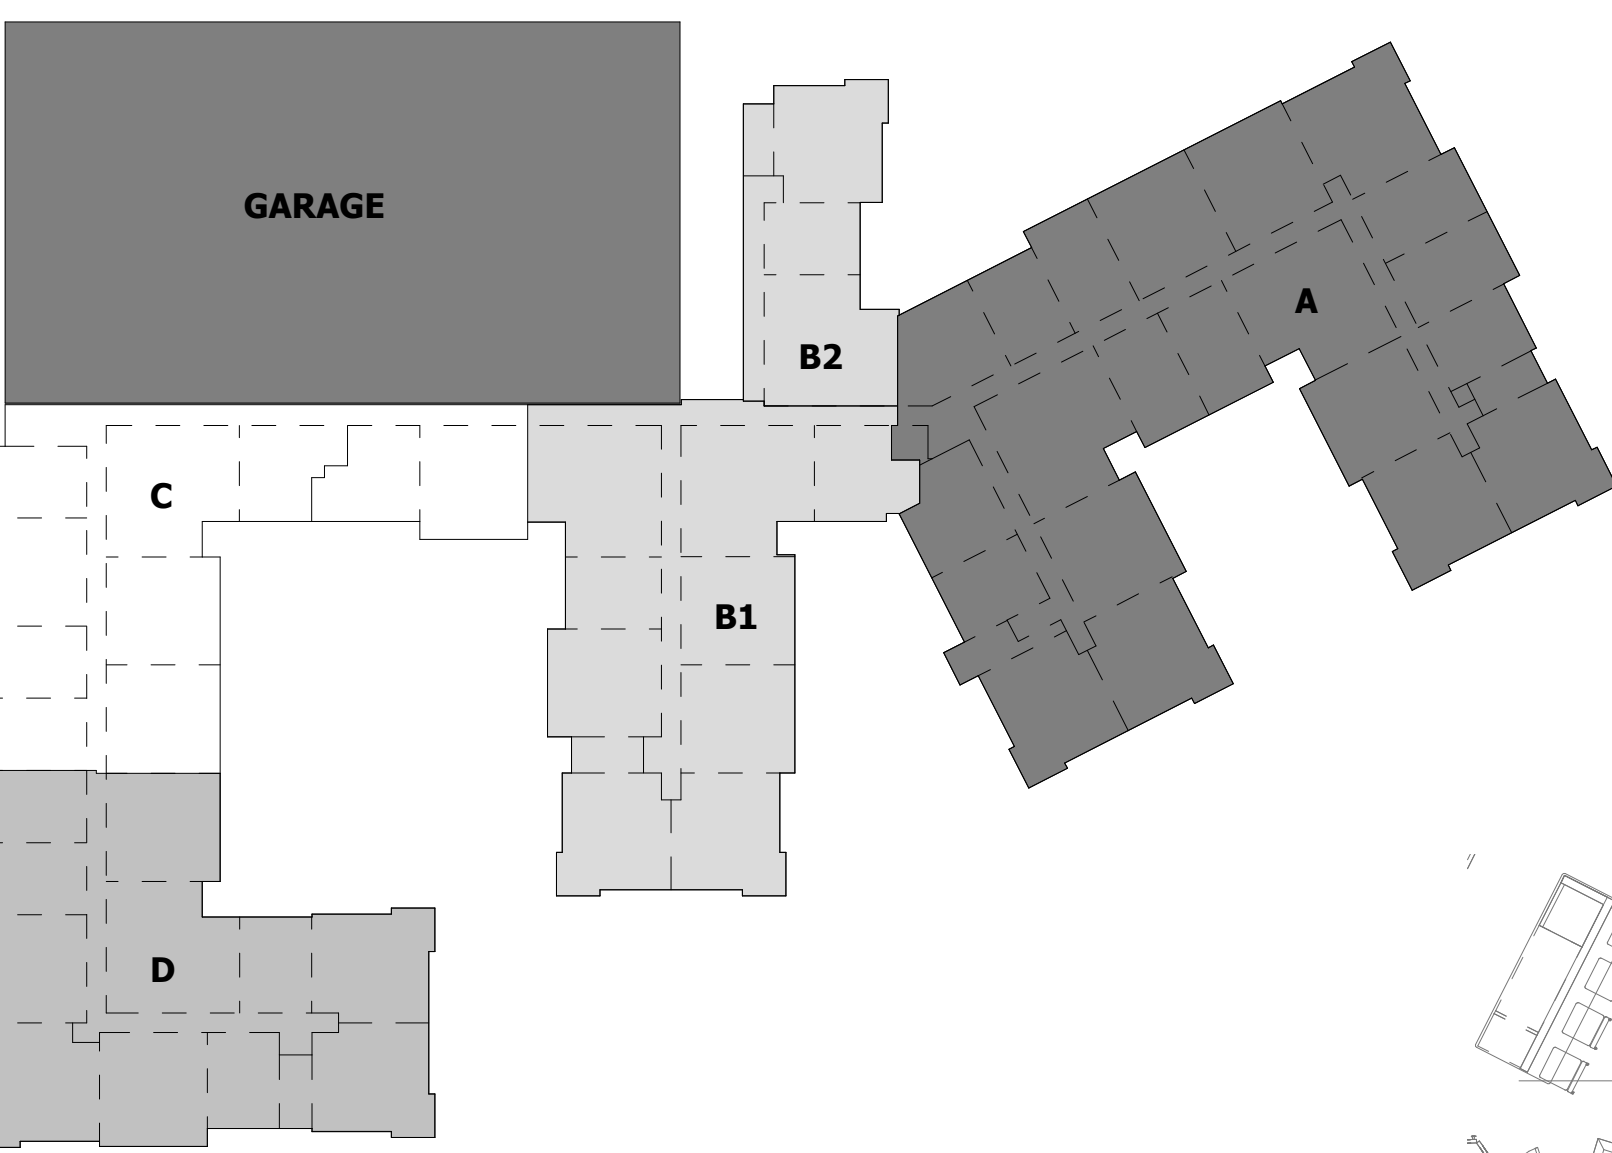


- FIRE ALARM GENERAL NOTES**
1. REFER TO SHEETS FA0.01 FOR NOTES, SYMBOLS AND ABBREVIATIONS.
 2. EC SHALL REFER TO TELECOM, SECURITY & AV DRAWINGS, DETAILS FOR FINAL DEVICE LOCATIONS & RACEWAY REQUIREMENTS.
 3. REFER TO MECHANICAL PLANS FOR DUCT SMOKE DETECTOR AND FIRE SMOKE DAMPER LOCATIONS. PROVIDE FA CONNECTION AND WIRE AS REQUIRED.
 4. REFER TO FIRE PROTECTION PLANS FOR TAMPER AND FLOW SWITCH LOCATIONS. PROVIDE FA CONNECTION AND WIRE AS REQUIRED.
 5. PROVIDE AREA SMOKE DETECTORS IN ELEVATOR LOBBIES AND ELEVATOR MACHINE ROOMS. SMOKE DETECTORS SHALL BE LOCATED ON THE CEILING WITHIN 21 FEET OF THE CENTERLINE OF EACH ELEVATOR DOOR WITHIN THE ELEVATOR BANK UNDER CONTROL OF THE DETECTOR FOR ELEVATOR LOBBIES UP TO 15 FEET IN HEIGHT WITH FLAT AND SMOOTH CEILINGS. FOR HIGHER AND UNEVEN CEILINGS, ADDITIONAL SMOKE DETECTORS MAY BE REQUIRED.
 6. MANUAL FIRE ALARM BOXES SHALL BE LOCATED WITHIN 5 FEET OF EACH EXIT DOORWAY ON EACH FLOOR.
 7. DUCT SMOKE DETECTORS AND DUCT SMOKE DETECTORS TEST STATIONS LOCATIONS TO BE COORDINATED WITH THE MECHANICAL DRAWINGS.
 8. PROVIDE AND INSTALL SYSTEM FIRE ALARM ADDRESSABLE DUCT SMOKE DETECTORS AS INDICATED ON THE MECHANICAL FLOOR PLANS AND RISERS FOR FIRE/SMOKE DAMPERS AND SMOKE DAMPERS. PROVIDE ADDRESSABLE CONTROL RELAY AT EACH DAMPER.
 9. PROVIDE 120V EMERGENCY POWER TO ALL FIRE/SMOKE AND SMOKE DAMPERS INDICATED ON THE MECHANICAL DRAWINGS.
 10. THESE FIRE ALARM DRAWINGS ARE PERFORMANCE SPECIFICATION ONLY. CONTRACTOR SHALL PROVIDE A COMPLETE SYSTEM DESIGN IN COMPLIANCE WITH NFPA 72, THE IBC, NFPA 101, AND ANY OTHER ENFORCED CODES AND AMENDMENTS, INCLUDING ENGINEERED SIGNED AND SEALED DRAWINGS, POINT TO POINT WIRING WITH PROPOSED CIRCUITING OR CONDUIT ROUTING, ALL APPLICABLE CALCULATIONS, DEVICE MANUFACTURERS AND QUANTITIES, WIRING DIAGRAMS, AND SHOP SUBMITTALS. CONTRACTOR SHALL BE RESPONSIBLE FOR ALL ASSOCIATED PERMITS, INSPECTIONS AND TESTING. CONSULT LOCAL BUILDING AUTHORITY AND FIRE MARSHAL REGARDING LOCAL AREA'S REQUIREMENTS.



FIRE ALARM - THIRD FLOOR ENLARGED PLAN A
1/8" = 1'-0"

ALL REPORTS, PLANS, SPECIFICATIONS AND COMPUTER FILES RELATING TO THIS PROJECT ARE THE PROPERTY OF THE MARTIN ARCHITECTURAL GROUP. THE MARTIN ARCHITECTURAL GROUP RETAINS ALL COMMON LAW, STATUTE AND OTHER RESERVED RIGHTS INCLUDING THE COPY RIGHT THEREIN. REPRODUCTION OF THE MATERIAL HEREIN OR SUBSTANTIAL USE WITHOUT WRITTEN PERMISSION OF THE MARTIN ARCHITECTURAL GROUP VIOLATES THE COPYRIGHT LAWS OF THE UNITED STATES AND WILL BE SUBJECT TO LEGAL PROSECUTION.
© The Martin Architectural Group, P.C.

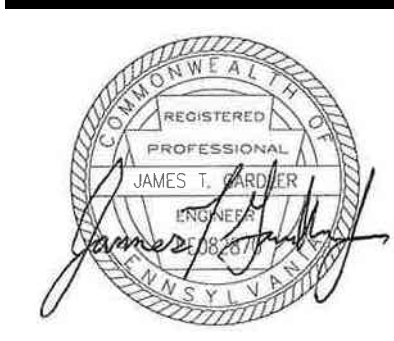

THE MARTIN ARCHITECTURAL GROUP, P.C.
ARCHITECTS AND LAND PLANNERS
A PROFESSIONAL CORPORATION
240 NORTH 22ND STREET, PHILADELPHIA, PA 19103
P (215) 665-1060 F (215) 561-5064

P.A.: JTG
P.M.: TRT
DRAWN BY: Author
PROJECT NO: 1022747

NO.	REVISION	DATE
1	SCHEMATIC BUDGET PRICING SET	11/01/2022
1	PERMIT SET	12/20/2022


Project Status

FIRE ALARM - THIRD FLOOR ENLARGED PLAN A
Granite Run Apartments
MIDDLETOWN TOWNSHIP, PA

SCALE: AS INDICATED
DATE: 11/01/22

FA2.06A
© The Martin Architectural Group, P.C.


Printed: 1/13/2023 12:05:09 PM

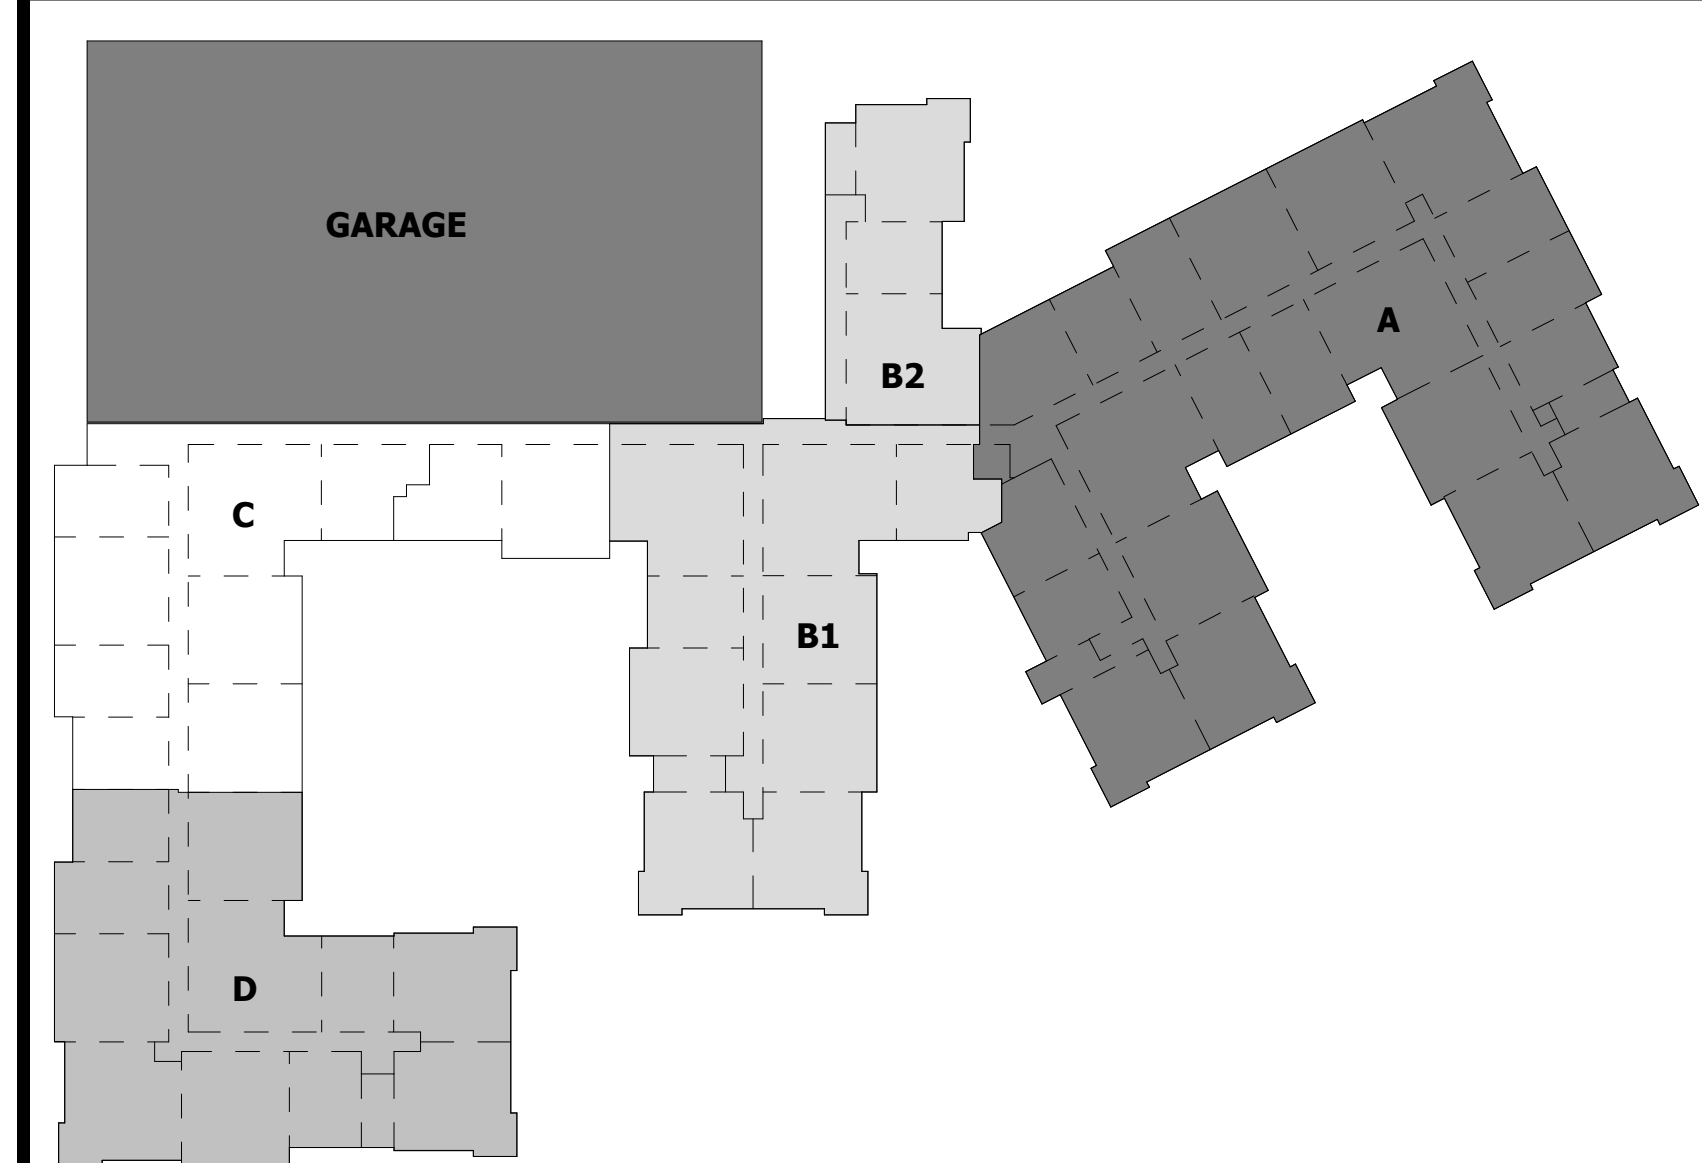

**** NOTE ****

THESE FIRE ALARM DRAWINGS ARE PERFORMANCE SPECIFICATION ONLY. CONTRACTOR SHALL PROVIDE A COMPLETE SYSTEM DESIGN IN COMPLIANCE WITH NFPA 72, THE IBC, NFPA 101, AND ANY OTHER ENFORCED CODES AND AMENDMENTS, INCLUDING ENGINEERED SIGNED AND SEALED DRAWINGS, POINT TO POINT WIRING WITH PROPOSED CIRCUITING OR CONDUIT ROUTING, ALL APPLICABLE CALCULATIONS, DEVICE MANUFACTURERS AND QUANTITIES, WIRING DIAGRAMS, AND SHOP SUBMITTALS. CONTRACTOR SHALL BE RESPONSIBLE FOR ALL ASSOCIATED PERMITS, INSPECTIONS, AND TESTING. CONSULT LOCAL BUILDING AUTHORITY AND FIRE MARSHAL REGARDING LOCAL AREA'S REQUIREMENTS.

- FIRE ALARM GENERAL NOTES**
1. REFER TO SHEETS FA2.01 FOR NOTES, SYMBOLS AND ABBREVIATIONS.
 2. EC SHALL REFER TO TELECOM, SECURITY & AV DRAWINGS, DETAILS FOR FINAL DEVICE LOCATIONS & RACEWAY REQUIREMENTS.
 3. REFER TO MECHANICAL PLANS FOR DUCT SMOKE DETECTOR AND FIRE SMOKE DAMPER LOCATIONS. PROVIDE FA CONNECTION AND WIRE AS REQUIRED.
 4. REFER TO FIRE PROTECTION PLANS FOR TAMPER AND FLOW SWITCH LOCATIONS. PROVIDE FA CONNECTION AND WIRE AS REQUIRED.
 5. PROVIDE AREA SMOKE DETECTORS IN ELEVATOR LOBBIES AND ELEVATOR MACHINE ROOM(S). SMOKE DETECTORS SHALL BE LOCATED ON THE CEILING WITHIN 21 FEET OF THE CENTERLINE OF EACH ELEVATOR DOOR WITHIN THE ELEVATOR BANK UNDER CONTROL OF THE DETECTOR FOR ELEVATOR LOBBIES UP TO 15 FEET IN HEIGHT WITH FLAT AND SMOOTH CEILINGS. FOR HIGHER AND UNEVEN CEILINGS, ADDITIONAL SMOKE DETECTORS MAY BE REQUIRED.
 6. MANUAL FIRE ALARM BOXES SHALL BE LOCATED WITHIN 5 FEET OF EACH EXIT DOORWAY ON EACH FLOOR.
 7. DUCT SMOKE DETECTORS AND DUCT SMOKE DETECTORS TEST STATIONS LOCATIONS TO BE COORDINATED WITH THE MECHANICAL DRAWINGS.
 8. PROVIDE AND INSTALL SYSTEM FIRE ALARM ADDRESSABLE DUCT SMOKE DETECTORS AS INDICATED ON THE MECHANICAL FLOOR PLANS AND RISERS FOR FIRE SMOKE DAMPERS AND SMOKE DAMPERS. PROVIDE ADDRESSABLE CONTROL RELAY AT EACH DAMPER.
 9. PROVIDE 120V EMERGENCY POWER TO ALL FIRE/SMOKE AND SMOKE DAMPERS INDICATED ON THE MECHANICAL DRAWINGS.

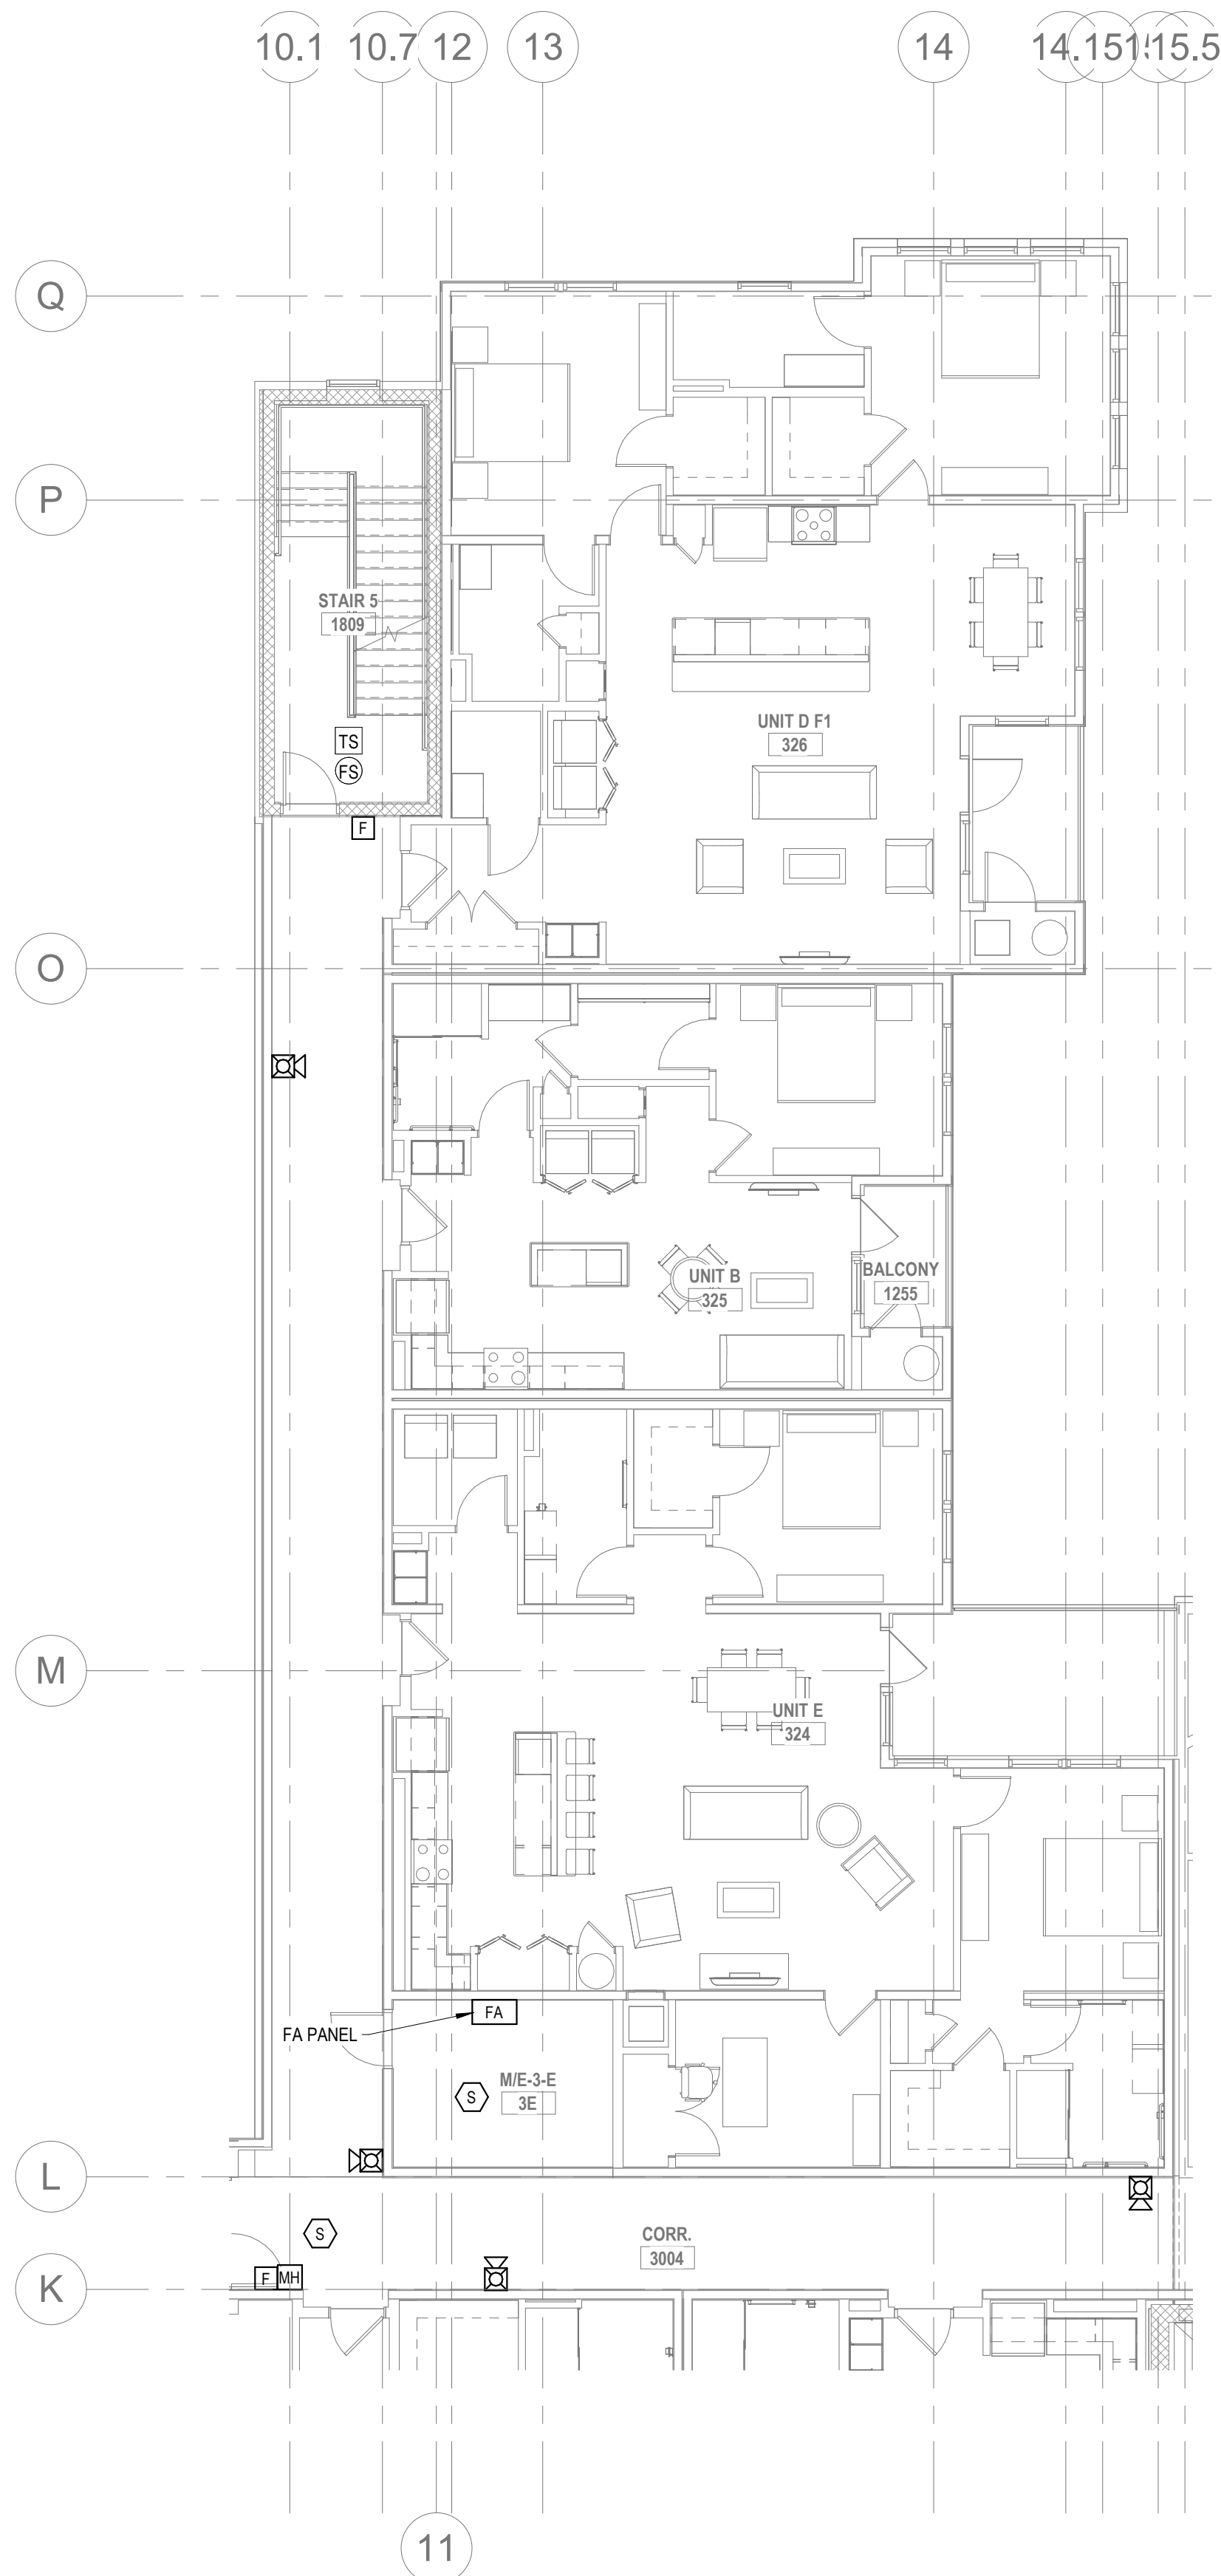


4 FIRE ALARM - THIRD FLOOR ENLARGED PLAN B2
FA2.06B 1/8" = 1'-0"



3 FIRE ALARM - THIRD FLOOR ENLARGED PLAN B1
FA2.06B 1/8" = 1'-0"

ALL REPORTS, PLANS, SPECIFICATIONS AND COMPUTER FILES RELATING TO THIS PROJECT ARE THE PROPERTY OF THE MARTIN ARCHITECTURAL GROUP. THE MARTIN ARCHITECTURAL GROUP RETAINS ALL COMMON LAW, STATUTE AND OTHER RESERVED RIGHTS INCLUDING THE COPY RIGHT THEREIN. REPRODUCTION OF THE MATERIAL HEREIN OR SUBSTANTIAL USE WITHOUT WRITTEN PERMISSION OF THE MARTIN ARCHITECTURAL GROUP VIOLATES THE COPYRIGHT LAWS OF THE UNITED STATES AND WILL BE SUBJECT TO LEGAL PROSECUTION.

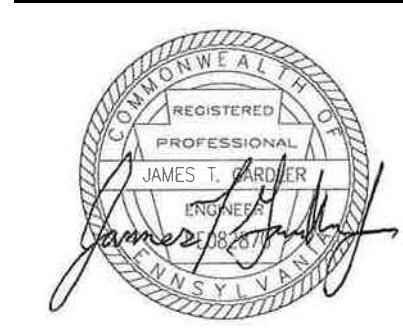

THE MARTIN ARCHITECTURAL GROUP, P.C.
ARCHITECTS AND LAND PLANNERS
A PROFESSIONAL CORPORATION
240 NORTH 22ND STREET, PHILADELPHIA, PA, 19103
P (215) 665-1060 F (215) 561-5064

P.A.: JTG
P.M.: TRT
DRAWN BY: Author
PROJECT NO: 1022747


NO.	REVISION	DATE
1	SCHEMATIC BUDGET PRICING SET	11/01/2022
1	PERMIT SET	12/20/2022

Project Status

FIRE ALARM - THIRD FLOOR ENLARGED PLAN B
Granite Run Apartments
MIDDLETOWN TOWNSHIP, PA

SCALE: AS INDICATED
DATE: 11/01/22

FA2.06B
© The Martin Architectural Group, P.C.

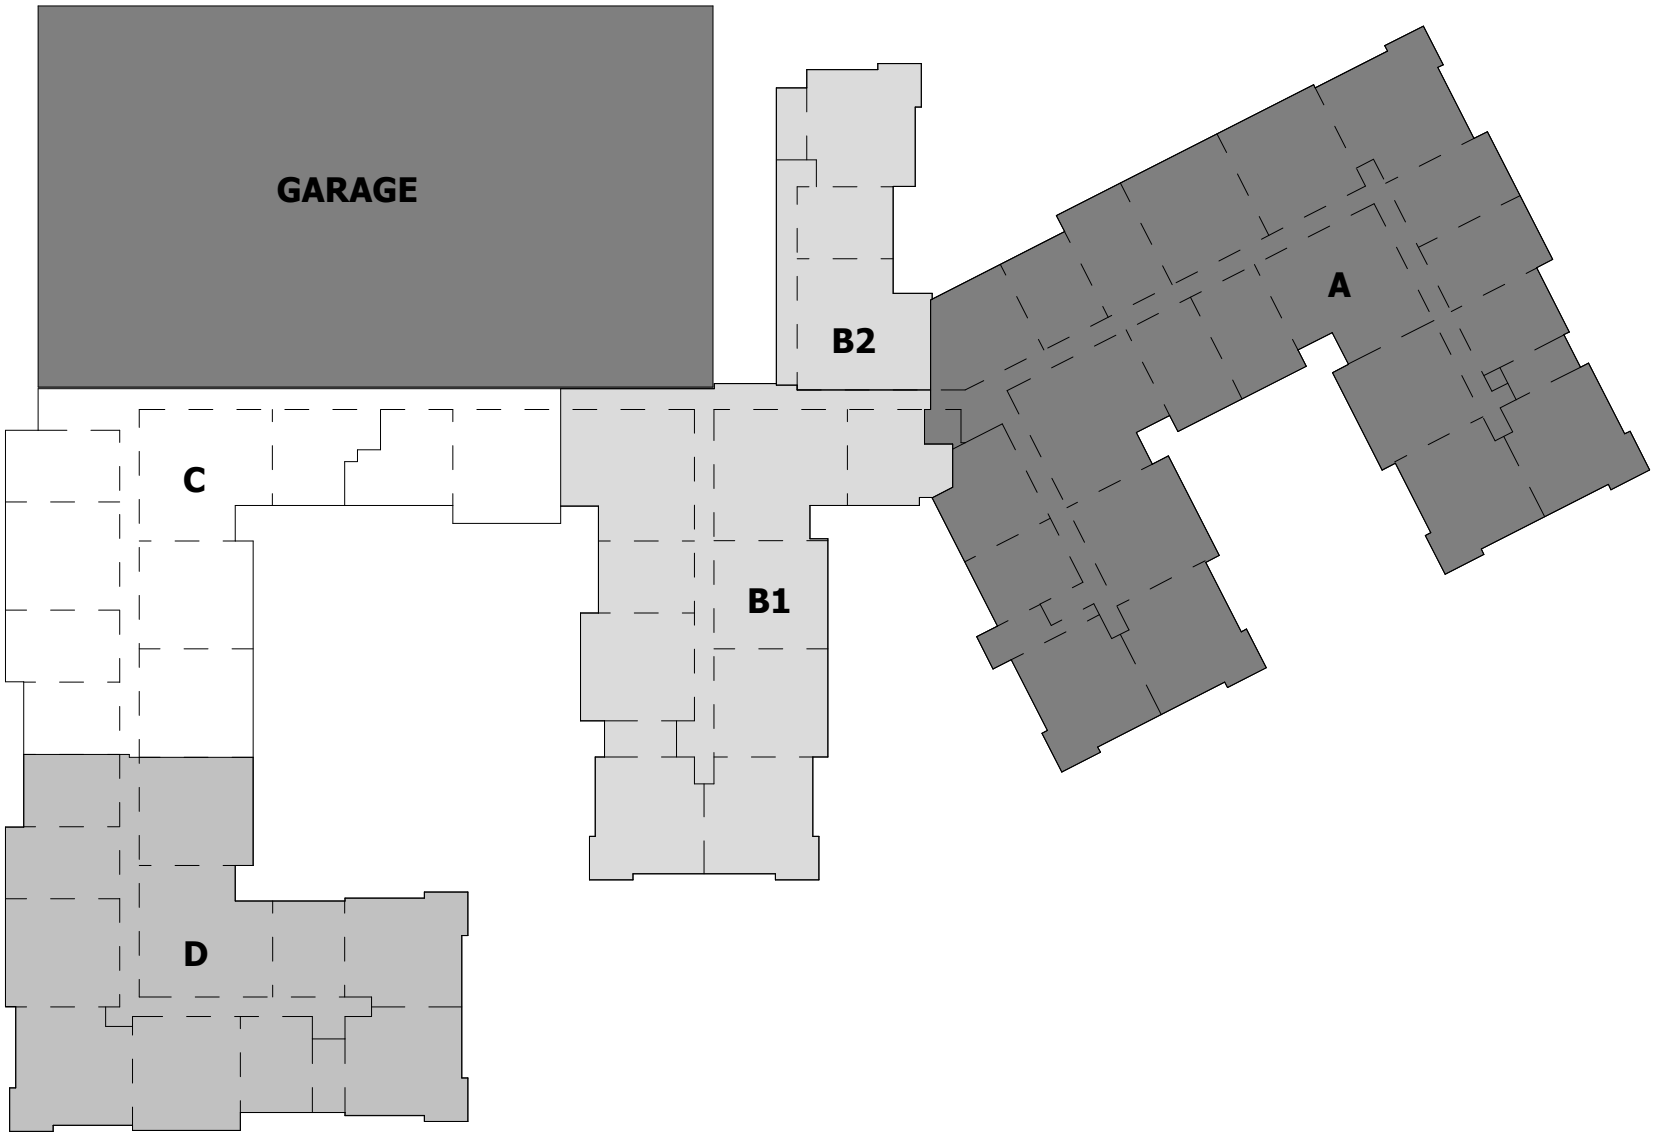


FIRE ALARM GENERAL NOTES

1. REFER TO SHEETS FA0.01 FOR NOTES, SYMBOLS AND ABBREVIATIONS.
2. EC SHALL REFER TO TELECOM, SECURITY & AV DRAWINGS, DETAILS FOR FINAL DEVICE LOCATIONS & RACEWAY REQUIREMENTS.
3. REFER TO MECHANICAL PLANS FOR DUCT SMOKE DETECTOR AND FIRE SMOKE DAMPER LOCATIONS. PROVIDE FA CONNECTION AND WIRE AS REQUIRED.
4. REFER TO FIRE PROTECTION PLANS FOR TAMPER AND FLOW SWITCH LOCATIONS. PROVIDE FA CONNECTION AND WIRE AS REQUIRED.
5. PROVIDE AREA SMOKE DETECTORS IN ELEVATORS LOBBIES AND ELEVATOR MACHINE ROOM(S). SMOKE DETECTORS SHALL BE LOCATED ON THE CEILING WITHIN 21 FEET OF THE CENTERLINE OF EACH ELEVATOR DOOR WITHIN THE ELEVATOR BANK UNDER CONTROL OF THE DETECTOR FOR ELEVATOR LOBBIES UP TO 15 FEET IN HEIGHT WITH FLAT AND SMOOTH CEILINGS. FOR HIGHER AND UNEVEN CEILINGS, ADDITIONAL SMOKE DETECTORS MAY BE REQUIRED.
6. MANUAL FIRE ALARM BOXES SHALL BE LOCATED WITHIN 5 FEET OF EACH EXIT DOORWAY ON EACH FLOOR.
7. DUCT SMOKE DETECTORS AND DUCT SMOKE DETECTORS TEST STATIONS LOCATIONS TO BE COORDINATED WITH THE MECHANICAL DRAWINGS.
8. PROVIDE AND INSTALL SYSTEM FIRE ALARM ADDRESSABLE DUCT SMOKE DETECTORS AS INDICATED ON THE MECHANICAL FLOOR PLANS AND RISERS FOR FIRE/SMOKE DAMPERS AND SMOKE DAMPERS. PROVIDE ADDRESSABLE CONTROL RELAY AT EACH DAMPER.
9. PROVIDE 120V EMERGENCY POWER TO ALL FIRE/SMOKE AND SMOKE DAMPERS INDICATED ON THE MECHANICAL DRAWINGS.
10. THESE FIRE ALARM DRAWINGS ARE PERFORMANCE SPECIFICATION ONLY. CONTRACTOR SHALL PROVIDE A COMPLETE SYSTEM DESIGN IN COMPLIANCE WITH NFPA 72, THE IBC, NFPA 101, AND ANY OTHER ENFORCED CODES AND AMENDMENTS, INCLUDING ENGINEERED SIGNED AND SEALED DRAWINGS. POINT TO POINT WIRING WITH PROPOSED CIRCUITING OR CONDUIT ROUTING, ALL APPLICABLE CALCULATIONS, DEVICE MANUFACTURERS AND QUANTITIES, WIRING DIAGRAMS, AND SHOP SUBMITTALS. CONTRACTOR SHALL BE RESPONSIBLE FOR ALL ASSOCIATED PERMITS, INSPECTIONS, AND TESTING. CONSULT LOCAL BUILDING AUTHORITY AND FIRE MARSHAL REGARDING LOCAL AREA'S REQUIREMENTS.



2 FIRE ALARM - THIRD FLOOR ENLARGED PLAN C
FA2.06C 1/8" = 1'-0"

ALL REPORTS, PLANS, SPECIFICATIONS AND COMPUTER FILES RELATING TO THIS PROJECT ARE THE PROPERTY OF THE MARTIN ARCHITECTURAL GROUP. THE MARTIN ARCHITECTURAL GROUP RETAINS ALL COMMON LAW, STATUTE AND OTHER RESERVED RIGHTS INCLUDING THE COPY RIGHT THERE TO. REPRODUCTION OF THE MATERIAL HEREIN OR SUBSTANTIAL USE WITHOUT WRITTEN PERMISSION OF THE MARTIN ARCHITECTURAL GROUP VIOLATES THE COPYRIGHT LAWS OF THE UNITED STATES AND WILL BE SUBJECT TO LEGAL PROSECUTION.
© The Martin Architectural Group, P.C.

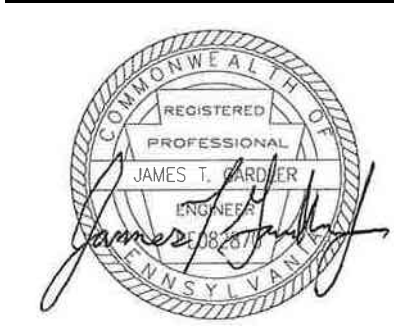

THE MARTIN ARCHITECTURAL GROUP, P.C.
ARCHITECTS AND LAND PLANNERS
A PROFESSIONAL CORPORATION
240 NORTH 22ND STREET, PHILADELPHIA, PA, 19103
P (215) 665-1086 F (215) 561-5064


P.A.: JTG
P.M.: TRT
DRAWN BY: Author
PROJECT NO: 1022747

NO.	REVISION	DATE
1	SCHEMATIC BUDGET PRICING SET PERMIT SET	11/01/2022 12/20/2022

Project Status

FIRE ALARM - THIRD FLOOR ENLARGED PLAN C
Granite Run Apartments
MIDDLETOWN TOWNSHIP, PA

SCALE: AS INDICATED
DATE: 11/01/22

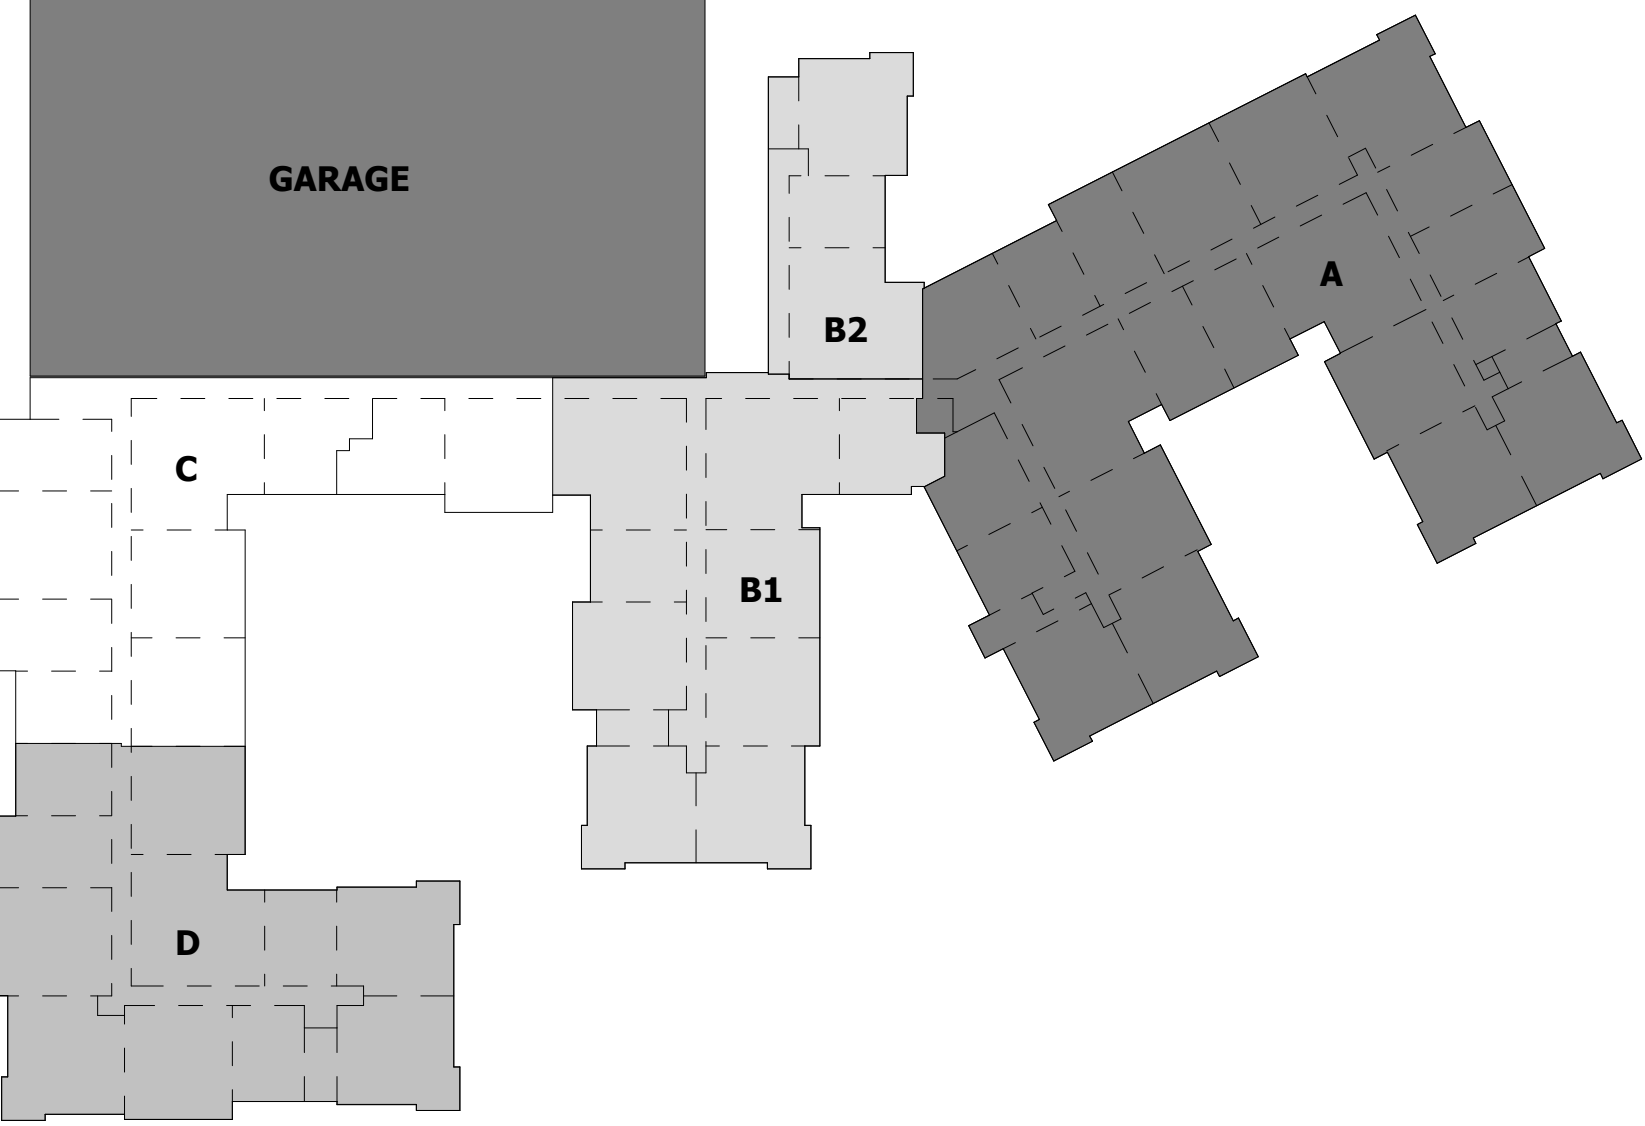


FIRE ALARM GENERAL NOTES

1. REFER TO SHEETS FA0.01 FOR NOTES, SYMBOLS AND ABBREVIATIONS.
2. EC SHALL REFER TO TELECOM, SECURITY & AV DRAWINGS, DETAILS FOR FINAL DEVICE LOCATIONS & RACEWAY REQUIREMENTS.
3. REFER TO MECHANICAL PLANS FOR DUCT SMOKE DETECTOR AND FIRE SMOKE DAMPER LOCATIONS. PROVIDE FA CONNECTION AND WIRE AS REQUIRED.
4. REFER TO FIRE PROTECTION PLANS FOR TAMPER AND FLOW SWITCH LOCATIONS. PROVIDE FA CONNECTION AND WIRE AS REQUIRED.
5. PROVIDE AREA SMOKE DETECTORS IN ELEVATORS LOBBIES AND ELEVATOR MACHINE ROOMS. SMOKE DETECTORS SHALL BE LOCATED ON THE CEILING WITHIN 21 FEET OF THE CENTERLINE OF EACH ELEVATOR DOOR WITHIN THE ELEVATOR BANK UNDER CONTROL OF THE DETECTOR FOR ELEVATOR LOBBIES UP TO 15 FEET IN HEIGHT WITH FLAT AND SMOOTH CEILINGS. FOR HIGHER AND UNEVEN CEILINGS, ADDITIONAL SMOKE DETECTORS MAY BE REQUIRED.
6. MANUAL FIRE ALARM BOXES SHALL BE LOCATED WITHIN 5 FEET OF EACH EXIT DOORWAY ON EACH FLOOR.
7. DUCT SMOKE DETECTORS AND DUCT SMOKE DETECTORS TEST STATIONS LOCATIONS TO BE COORDINATED WITH THE MECHANICAL DRAWINGS.
8. PROVIDE AND INSTALL SYSTEM FIRE ALARM ADDRESSABLE DUCT SMOKE DETECTORS AS INDICATED ON THE MECHANICAL FLOOR PLANS AND RISERS FOR FIRE/SMOKE DAMPERS AND SMOKE DAMPERS. PROVIDE ADDRESSABLE CONTROL RELAY AT EACH DAMPER.
9. PROVIDE 120V EMERGENCY POWER TO ALL FIRE/SMOKE AND SMOKE DAMPERS INDICATED ON THE MECHANICAL DRAWINGS.
10. THESE FIRE ALARM DRAWINGS ARE PERFORMANCE SPECIFICATION ONLY. CONTRACTOR SHALL PROVIDE A COMPLETE SYSTEM DESIGN IN COMPLIANCE WITH NFPA 72, THE IBC, NFPA 101, AND ANY OTHER ENFORCED CODES AND AMENDMENTS, INCLUDING ENGINEERED SIGNED AND SEALED DRAWINGS. POINT TO POINT WIRING WITH PROPOSED CIRCUITING OR CONDUIT ROUTING. ALL APPLICABLE CALCULATIONS, DEVICE MANUFACTURERS AND QUANTITIES, WIRING DIAGRAMS, AND SHOP SUBMITTALS. CONTRACTOR SHALL BE RESPONSIBLE FOR ALL ASSOCIATED PERMITS, INSPECTIONS, AND TESTING. CONSULT LOCAL BUILDING AUTHORITY AND FIRE MARSHAL REGARDING LOCAL AREA'S REQUIREMENTS.



FIRE ALARM - THIRD FLOOR ENLARGED PLAN D

ALL REPORTS, PLANS, SPECIFICATIONS AND COMPUTER FILES RELATING TO THIS PROJECT ARE THE PROPERTY OF THE MARTIN ARCHITECTURAL GROUP. THE MARTIN ARCHITECTURAL GROUP RETAINS ALL COMMON LAW, STATUTE AND OTHER RESERVED RIGHTS INCLUDING THE COPY RIGHT THERE TO. REPRODUCTION OF THE MATERIAL HEREIN OR SUBSTANTIAL USE WITHOUT WRITTEN PERMISSION OF THE MARTIN ARCHITECTURAL GROUP VIOLATES THE COPYRIGHT LAWS OF THE UNITED STATES AND WILL BE SUBJECT TO LEGAL PROSECUTION.

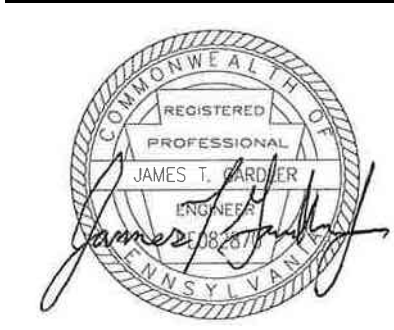

THE MARTIN ARCHITECTURAL GROUP, P.C.
ARCHITECTS AND LAND PLANNERS
A PROFESSIONAL CORPORATION
240 NORTH 22ND STREET, PHILADELPHIA, PA, 19103
P (215) 665-1060 F (215) 561-5064

P.A.: JTG
P.M.: TRT
DRAWN BY: Author
PROJECT NO: 1022747

NO.	REVISION	DATE
1	PERMIT SET	12/20/2022
	SCHEMATIC BUDGET PRICING SET	11/01/2022

Project Status

FIRE ALARM - THIRD FLOOR ENLARGED PLAN D
Granite Run Apartments

SCALE: AS INDICATED
DATE: 11/01/22

Printed: 1/13/2023 12:06:37 PM



2 FIRE ALARM - FOURTH FLOOR PLAN
1/16" = 1'-0"

ALL REPORTS, PLANS, SPECIFICATIONS AND COMPUTER FILES RELATING TO THIS PROJECT ARE THE PROPERTY OF THE MARTIN ARCHITECTURAL GROUP. THE MARTIN ARCHITECTURAL GROUP RETAINS ALL COMMON LAW, STATUTE AND OTHER RESERVED RIGHTS INCLUDING THE COPY RIGHT THEREBY. REPRODUCTION OF THE MATERIAL HEREIN OR SUBSTANTIAL USE WITHOUT WRITTEN PERMISSION OF THE MARTIN ARCHITECTURAL GROUP VIOLATES THE COPYRIGHT LAWS OF THE UNITED STATES AND WILL BE SUBJECT TO LEGAL PROSECUTION.
© The Martin Architectural Group, P.C.



THE MARTIN ARCHITECTURAL GROUP, P.C.
ARCHITECTS AND LAND PLANNERS
A PROFESSIONAL CORPORATION
240 NORTH 22ND STREET, PHILADELPHIA, PA 19103
P (215) 665-1060 F (215) 561-5064

P.A.: JTG
P.M.: TRT
DRAWN BY: Author
PROJECT NO: 1022747

NO.	REVISION	DATE
1	SCHEMATIC BUDGET PRICING SET	11/01/2022
2	PERMIT SET	12/20/2022


Project Status

FIRE ALARM - FOURTH FLOOR OVERALL PLAN
Granite Run Apartments
MIDDLETOWN TOWNSHIP, PA

SCALE: AS INDICATED
DATE: 11/01/2022

FA2.07
© The Martin Architectural Group, P.C.

Printed: 1/13/2023 12:06:45 PM

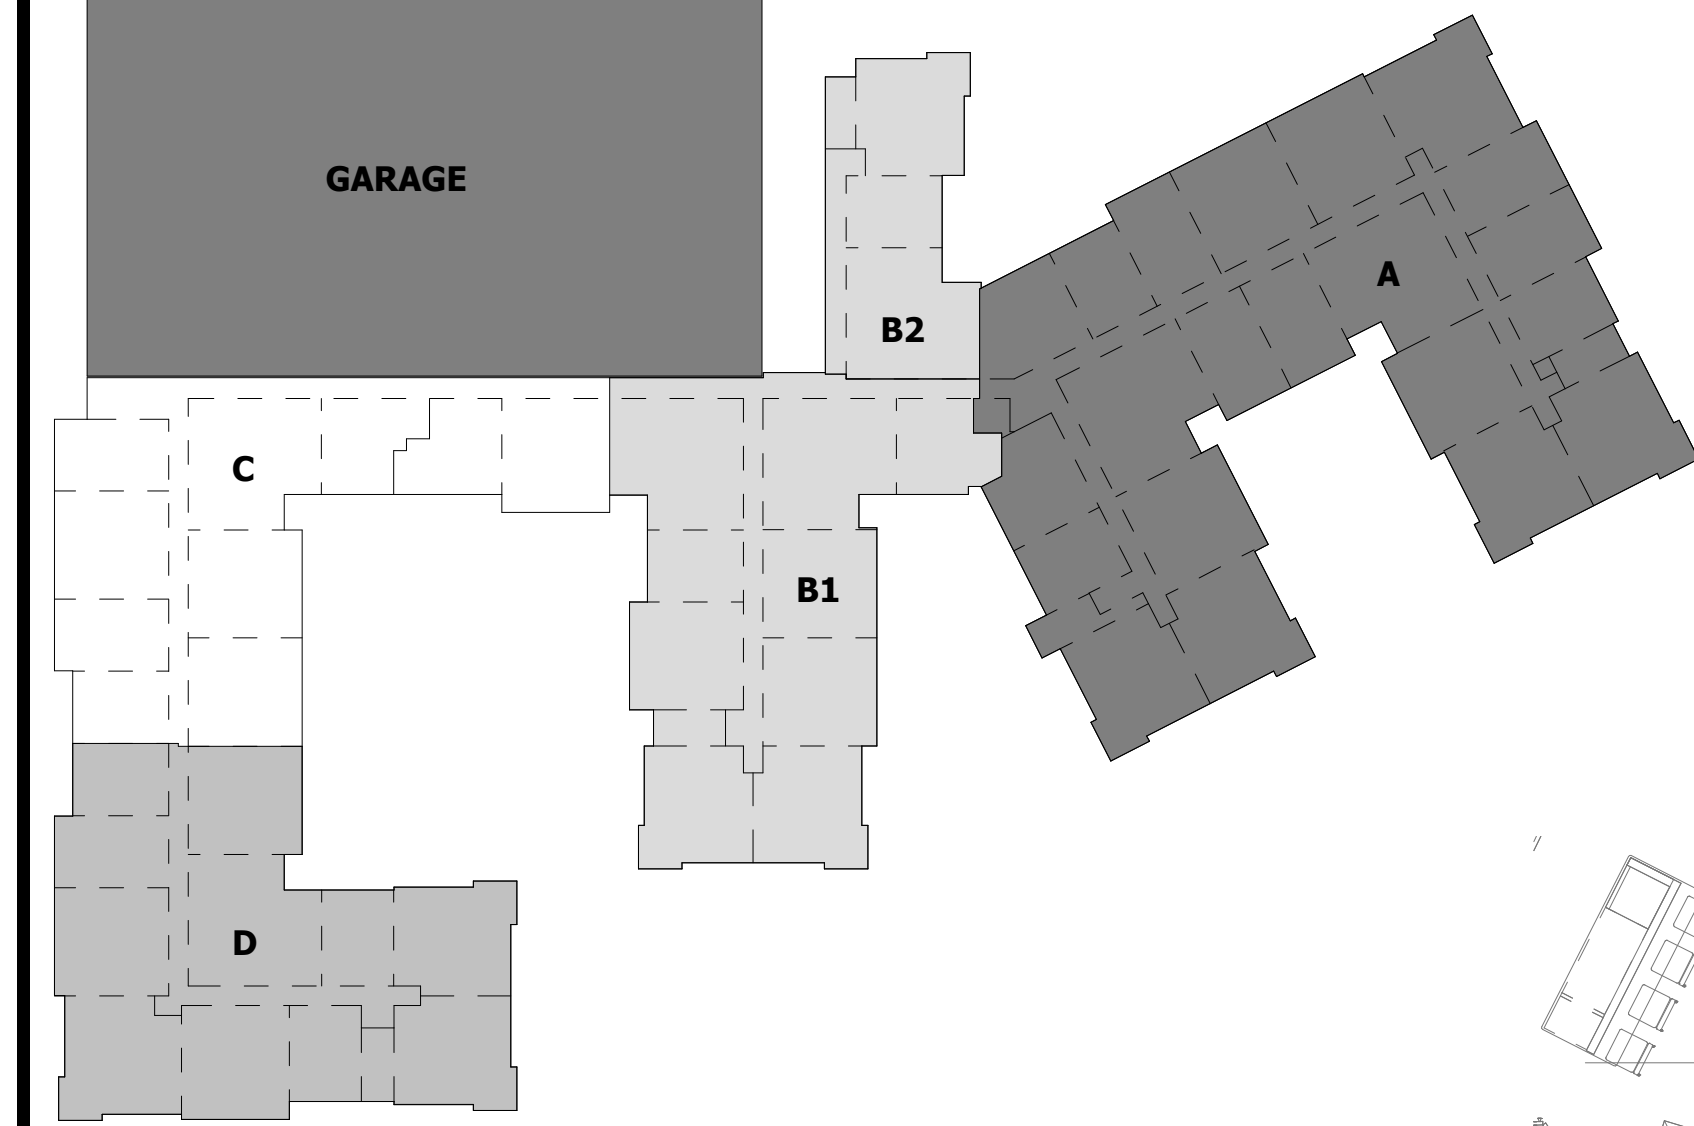

- FIRE ALARM GENERAL NOTES**
1. REFER TO SHEETS FA0.01 FOR NOTES, SYMBOLS AND ABBREVIATIONS.
 2. EC SHALL REFER TO TELECOM, SECURITY & AV DRAWINGS, DETAILS FOR FINAL DEVICE LOCATIONS & RACEWAY REQUIREMENTS.
 3. REFER TO MECHANICAL PLANS FOR DUCT SMOKE DETECTOR AND FIRE SMOKE DAMPER LOCATIONS. PROVIDE FA CONNECTION AND WIRE AS REQUIRED.
 4. REFER TO FIRE PROTECTION PLANS FOR TAMPER AND FLOW SWITCH LOCATIONS. PROVIDE FA CONNECTION AND WIRE AS REQUIRED.
 5. PROVIDE AREA SMOKE DETECTORS IN ELEVATORS LOBBIES AND ELEVATOR MACHINE ROOMS. SMOKE DETECTORS SHALL BE LOCATED ON THE CEILING WITHIN 21 FEET OF THE CENTERLINE OF EACH ELEVATOR DOOR WITHIN THE ELEVATOR BANK UNDER CONTROL OF THE DETECTOR FOR ELEVATOR LOBBIES UP TO 15 FEET IN HEIGHT WITH FLAT AND SMOOTH CEILINGS. FOR HIGHER AND UNEVEN CEILINGS, ADDITIONAL SMOKE DETECTORS MAY BE REQUIRED.
 6. MANUAL FIRE ALARM BOXES SHALL BE LOCATED WITHIN 5 FEET OF EACH EXIT DOORWAY ON EACH FLOOR.
 7. DUCT SMOKE DETECTORS AND DUCT SMOKE DETECTORS TEST STATIONS LOCATIONS TO BE COORDINATED WITH THE MECHANICAL DRAWINGS.
 8. PROVIDE AND INSTALL SYSTEM FIRE ALARM ADDRESSABLE DUCT SMOKE DETECTORS AS INDICATED ON THE MECHANICAL FLOOR PLANS AND RISERS FOR FIRE/SMOKE DAMPERS AND SMOKE DAMPERS. PROVIDE ADDRESSABLE CONTROL RELAY AT EACH DAMPER.
 9. PROVIDE 120V EMERGENCY POWER TO ALL FIRE/SMOKE AND SMOKE DAMPERS INDICATED ON THE MECHANICAL DRAWINGS.
 10. THESE FIRE ALARM DRAWINGS ARE PERFORMANCE SPECIFICATION ONLY. CONTRACTOR SHALL PROVIDE A COMPLETE SYSTEM DESIGN IN COMPLIANCE WITH NFPA 72, THE IBC, NFPA 101, AND ANY OTHER ENFORCED CODES AND AMENDMENTS, INCLUDING ENGINEERED SIGNED AND SEALED DRAWINGS, POINT TO POINT WIRING WITH PROPOSED CIRCUITING OR CONDUIT ROUTING, ALL APPLICABLE CALCULATIONS, DEVICE MANUFACTURERS AND QUANTITIES, WIRING DIAGRAMS, AND SHOP SUBMITTALS. CONTRACTOR SHALL BE RESPONSIBLE FOR ALL ASSOCIATED PERMITS, INSPECTIONS AND TESTING. CONSULT LOCAL BUILDING AUTHORITY AND FIRE MARSHAL REGARDING LOCAL AREA'S REQUIREMENTS.



FIRE ALARM - FOURTH FLOOR ENLARGED PLAN A
FA2.07A 1/8" = 1'-0"

ALL REPORTS, PLANS, SPECIFICATIONS AND COMPUTER FILES RELATING TO THIS PROJECT ARE THE PROPERTY OF THE MARTIN ARCHITECTURAL GROUP. THE MARTIN ARCHITECTURAL GROUP RETAINS ALL COMMON LAW, STATUTE AND OTHER RESERVED RIGHTS INCLUDING THE COPY RIGHT THEREIN. REPRODUCTION OF THE MATERIAL HEREIN OR SUBSTANTIAL USE WITHOUT WRITTEN PERMISSION OF THE MARTIN ARCHITECTURAL GROUP VIOLATES THE COPYRIGHT LAWS OF THE UNITED STATES AND WILL BE SUBJECT TO LEGAL PROSECUTION.
© The Martin Architectural Group, P.C.



THE MARTIN ARCHITECTURAL GROUP, P.C.
ARCHITECTS AND LAND PLANNERS
A PROFESSIONAL CORPORATION
240 NORTH 22ND STREET, PHILADELPHIA, PA, 19103
P (215) 655-1060 F (215) 561-5064

P.A.: JTG
P.M.: TRT
DRAWN BY: Author
PROJECT NO: 1022747


NO.	REVISION	DATE
1	ISSUE FOR SEPARATE BUDGET PRICING SET	1/11/2023
1	PERMIT SET	12/20/2022

Project Status


FIRE ALARM - FOURTH FLOOR ENLARGED PLAN A
Granite Run Apartments
MIDDLETOWN TOWNSHIP, PA

SCALE: AS INDICATED
DATE: 11/01/22

Printed: 1/13/2023 12:06:54 PM

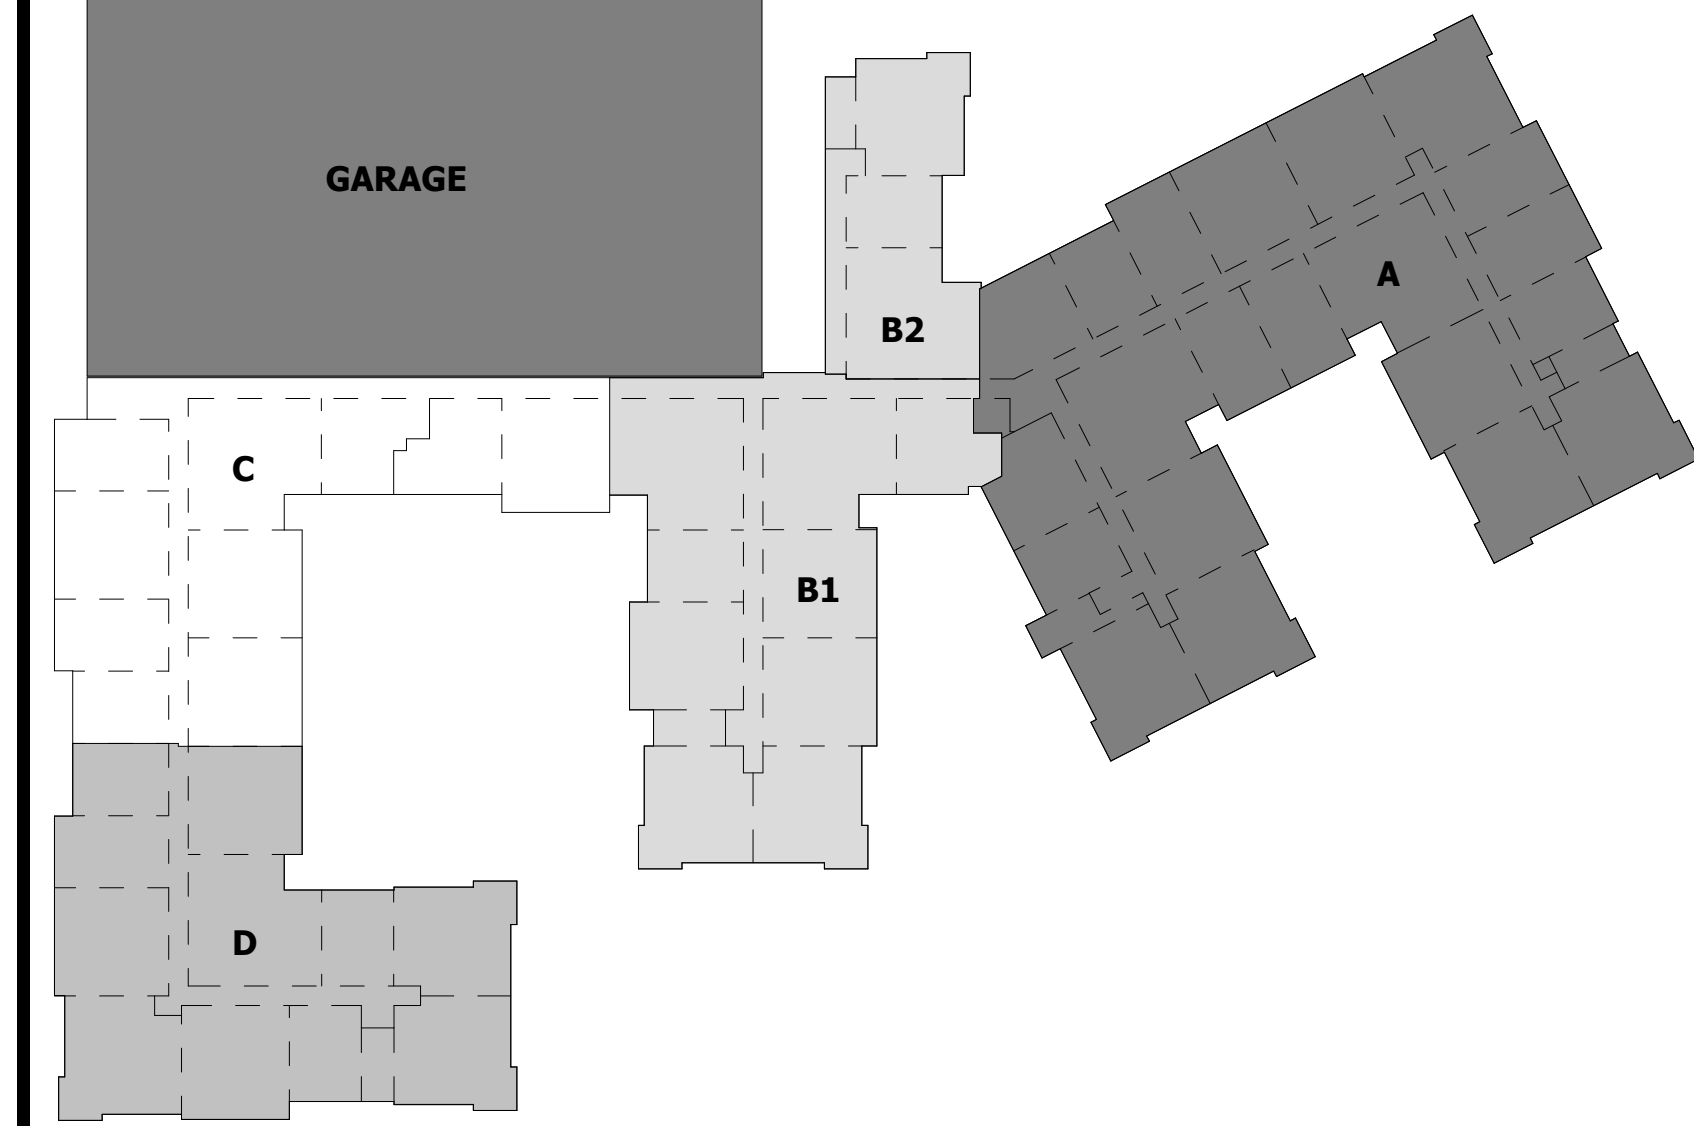

- FIRE ALARM GENERAL NOTES**
1. REFER TO SHEETS FA0.01 FOR NOTES, SYMBOLS AND ABBREVIATIONS.
 2. EC SHALL REFER TO TELECOM, SECURITY & AV DRAWINGS, DETAILS FOR FINAL DEVICE LOCATIONS & RACEWAY REQUIREMENTS.
 3. REFER TO MECHANICAL PLANS FOR DUCT SMOKE DETECTOR AND FIRE SMOKE DAMPER LOCATIONS. PROVIDE FA CONNECTION AND WIRE AS REQUIRED.
 4. REFER TO FIRE PROTECTION PLANS FOR TAMPER AND FLOW SWITCH LOCATIONS. PROVIDE FA CONNECTION AND WIRE AS REQUIRED.
 5. PROVIDE AREA SMOKE DETECTORS IN ELEVATOR LOBBIES AND ELEVATOR MACHINE ROOMS. SMOKE DETECTORS SHALL BE LOCATED ON THE CEILING WITHIN 21 FEET OF THE CENTERLINE OF EACH ELEVATOR DOOR WITHIN THE ELEVATOR BANK UNDER CONTROL OF THE DETECTOR FOR ELEVATOR LOBBIES UP TO 15 FEET IN HEIGHT WITH FLAT AND SMOOTH CEILINGS. FOR HIGHER AND UNEVEN CEILINGS, ADDITIONAL SMOKE DETECTORS MAY BE REQUIRED.
 6. MANUAL FIRE ALARM BOXES SHALL BE LOCATED WITHIN 5 FEET OF EACH EXIT DOORWAY ON EACH FLOOR.
 7. DUCT SMOKE DETECTORS AND DUCT SMOKE DETECTORS TEST STATIONS LOCATIONS TO BE COORDINATED WITH THE MECHANICAL DRAWINGS.
 8. PROVIDE AND INSTALL SYSTEM FIRE ALARM ADDRESSABLE DUCT SMOKE DETECTORS AS INDICATED ON THE MECHANICAL FLOOR PLANS AND RISERS FOR FIRE/SMOKE DAMPERS AND SMOKE DAMPERS. PROVIDE ADDRESSABLE CONTROL RELAY AT EACH DAMPER.
 9. PROVIDE 120V EMERGENCY POWER TO ALL FIRE/SMOKE AND SMOKE DAMPERS INDICATED ON THE MECHANICAL DRAWINGS.
 10. THESE FIRE ALARM DRAWINGS ARE PERFORMANCE SPECIFICATION ONLY. CONTRACTOR SHALL PROVIDE A COMPLETE SYSTEM DESIGN IN COMPLIANCE WITH NFPA 72, THE IBC, NFPA 101, AND ANY OTHER ENFORCED CODES AND AMENDMENTS, INCLUDING ENGINEERED SIGNED AND SEALED DRAWINGS, POINT TO POINT WIRING WITH PROPOSED CIRCUITING OR CONDUIT ROUTING, ALL APPLICABLE CALCULATIONS, DEVICE MANUFACTURERS AND QUANTITIES, WIRING DIAGRAMS, AND SHOP SUBMITTALS. CONTRACTOR SHALL BE RESPONSIBLE FOR ALL ASSOCIATED PERMITS, INSPECTIONS, AND TESTING. CONSULT LOCAL BUILDING AUTHORITY AND FIRE MARSHAL REGARDING LOCAL AREA'S REQUIREMENTS.

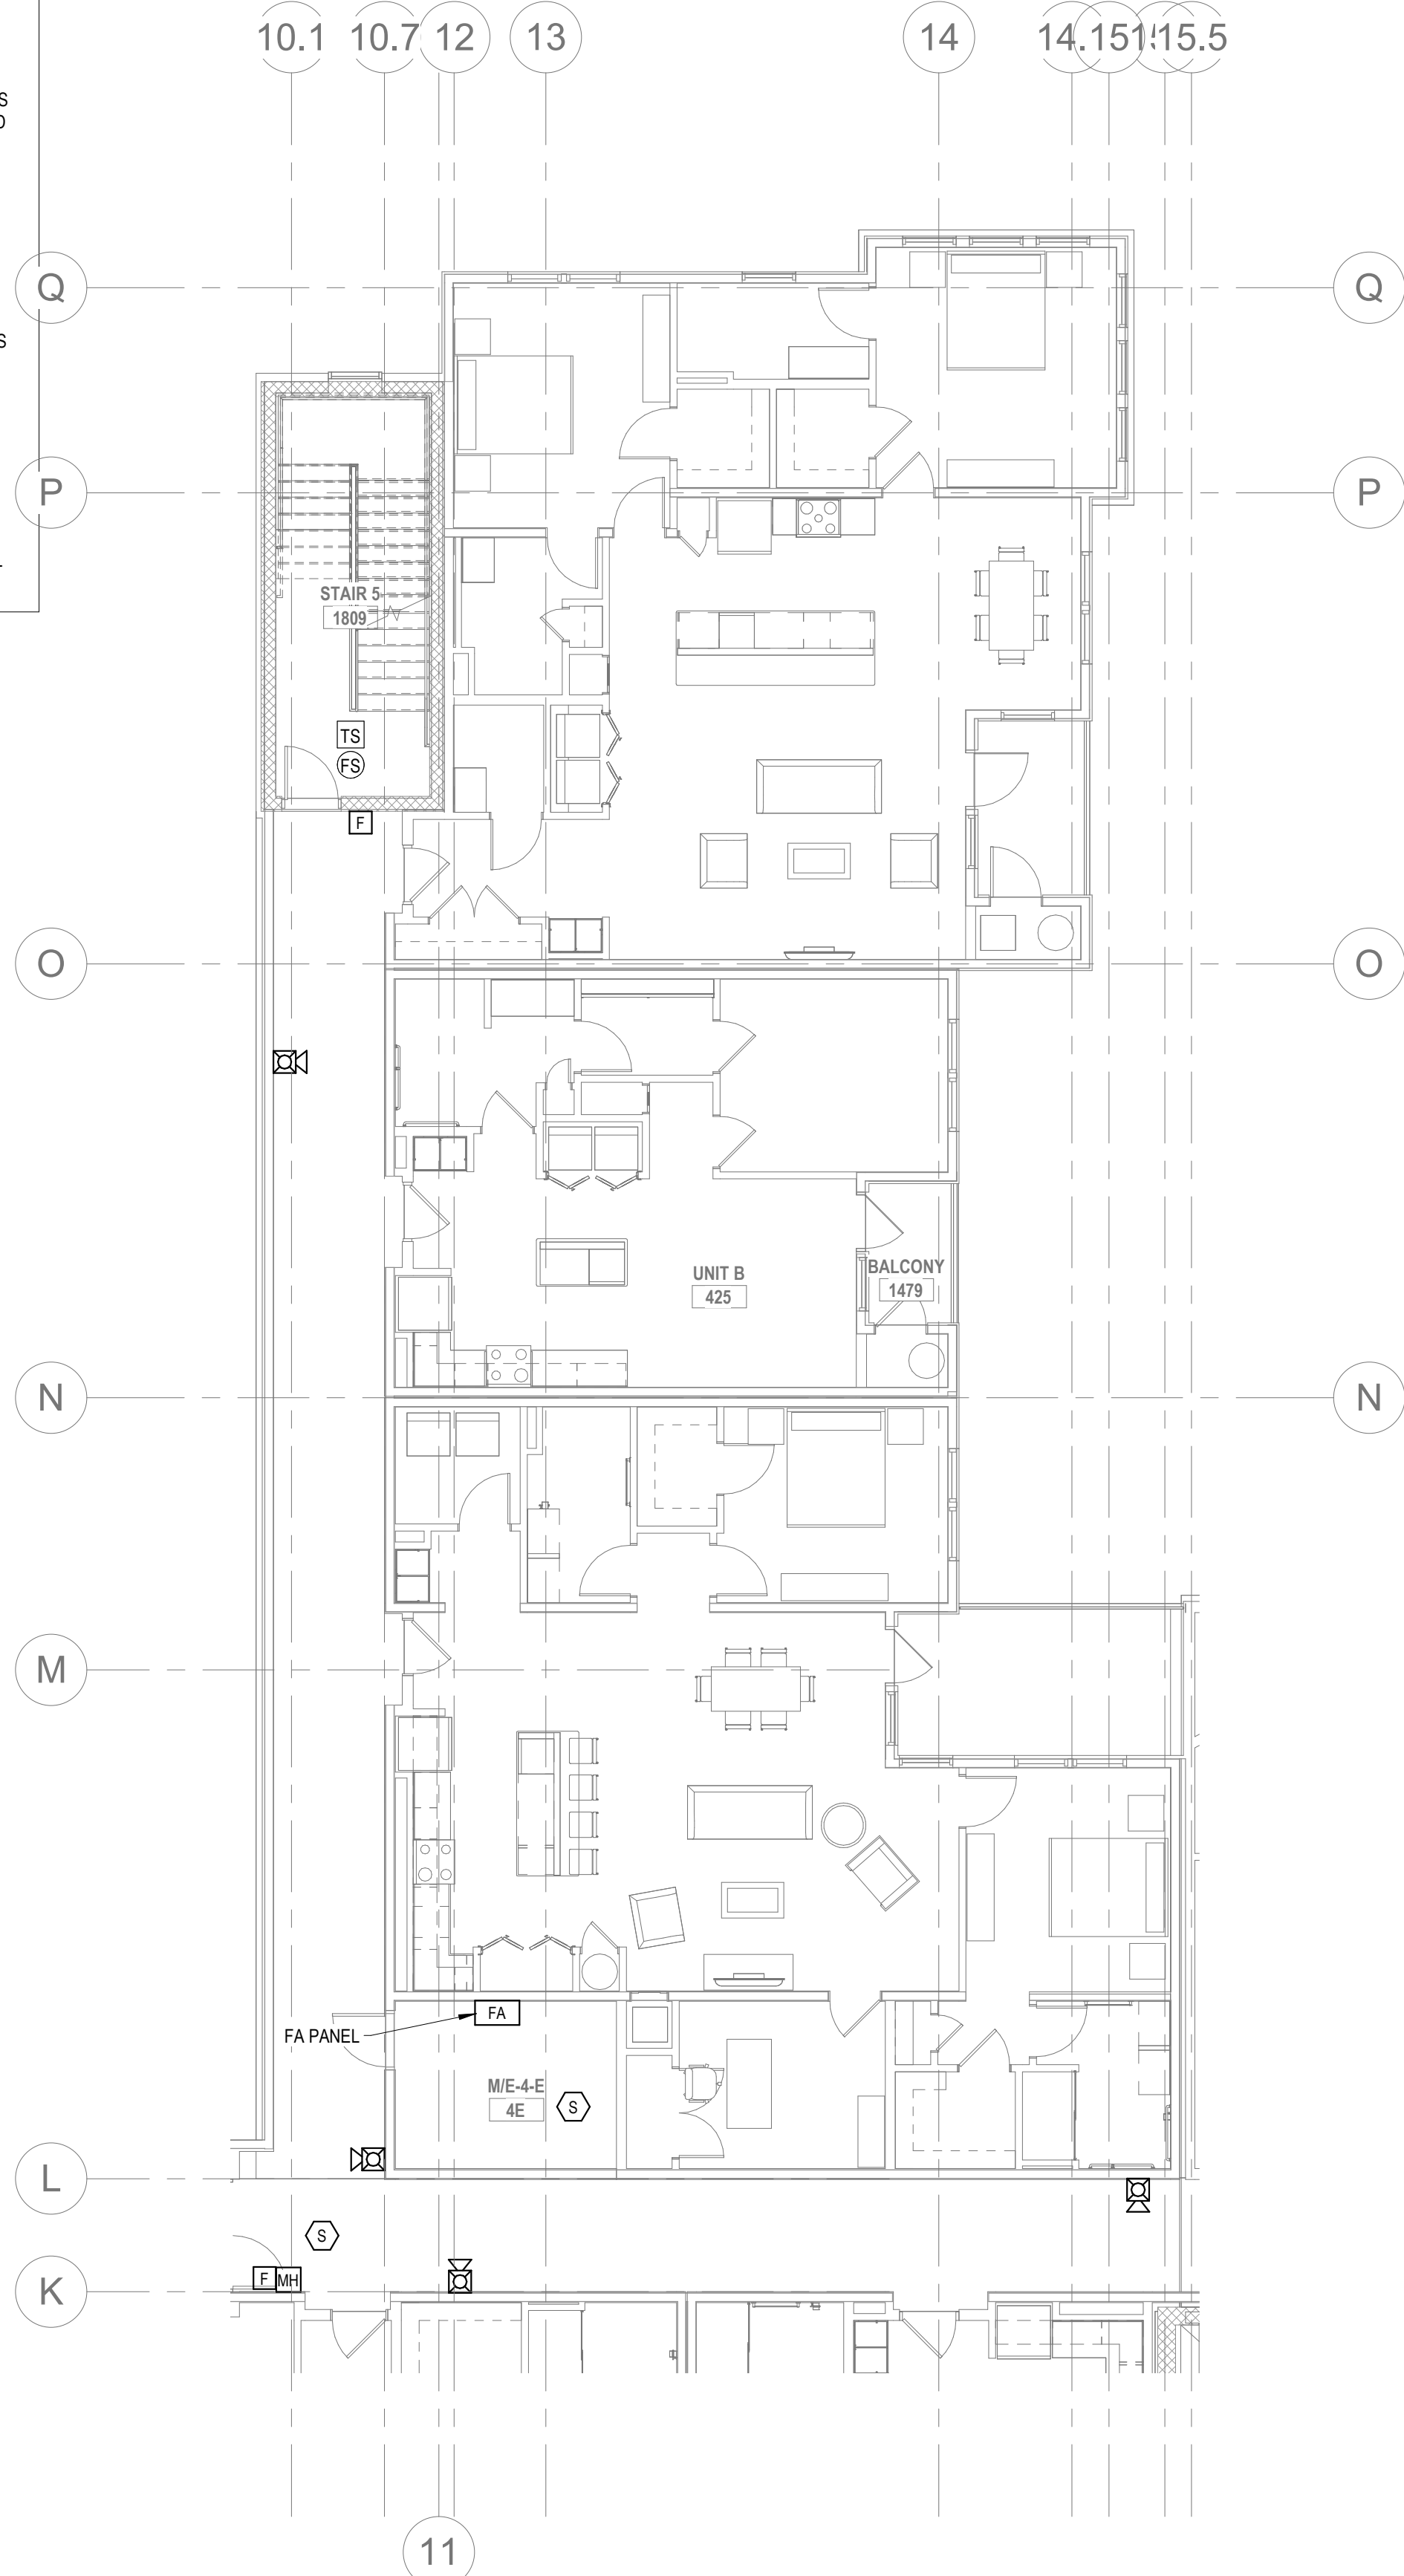

4 FIRE ALARM - FOURTH FLOOR ENLARGED PLAN B2
FA2.07B 1/8" = 1'-0"



2 FIRE ALARM - FOURTH FLOOR ENLARGED PLAN B1
FA2.07B 1/8" = 1'-0"

ALL REPORTS, PLANS, SPECIFICATIONS AND COMPUTER FILES RELATING TO THIS PROJECT ARE THE PROPERTY OF THE MARTIN ARCHITECTURAL GROUP. THE MARTIN ARCHITECTURAL GROUP RETAINS ALL COMMON LAW, STATUTE AND OTHER RESERVED RIGHTS INCLUDING THE COPY RIGHT THEREIN. REPRODUCTION OF THE MATERIAL HEREIN OR SUBSTANTIAL USE WITHOUT WRITTEN PERMISSION OF THE MARTIN ARCHITECTURAL GROUP VIOLATES THE COPYRIGHT LAWS OF THE UNITED STATES AND WILL BE SUBJECT TO LEGAL PROSECUTION.
© The Martin Architectural Group, P.C.



THE MARTIN ARCHITECTURAL GROUP, P.C.
ARCHITECTS AND LAND PLANNERS
A PROFESSIONAL CORPORATION
240 NORTH 22ND STREET, PHILADELPHIA, PA 19103
P (215) 665-1060 F (215) 561-5064

P.A.: JTG
P.M.: TRT
DRAWN BY: Author
PROJECT NO: 1022747


NO.	REVISION	DATE
1	SEPARATE BUDGET PRICING SET	11/01/2022
1	PERMIT SET	12/20/2022

Project Status

FIRE ALARM - FOURTH FLOOR ENLARGED PLAN B
Granite Run Apartments


SCALE: AS INDICATED
DATE: 11/01/22

FA2.07B
© The Martin Architectural Group, P.C.

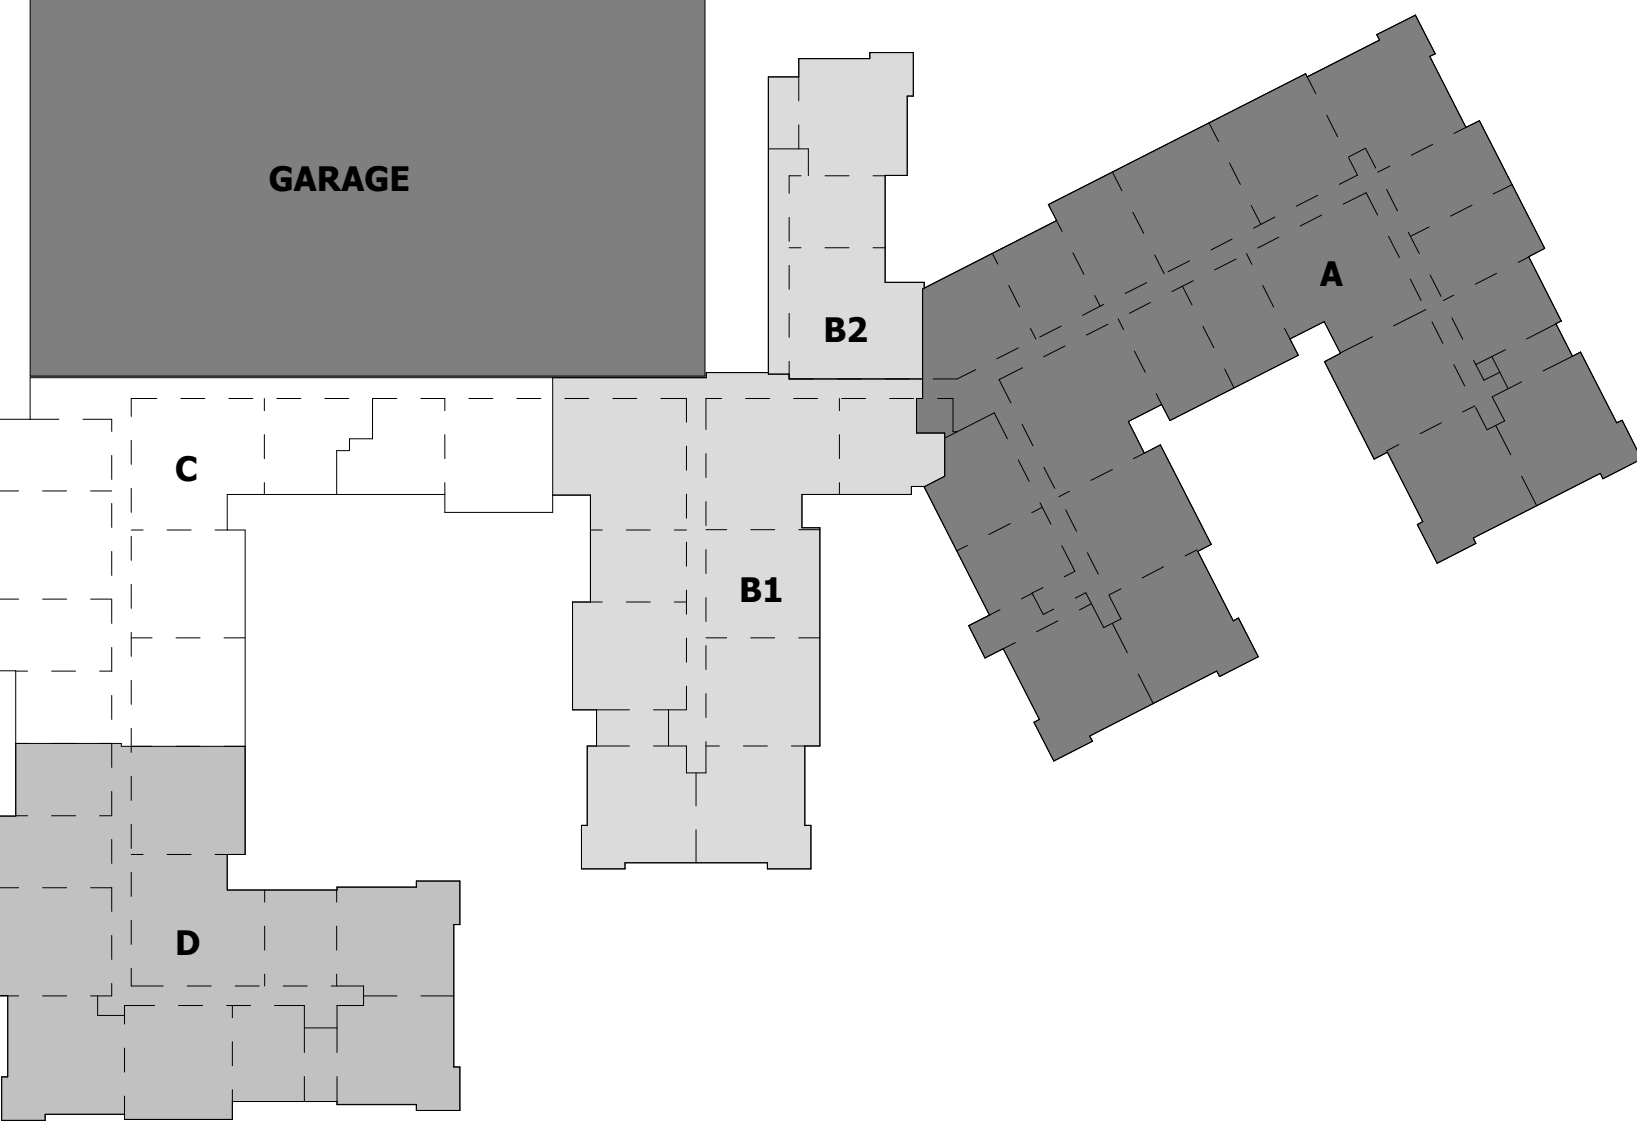

FIRE ALARM GENERAL NOTES

1. REFER TO SHEETS FA0.01 FOR NOTES, SYMBOLS AND ABBREVIATIONS.
2. EC SHALL REFER TO TELECOM, SECURITY & AV DRAWINGS, DETAILS FOR FINAL DEVICE LOCATIONS & RACEWAY REQUIREMENTS.
3. REFER TO MECHANICAL PLANS FOR DUCT SMOKE DETECTOR AND FIRE SMOKE DAMPER LOCATIONS. PROVIDE FA CONNECTION AND WIRE AS REQUIRED.
4. REFER TO FIRE PROTECTION PLANS FOR TAMPER AND FLOW SWITCH LOCATIONS. PROVIDE FA CONNECTION AND WIRE AS REQUIRED.
5. PROVIDE AREA SMOKE DETECTORS IN ELEVATORS LOBBIES AND ELEVATOR MACHINE ROOM(S). SMOKE DETECTORS SHALL BE LOCATED ON THE CEILING WITHIN 21 FEET OF THE CENTERLINE OF EACH ELEVATOR DOOR WITHIN THE ELEVATOR BANK UNDER CONTROL OF THE DETECTOR FOR ELEVATOR LOBBIES UP TO 15 FEET IN HEIGHT WITH FLAT AND SMOOTH CEILINGS. FOR HIGHER AND UNEVEN CEILINGS, ADDITIONAL SMOKE DETECTORS MAY BE REQUIRED.
6. MANUAL FIRE ALARM BOXES SHALL BE LOCATED WITHIN 5 FEET OF EACH EXIT DOORWAY ON EACH FLOOR.
7. DUCT SMOKE DETECTORS AND DUCT SMOKE DETECTORS TEST STATIONS LOCATIONS TO BE COORDINATED WITH THE MECHANICAL DRAWINGS.
8. PROVIDE AND INSTALL SYSTEM FIRE ALARM ADDRESSABLE DUCT SMOKE DETECTORS AS INDICATED ON THE MECHANICAL FLOOR PLANS AND RISERS FOR FIRE/SMOKE DAMPERS AND SMOKE DAMPERS. PROVIDE ADDRESSABLE CONTROL RELAY AT EACH DAMPER.
9. PROVIDE 120V EMERGENCY POWER TO ALL FIRE/SMOKE AND SMOKE DAMPERS INDICATED ON THE MECHANICAL DRAWINGS.
10. THESE FIRE ALARM DRAWINGS ARE PERFORMANCE SPECIFICATION ONLY. CONTRACTOR SHALL PROVIDE A COMPLETE SYSTEM DESIGN IN COMPLIANCE WITH NFPA 72, THE IBC, NFPA 101, AND ANY OTHER ENFORCED CODES AND AMENDMENTS, INCLUDING ENGINEERED SIGNED AND SEALED DRAWINGS, POINT TO POINT WIRING WITH PROPOSED CIRCUITING OR CONDUIT ROUTING, ALL APPLICABLE CALCULATIONS, DEVICE MANUFACTURERS AND QUANTITIES, WIRING DIAGRAMS, AND SHOP SUBMITTALS. CONTRACTOR SHALL BE RESPONSIBLE FOR ALL ASSOCIATED PERMITS, INSPECTIONS, AND TESTING. CONSULT LOCAL BUILDING AUTHORITY AND FIRE MARSHAL REGARDING LOCAL AREA'S REQUIREMENTS.

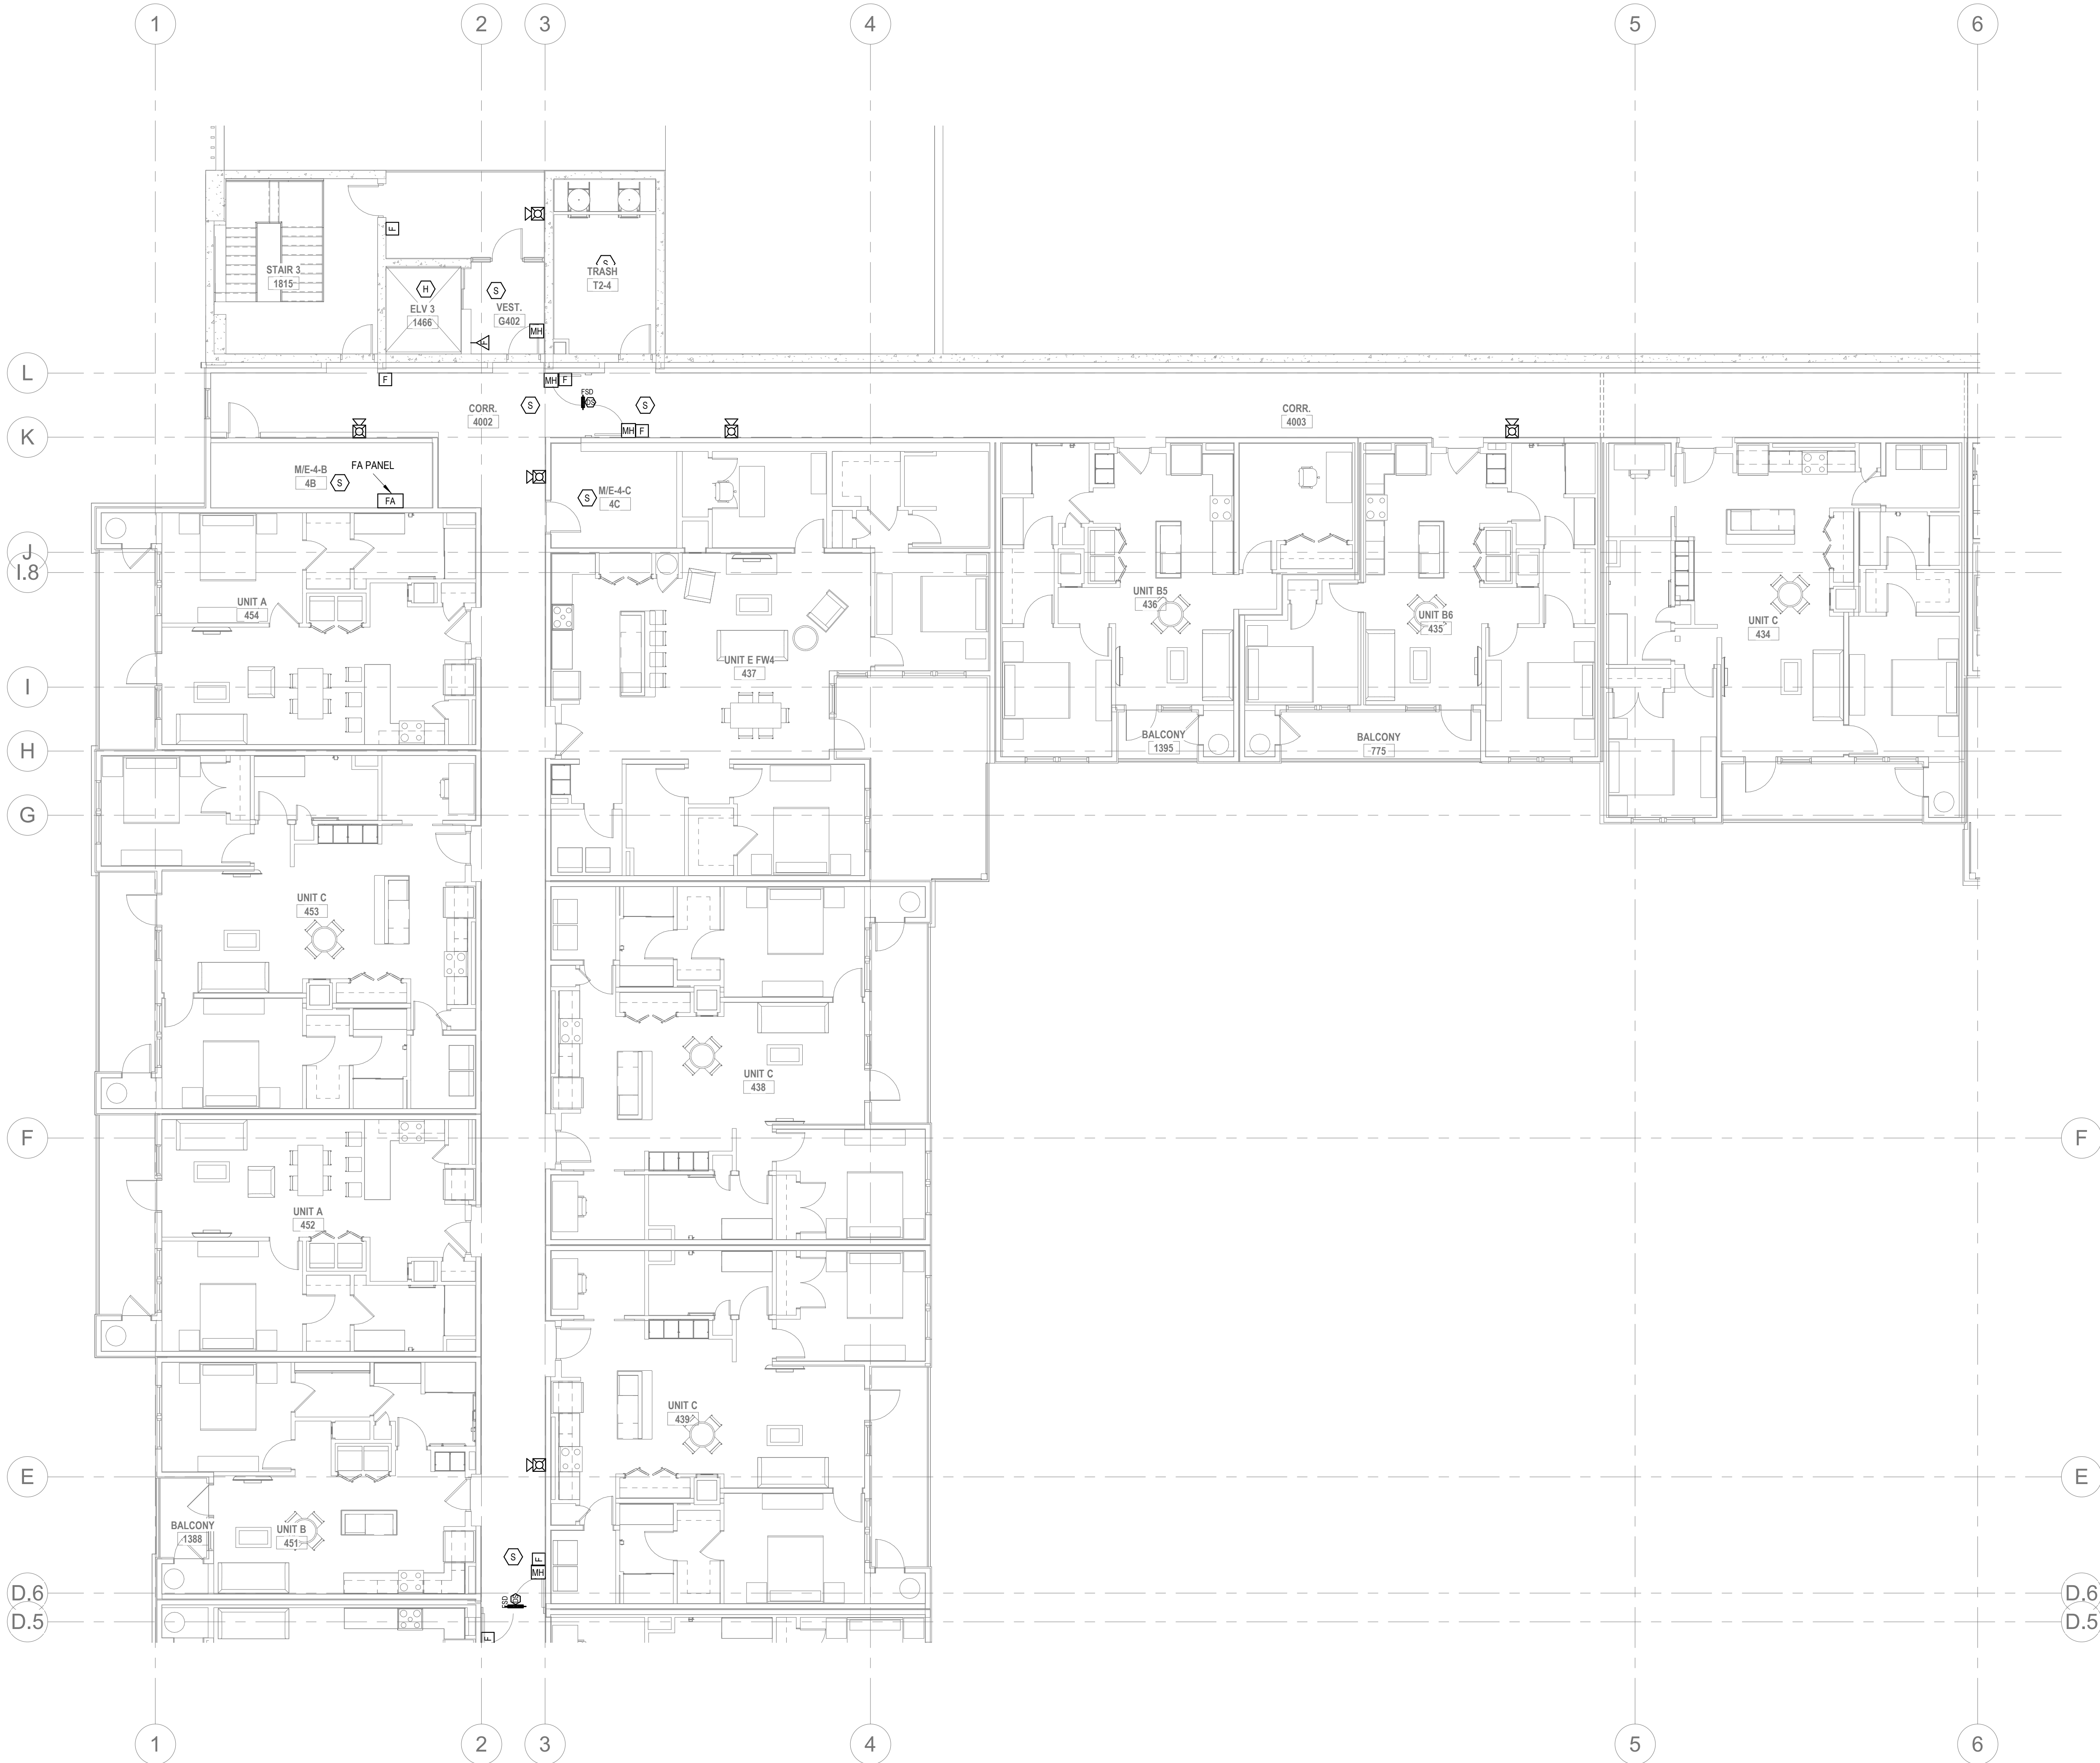

2 FIRE ALARM - FOURTH FLOOR ENLARGED PLAN C
1/8" = 1'-0"

ALL REPORTS, PLANS, SPECIFICATIONS AND COMPUTER FILES RELATING TO THIS PROJECT ARE THE PROPERTY OF THE MARTIN ARCHITECTURAL GROUP. THE MARTIN ARCHITECTURAL GROUP RETAINS ALL COMMON LAW, STATUTE AND OTHER RESERVED RIGHTS INCLUDING THE COPY RIGHT THERE TO. REPRODUCTION OF THE MATERIAL HEREIN OR SUBSTANTIAL USE WITHOUT WRITTEN PERMISSION OF THE MARTIN ARCHITECTURAL GROUP VIOLATES THE COPYRIGHT LAWS OF THE UNITED STATES AND WILL BE SUBJECT TO LEGAL PROSECUTION.
© The Martin Architectural Group, P.C.



THE MARTIN ARCHITECTURAL GROUP, P.C.
ARCHITECTS AND LAND PLANNERS
A PROFESSIONAL CORPORATION
240 NORTH 22ND STREET, PHILADELPHIA, PA, 19103
P (215) 665-1086 F (215) 561-5064

P.A.: JTG
P.M.: TRT
DRAWN BY: Author
PROJECT NO: 1022747


NO.	REVISION	DATE
1	SCHEMATIC BUDGET PRICING SET PERMIT SET	11/01/2022 12/20/2022

Project Status

FIRE ALARM - FOURTH FLOOR ENLARGED PLAN C
Granite Run Apartments
MIDDLETOWN TOWNSHIP, PA

SCALE: AS INDICATED
DATE: 11/01/22

Printed: 1/13/2023 12:07:06 PM

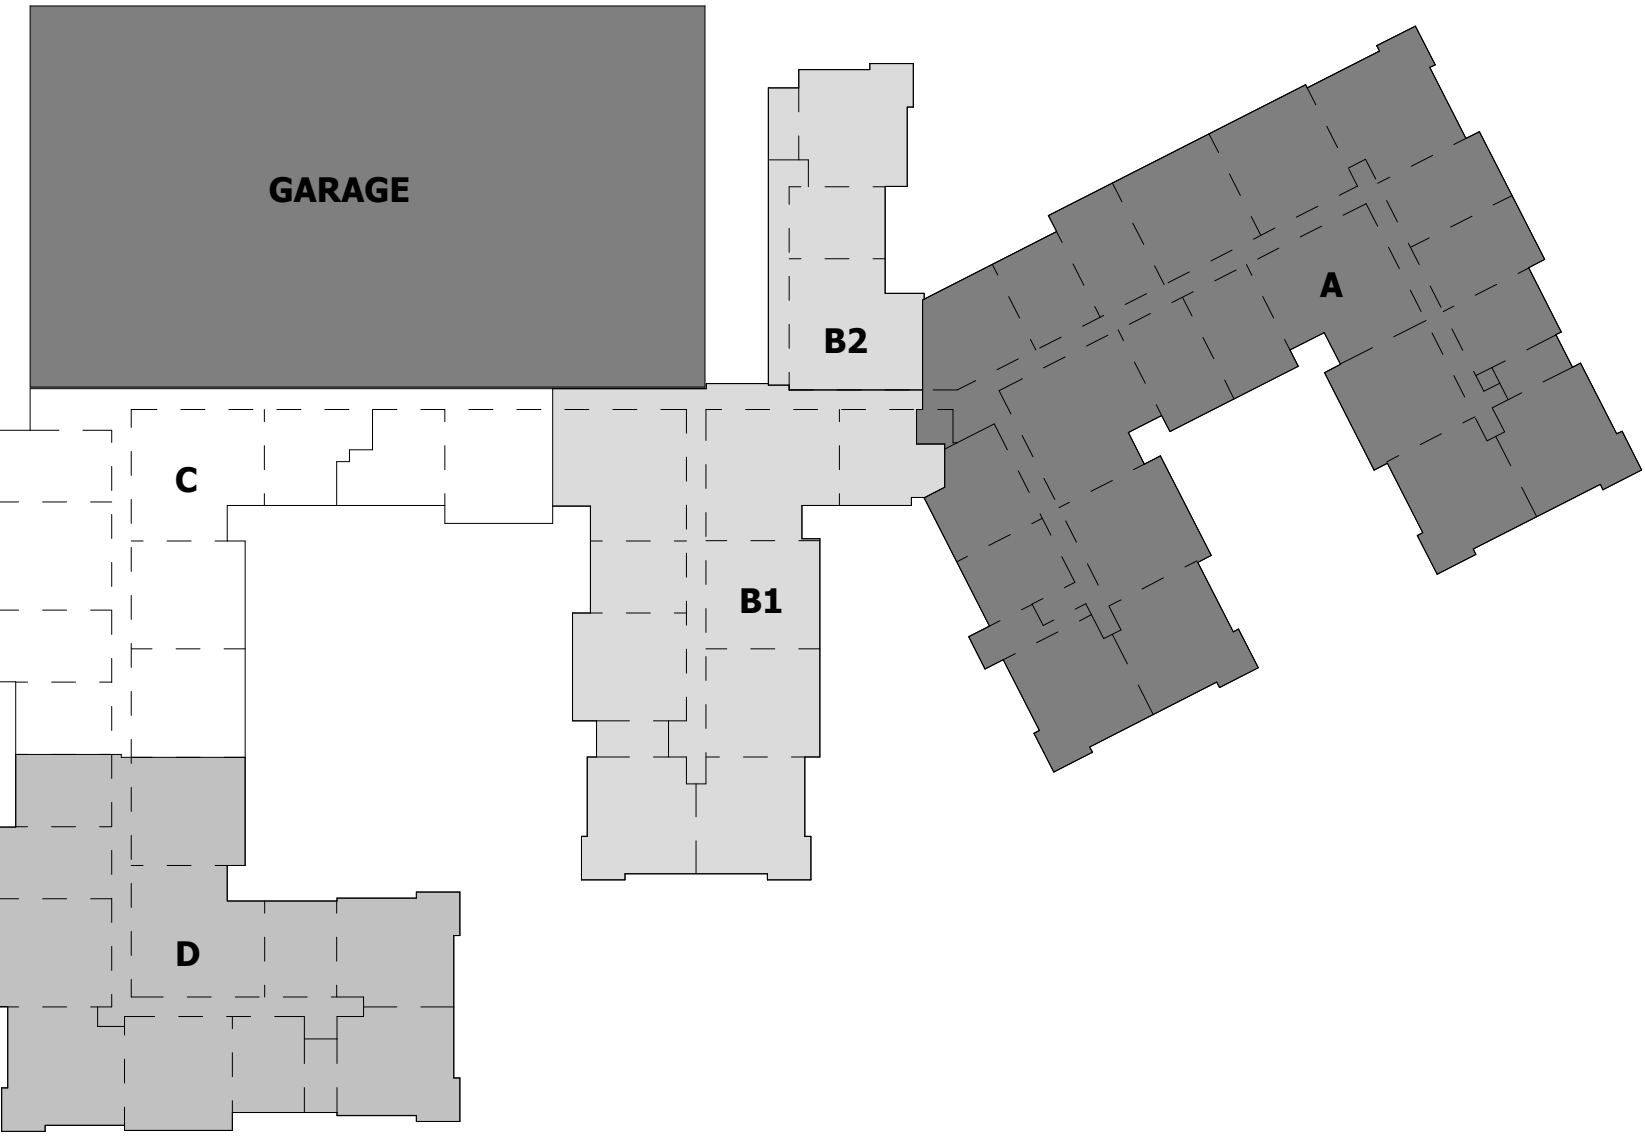

FIRE ALARM GENERAL NOTES

1. REFER TO SHEETS FA0.01 FOR NOTES, SYMBOLS AND ABBREVIATIONS.
2. EC SHALL REFER TO TELECOM, SECURITY & AV DRAWINGS, DETAILS FOR FINAL DEVICE LOCATIONS & RACEWAY REQUIREMENTS.
3. REFER TO MECHANICAL PLANS FOR DUCT SMOKE DETECTOR AND FIRE SMOKE DAMPER LOCATIONS. PROVIDE FA CONNECTION AND WIRE AS REQUIRED.
4. REFER TO FIRE PROTECTION PLANS FOR TAMPER AND FLOW SWITCH LOCATIONS. PROVIDE FA CONNECTION AND WIRE AS REQUIRED.
5. PROVIDE AREA SMOKE DETECTORS IN ELEVATORS LOBBIES AND ELEVATOR MACHINE ROOM(S). SMOKE DETECTORS SHALL BE LOCATED ON THE CEILING WITHIN 21 FEET OF THE CENTERLINE OF EACH ELEVATOR DOOR WITHIN THE ELEVATOR BANK UNDER CONTROL OF THE DETECTOR FOR ELEVATOR LOBBIES UP TO 15 FEET IN HEIGHT WITH FLAT AND SMOOTH CEILINGS. FOR HIGHER AND UNEVEN CEILINGS, ADDITIONAL SMOKE DETECTORS MAY BE REQUIRED.
6. MANUAL FIRE ALARM BOXES SHALL BE LOCATED WITHIN 5 FEET OF EACH EXIT DOORWAY ON EACH FLOOR.
7. DUCT SMOKE DETECTORS AND DUCT SMOKE DETECTORS TEST STATIONS LOCATIONS TO BE COORDINATED WITH THE MECHANICAL DRAWINGS.
8. PROVIDE AND INSTALL SYSTEM FIRE ALARM ADDRESSABLE DUCT SMOKE DETECTORS AS INDICATED ON THE MECHANICAL FLOOR PLANS AND RISERS FOR FIRE/SMOKE DAMPERS AND SMOKE DAMPERS. PROVIDE ADDRESSABLE CONTROL RELAY AT EACH DAMPER.
9. PROVIDE 120V EMERGENCY POWER TO ALL FIRE/SMOKE AND SMOKE DAMPERS INDICATED ON THE MECHANICAL DRAWINGS.
10. THESE FIRE ALARM DRAWINGS ARE PERFORMANCE SPECIFICATION ONLY. CONTRACTOR SHALL PROVIDE A COMPLETE SYSTEM DESIGN IN COMPLIANCE WITH NFPA 72, THE IBC, NFPA 101, AND ANY OTHER ENFORCED CODES AND AMENDMENTS, INCLUDING ENGINEERED SIGNED AND SEALED DRAWINGS. POINT TO POINT WIRING WITH PROPOSED CIRCUITING OR CONDUIT ROUTING, ALL APPLICABLE CALCULATIONS, DEVICE MANUFACTURERS AND QUANTITIES, WIRING DIAGRAMS, AND SHOP SUBMITTALS. CONTRACTOR SHALL BE RESPONSIBLE FOR ALL ASSOCIATED PERMITS, INSPECTIONS AND TESTING. CONSULT LOCAL BUILDING AUTHORITY AND FIRE MARSHAL REGARDING LOCAL AREA'S REQUIREMENTS.



2 FIRE ALARM - FOURTH FLOOR ENLARGED PLAN D
1/8" = 1'-0"

ALL REPORTS, PLANS, SPECIFICATIONS AND COMPUTER FILES RELATING TO THIS PROJECT ARE THE PROPERTY OF THE MARTIN ARCHITECTURAL GROUP. THE MARTIN ARCHITECTURAL GROUP RETAINS ALL COMMON LAW, STATUTE AND OTHER RESERVED RIGHTS INCLUDING THE COPY RIGHT THERE TO. REPRODUCTION OF THE MATERIAL HEREIN OR SUBSTANTIAL USE WITHOUT WRITTEN PERMISSION OF THE MARTIN ARCHITECTURAL GROUP VIOLATES THE COPYRIGHT LAWS OF THE UNITED STATES AND WILL BE SUBJECT TO LEGAL PROSECUTION.
© The Martin Architectural Group, P.C.



THE MARTIN ARCHITECTURAL GROUP, P.C.
ARCHITECTS AND LAND PLANNERS
A PROFESSIONAL CORPORATION
240 NORTH 22ND STREET, PHILADELPHIA, PA, 19103
P (215) 665-1086 F (215) 561-5064

P.A.: JTG
P.M.: TRT
DRAWN BY: Author
PROJECT NO: 1022747

NO.	REVISION	DATE
1	SEPARATE BUDGET PRICING SET	11/01/2022
1	PERMIT SET	12/20/2022


Project Status

FIRE ALARM - FOURTH FLOOR ENLARGED PLAN D
Granite Run Apartments


MIDDLETOWN TOWNSHIP, PA

SCALE: AS INDICATED
DATE: 11/01/22


FA2.07D
© The Martin Architectural Group, P.C.

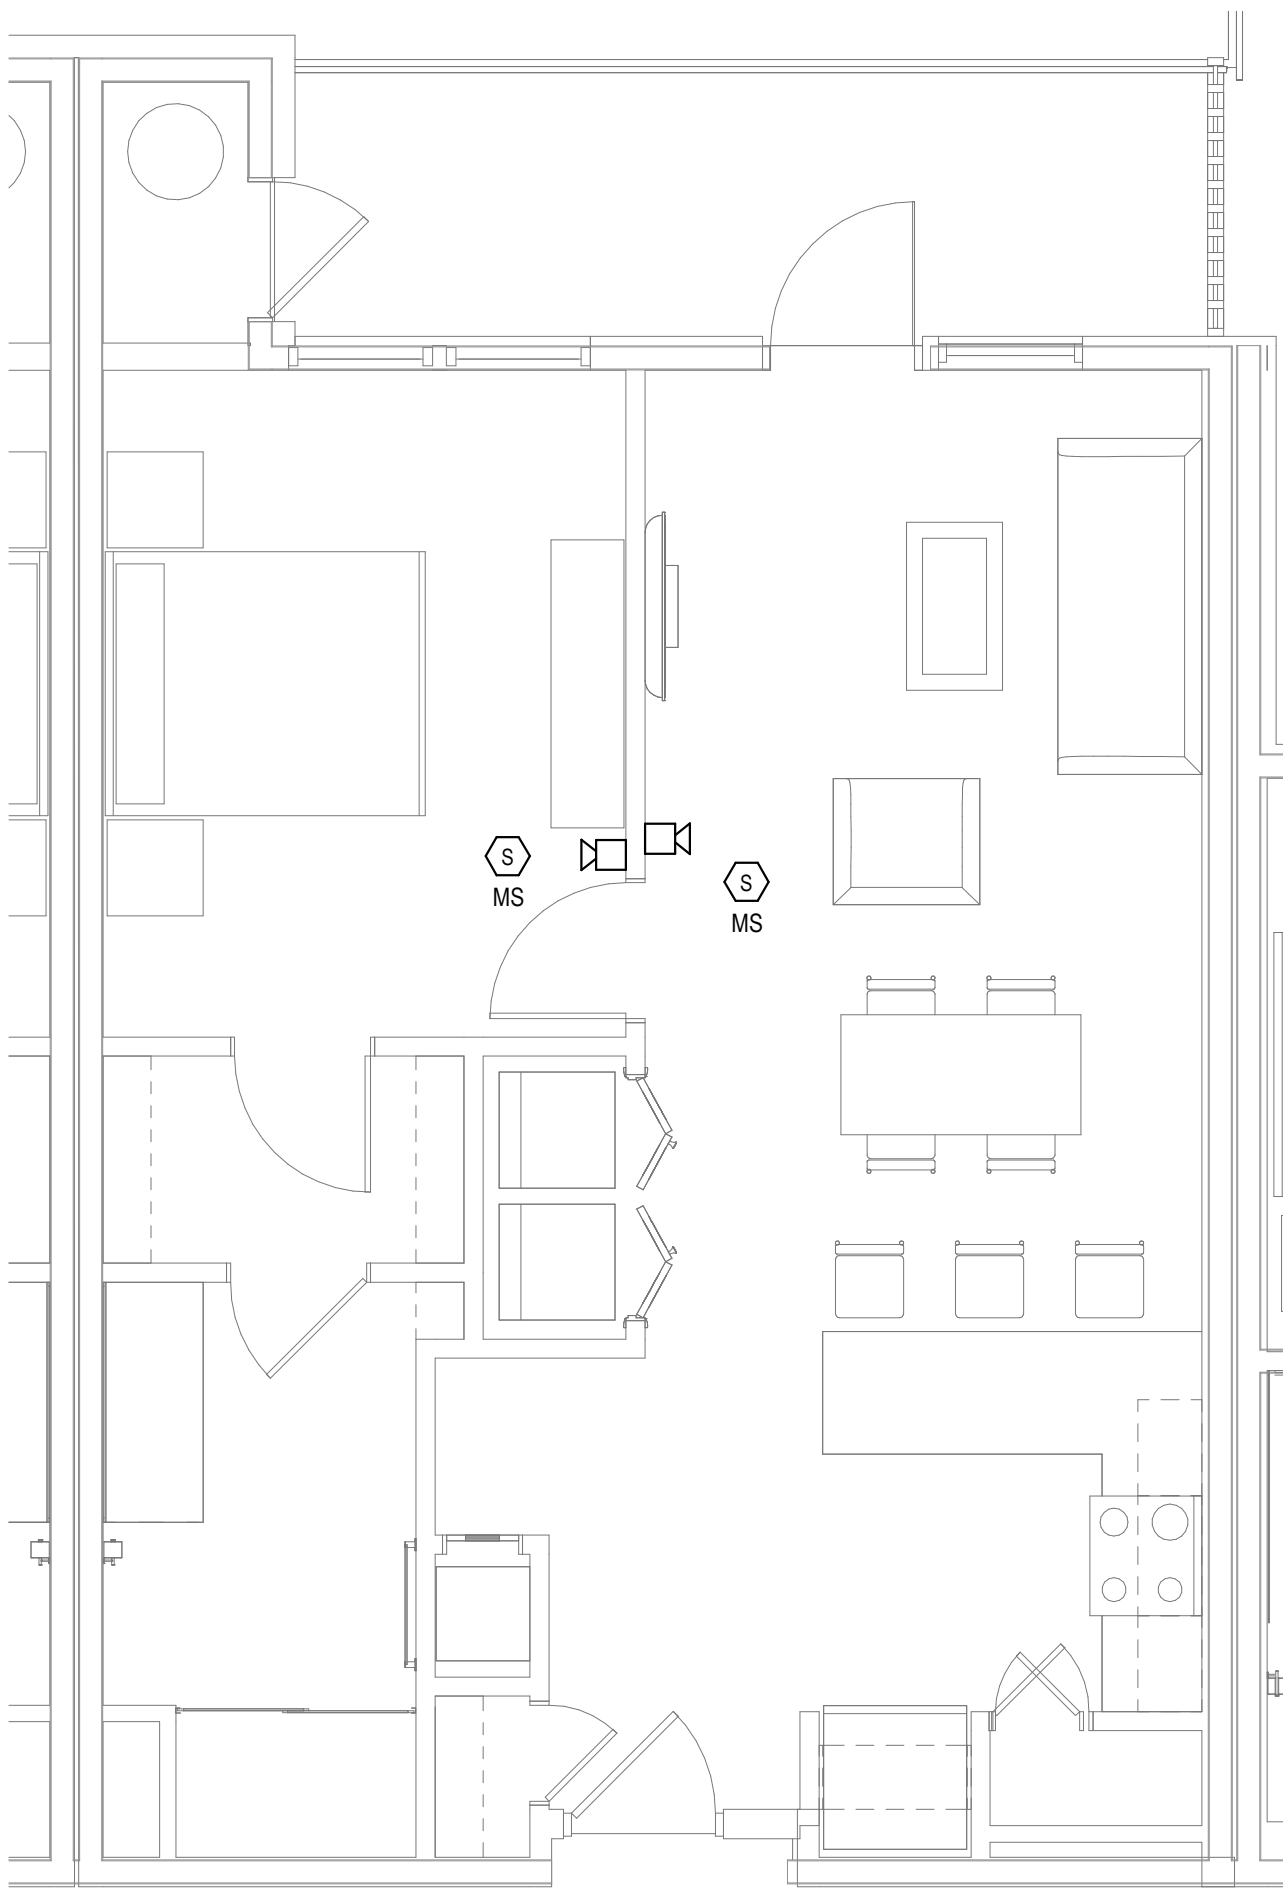


1
FAB.01
FIRE ALARM - UNIT - A PLAN
1/4" = 1'-0"

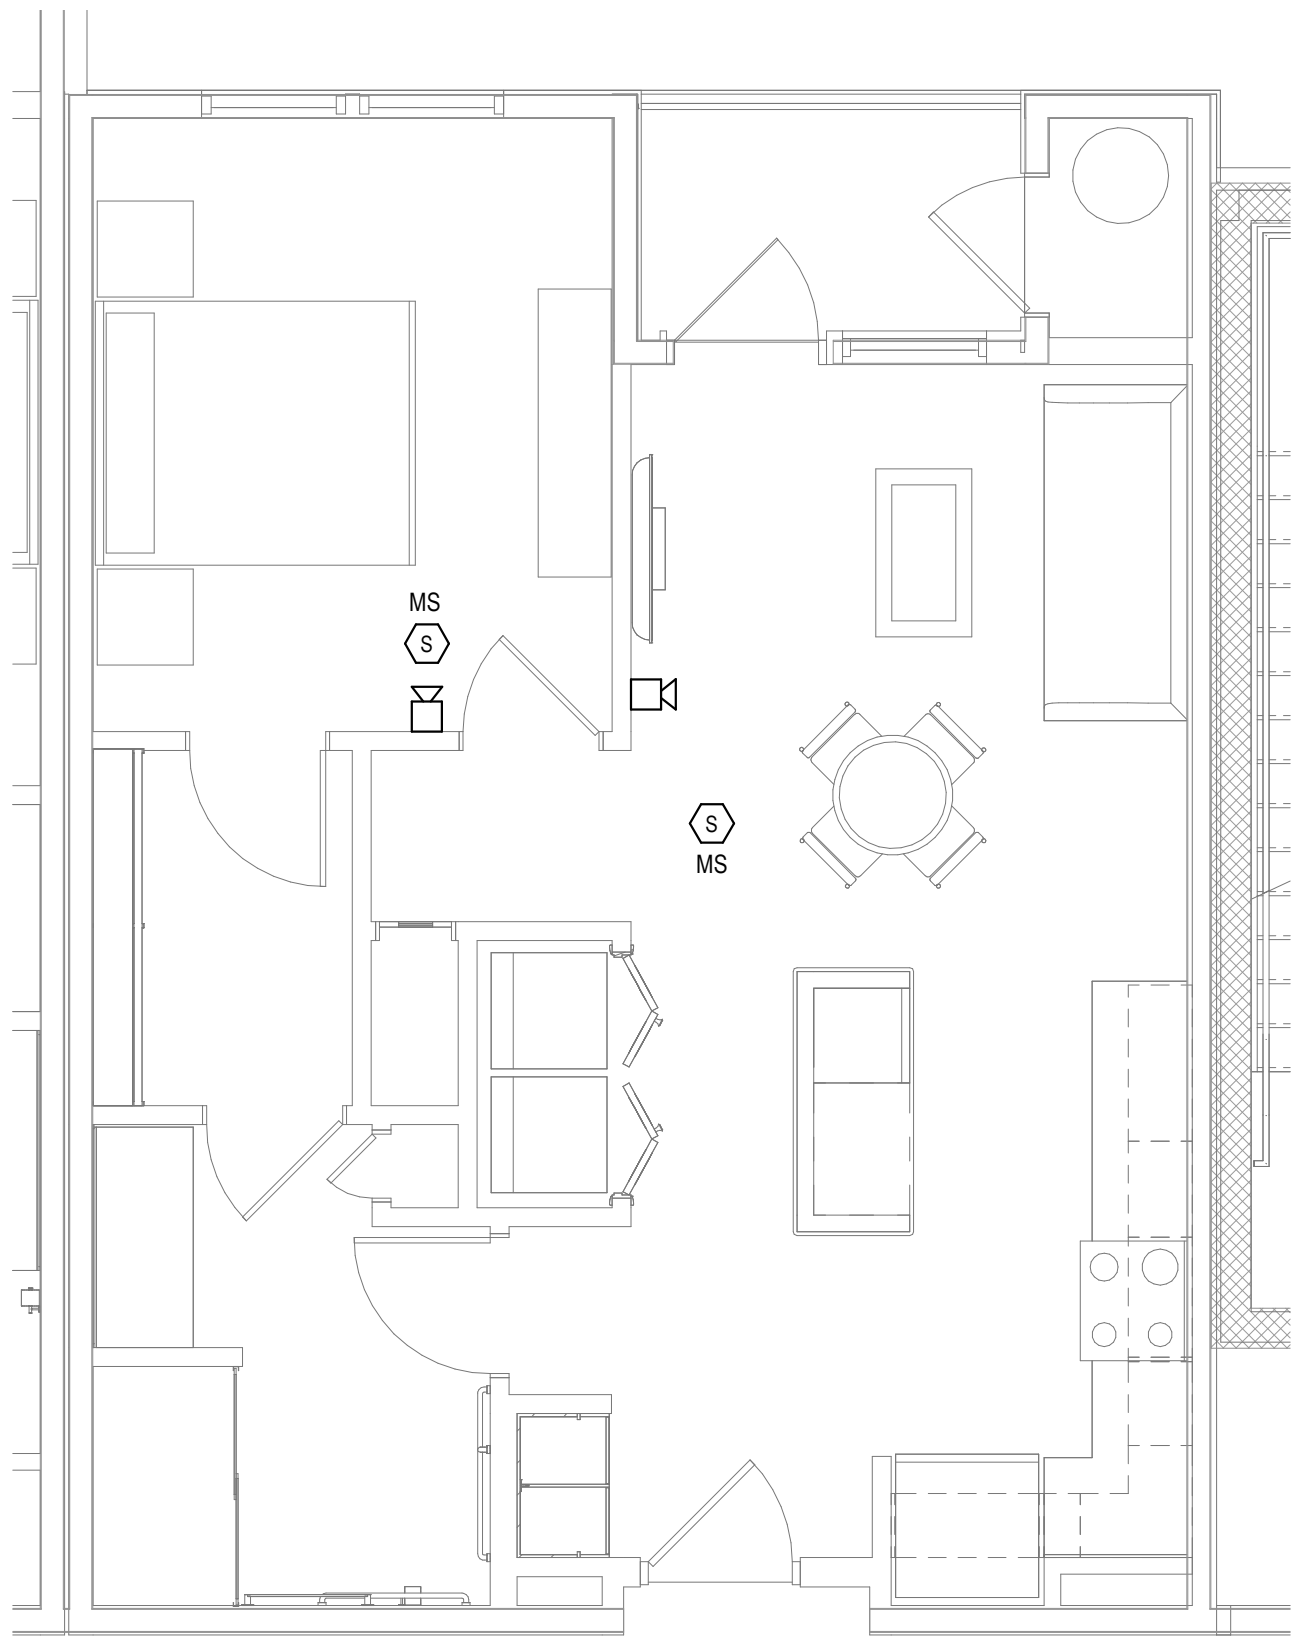


2
FAB.01
FIRE ALARM - UNIT - B PLAN
1/4" = 1'-0"

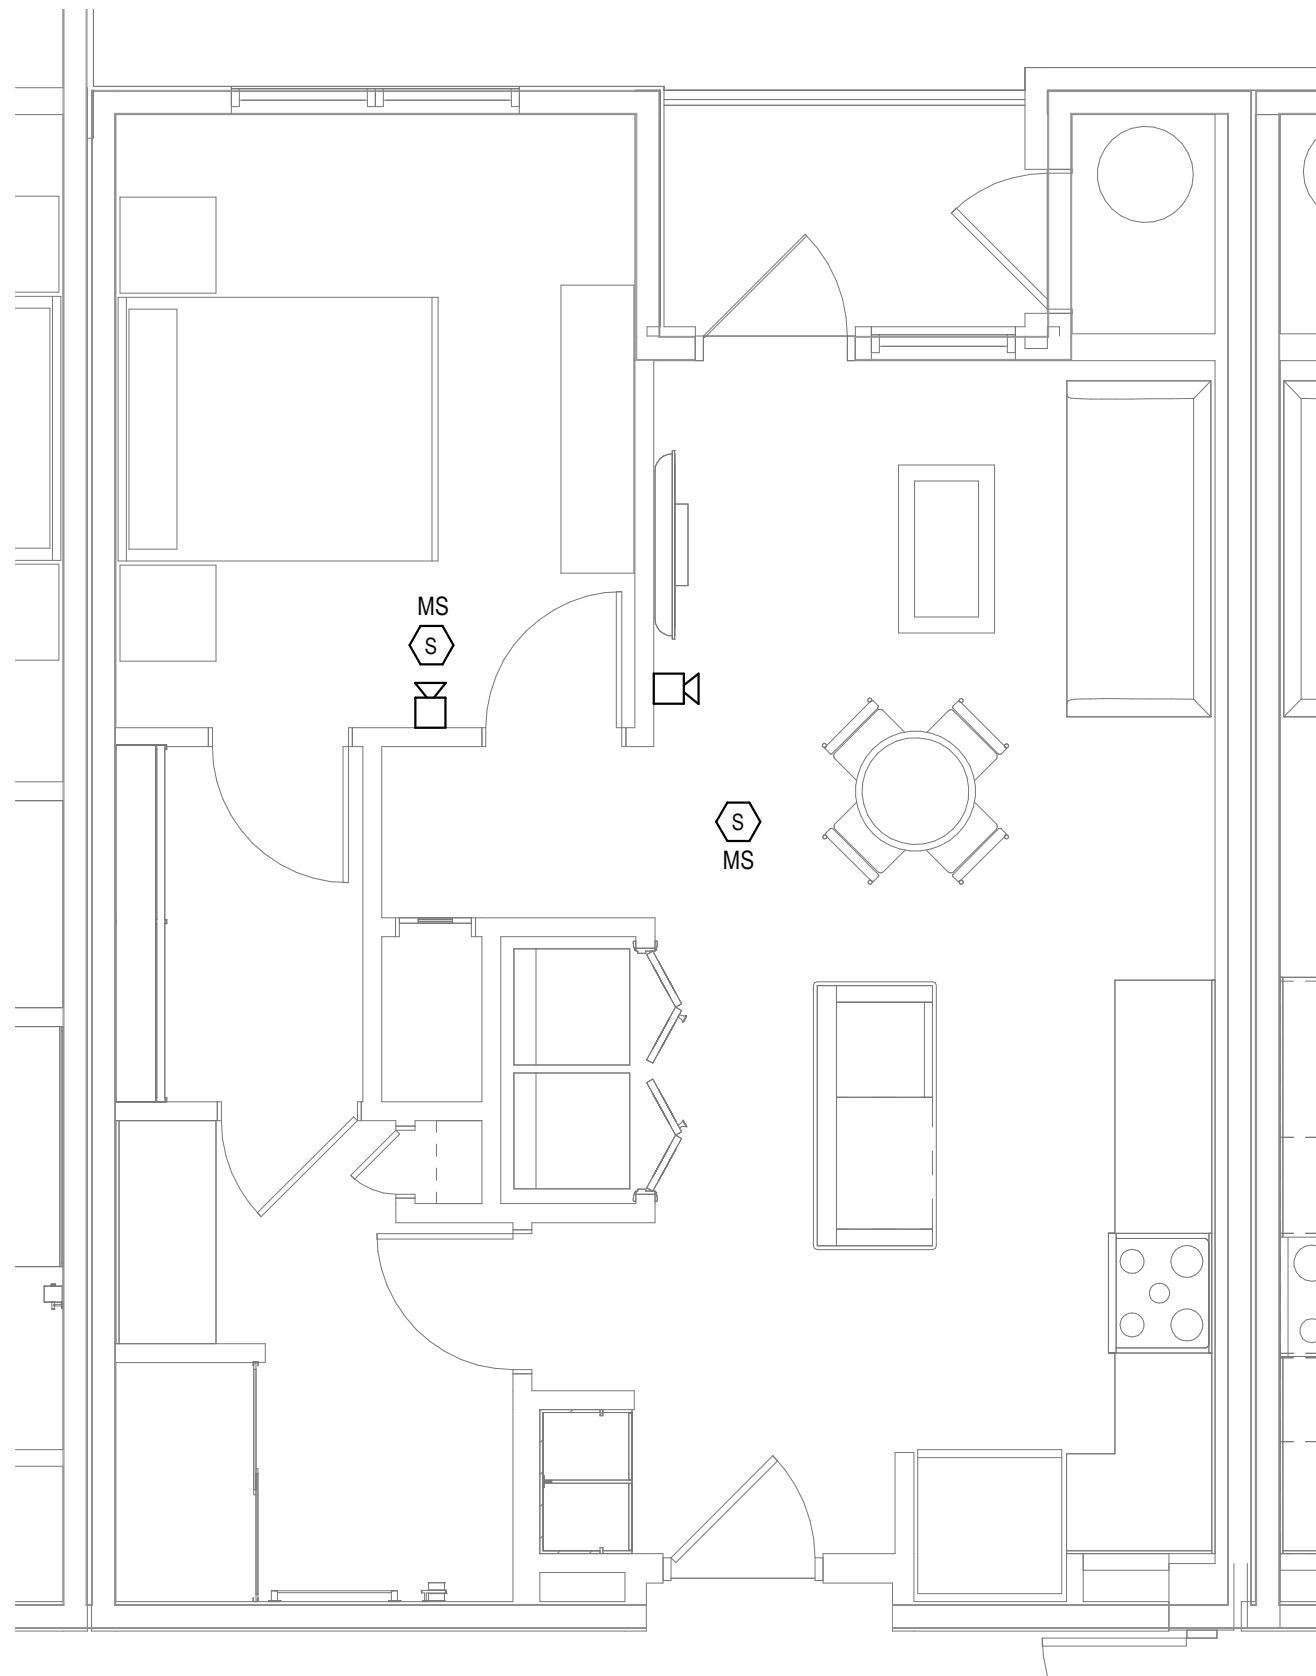

3
FAB.01
FIRE ALARM - UNIT - B (FW-1) PLAN
1/4" = 1'-0"

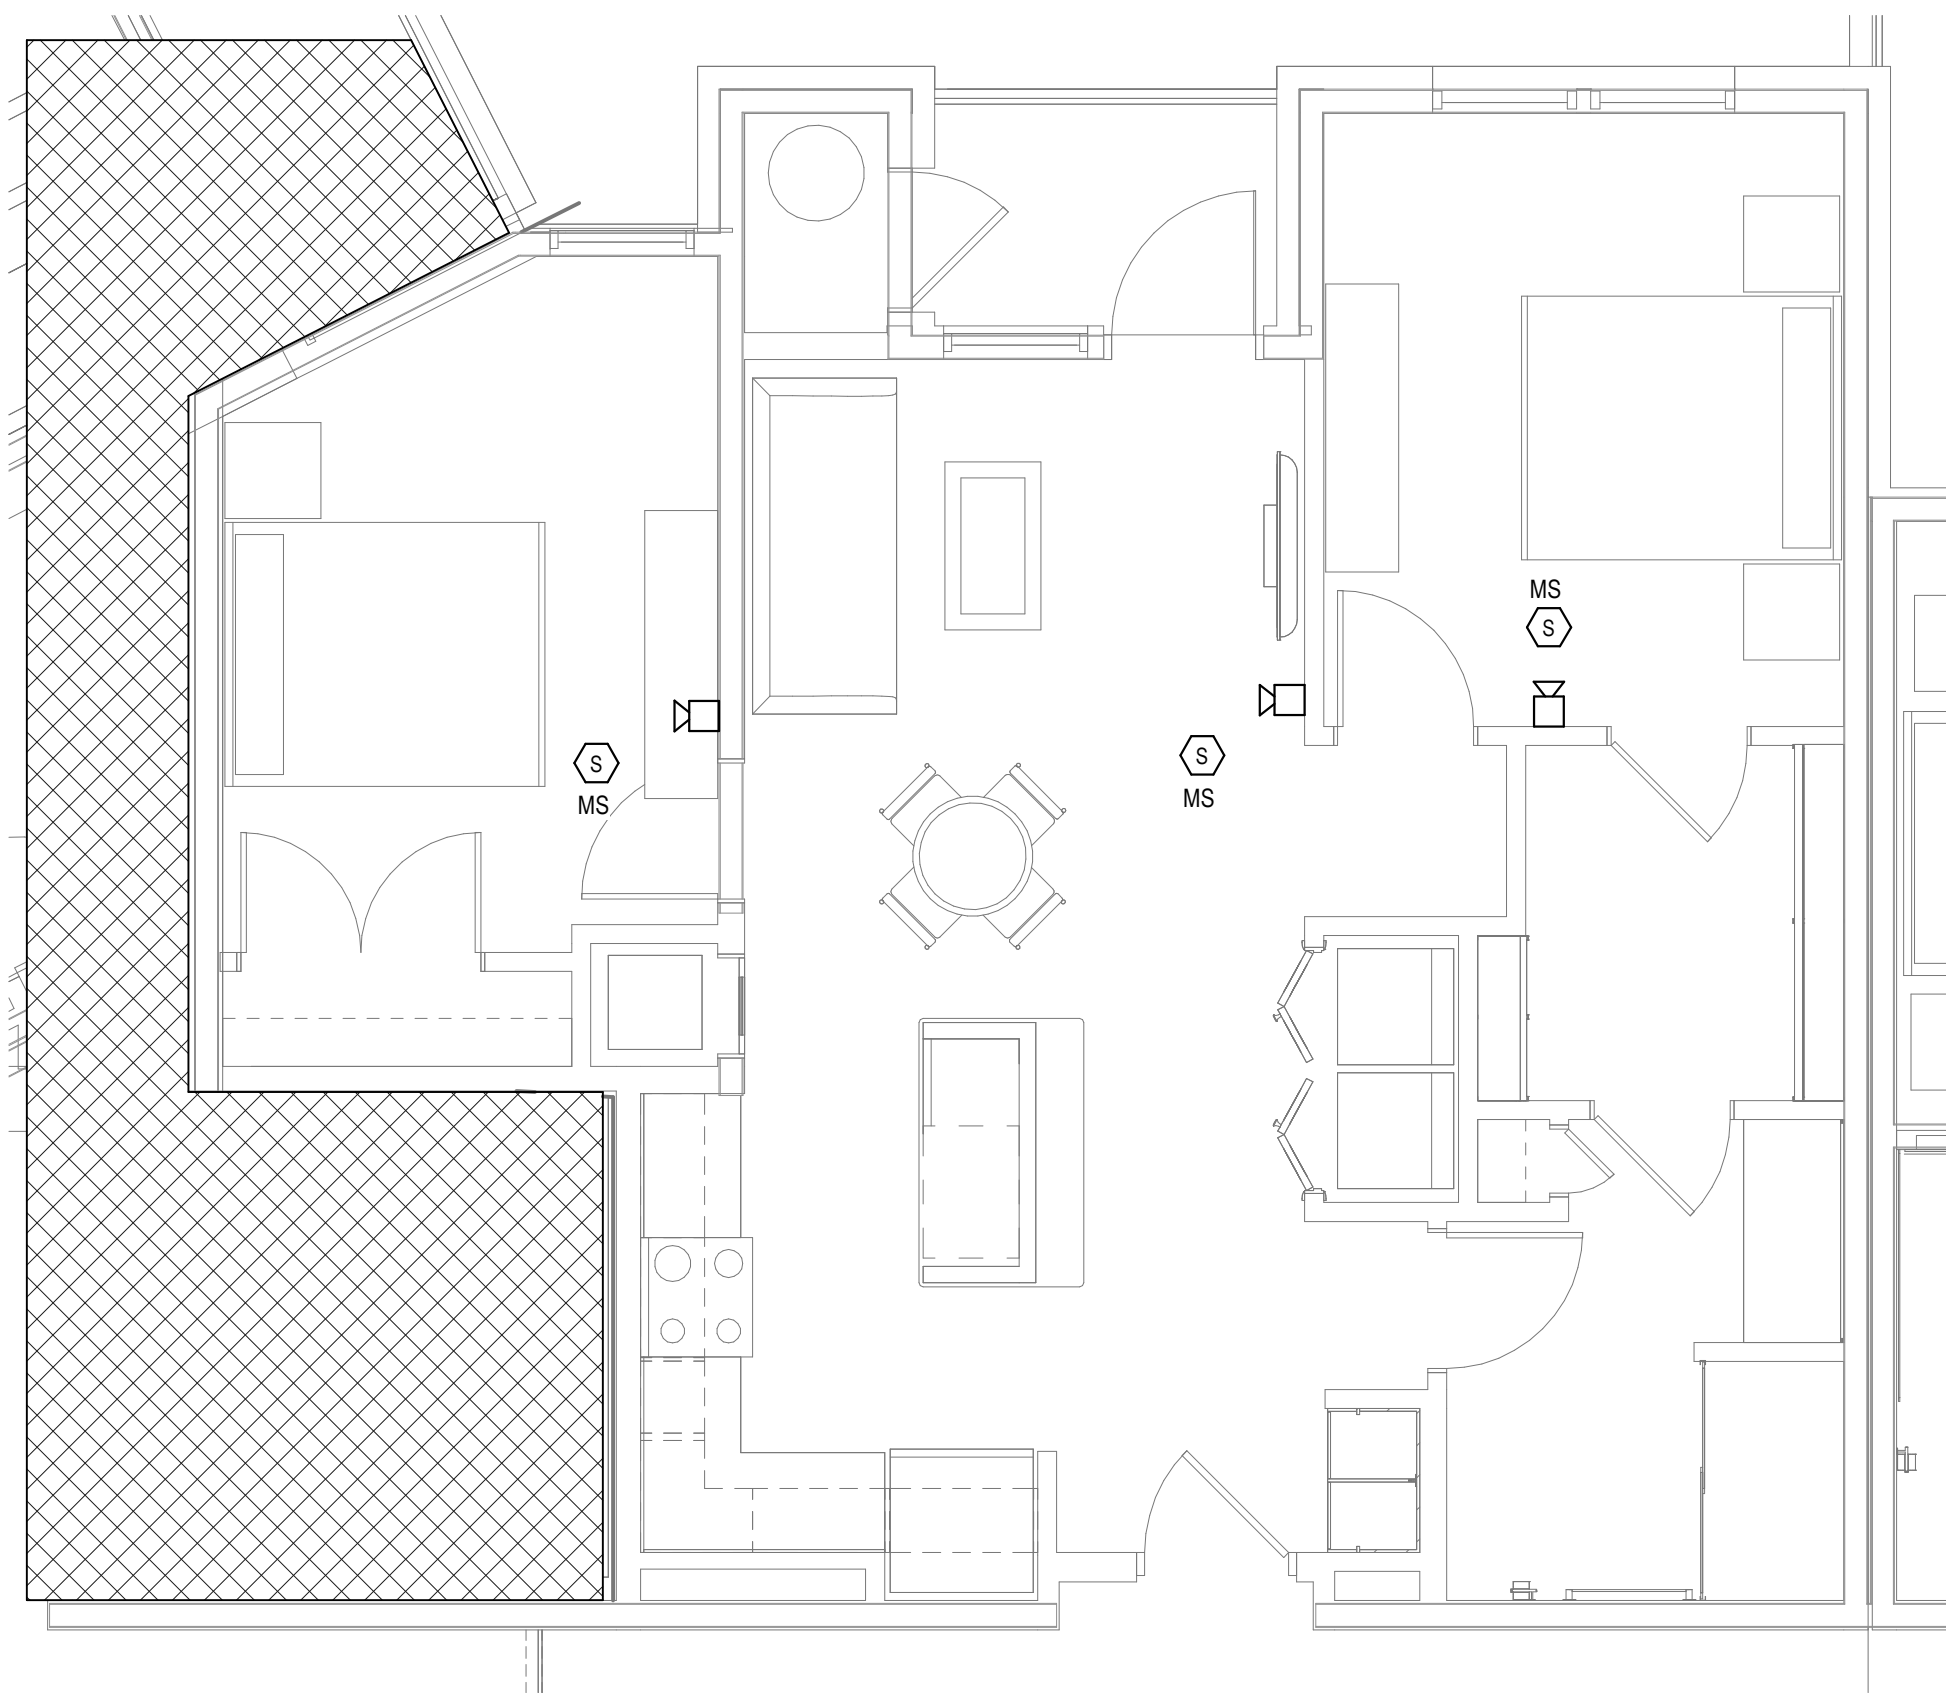

4
FAB.01
FIRE ALARM - UNIT - B2 PLAN
1/4" = 1'-0"

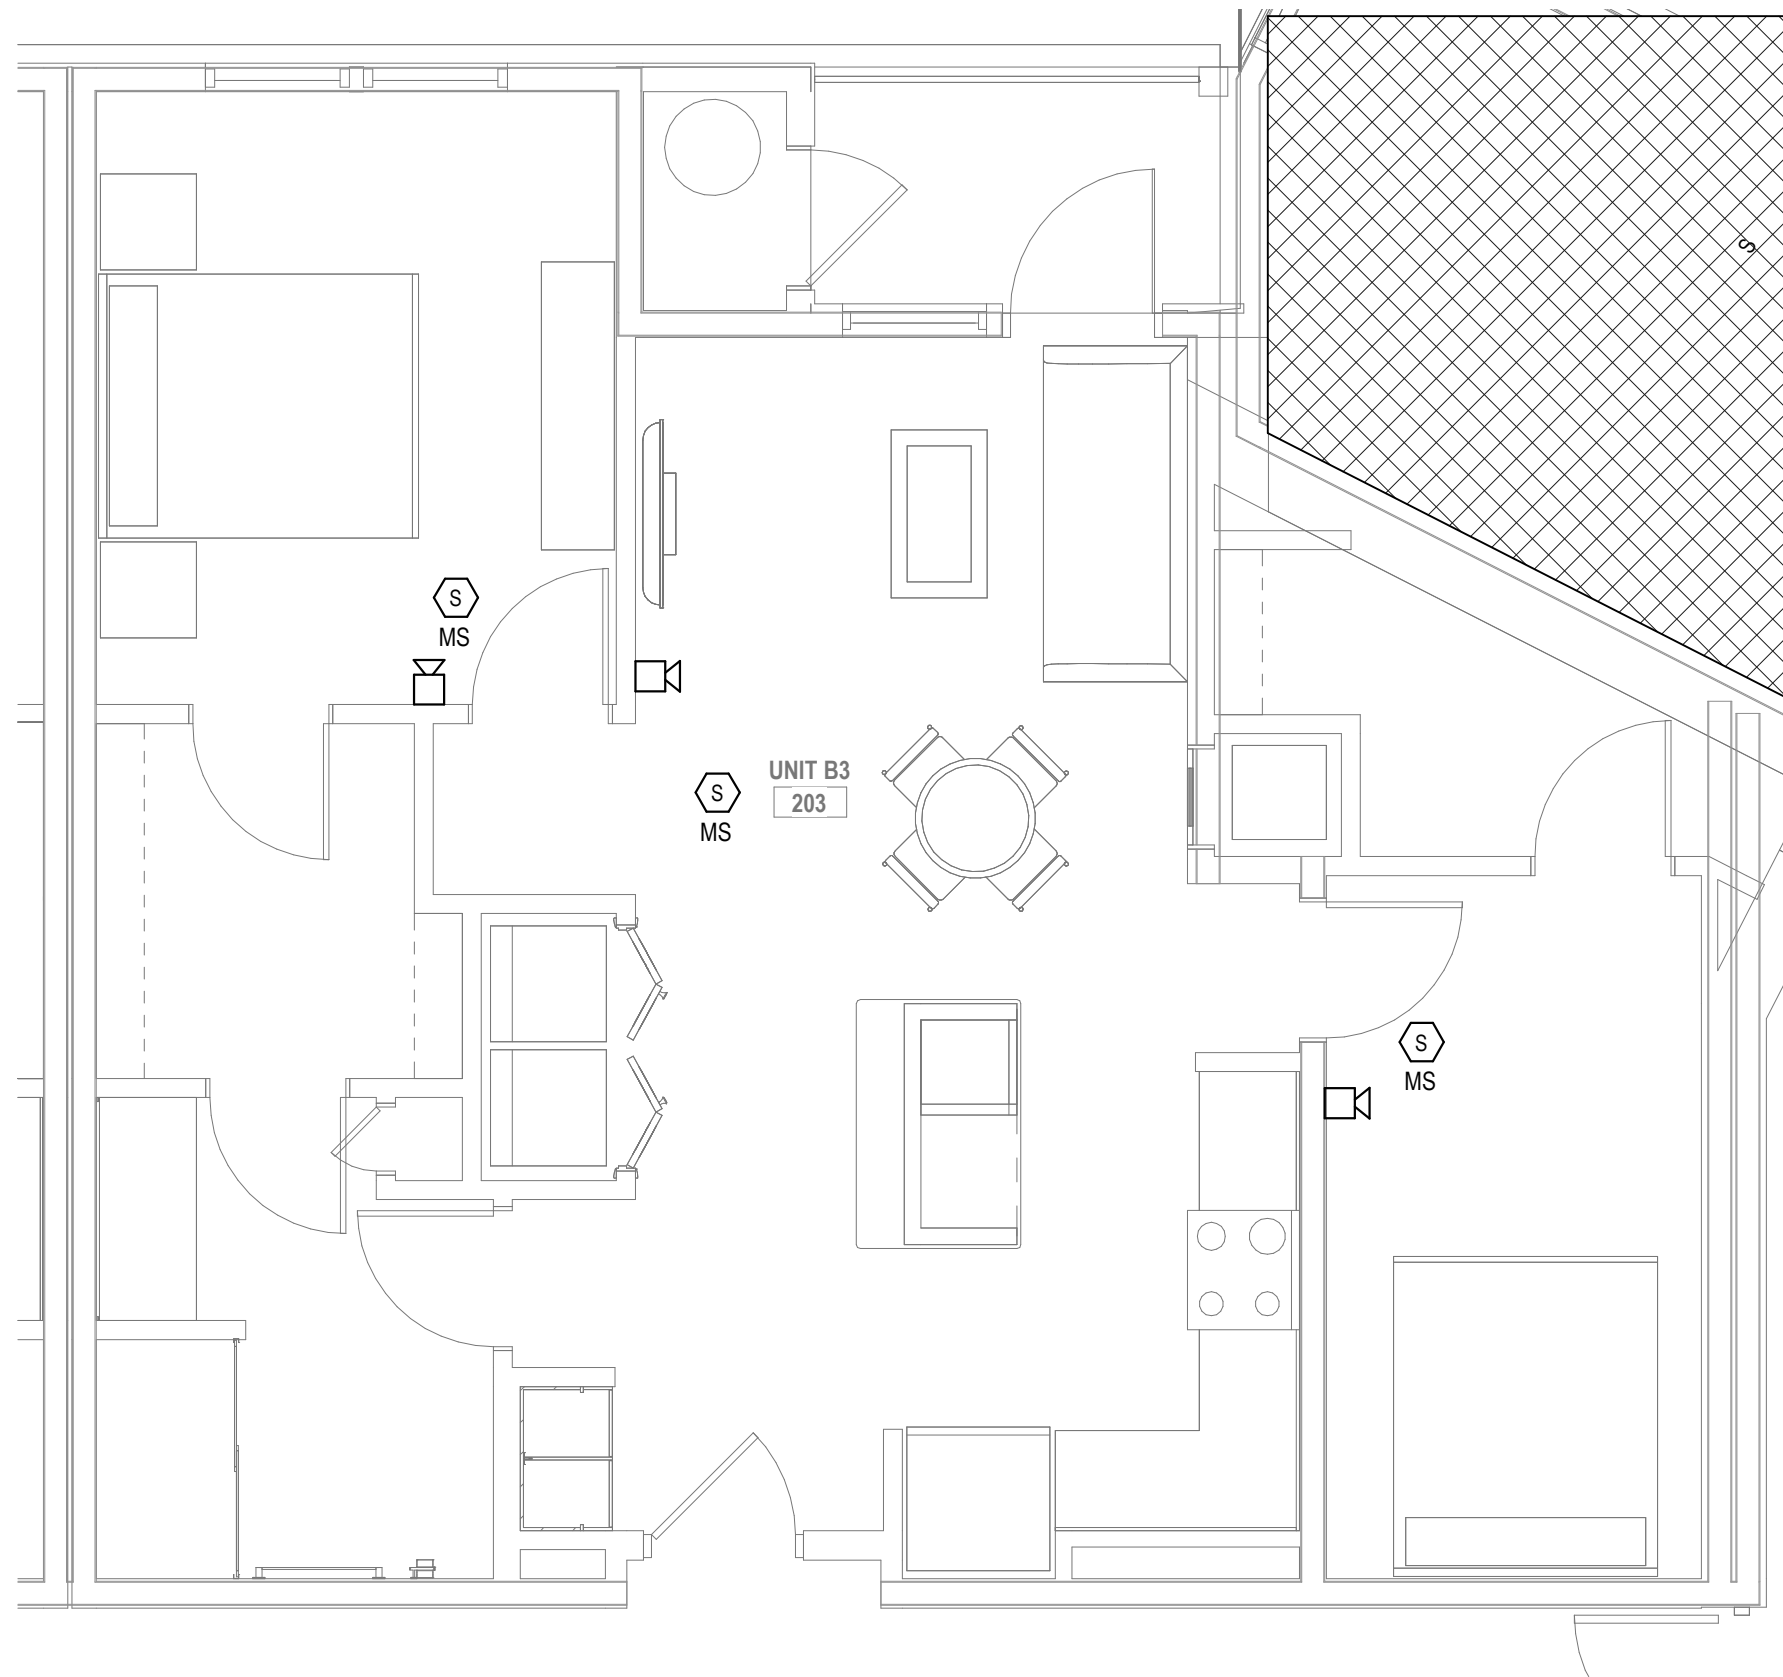


5
FAB.01
FIRE ALARM - UNIT - B3 PLAN
1/4" = 1'-0"

FIRE ALARM GENERAL NOTES

1. REFER TO SHEETS FA0.01 FOR NOTES, SYMBOLS AND ABBREVIATIONS.
2. EC SHALL REFER TO TELECOM, SECURITY & AV DRAWINGS, DETAILS FOR FINAL DEVICE LOCATIONS & RACEWAY REQUIREMENTS.
3. REFER TO MECHANICAL PLANS FOR DUCT SMOKE DETECTOR AND FIRE SMOKE DAMPER LOCATIONS. PROVIDE FA CONNECTION AND WIRE AS REQUIRED.
4. REFER TO FIRE PROTECTION PLANS FOR TAMPER AND FLOW SWITCH LOCATIONS. PROVIDE FA CONNECTION AND WIRE AS REQUIRED.
5. PROVIDE AREA SMOKE DETECTORS IN ELEVATORS LOBBIES AND ELEVATOR MACHINE ROOM(S). SMOKE DETECTORS SHALL BE LOCATED ON THE CEILING WITHIN 21 FEET OF THE CENTERLINE OF EACH ELEVATOR DOOR WITHIN THE ELEVATOR BANK UNDER CONTROL OF THE DETECTOR FOR ELEVATOR LOBBIES UP TO 15 FEET IN HEIGHT WITH FLAT AND SMOOTH CEILINGS. FOR HIGHER AND UNEVEN CEILINGS, ADDITIONAL SMOKE DETECTORS MAY BE REQUIRED.
6. MANUAL FIRE ALARM BOXES SHALL BE LOCATED WITHIN 5 FEET OF EACH EXIT DOORWAY ON EACH FLOOR.
7. DUCT SMOKE DETECTORS AND DUCT SMOKE DETECTORS TEST STATIONS LOCATIONS TO BE COORDINATED WITH THE MECHANICAL DRAWINGS.
8. PROVIDE AND INSTALL SYSTEM FIRE ALARM ADDRESSABLE DUCT SMOKE DETECTORS AS INDICATED ON THE MECHANICAL FLOOR PLANS AND RISERS FOR FIRE SMOKE DAMPERS AND SMOKE DAMPERS. PROVIDE ADDRESSABLE CONTROL RELAY AT EACH DAMPER.
9. PROVIDE 120V EMERGENCY POWER TO ALL FIRES/SMOKE AND SMOKE DAMPERS INDICATED ON THE MECHANICAL DRAWINGS.
10. THESE FIRE ALARM DRAWINGS ARE PERFORMANCE SPECIFICATION ONLY. CONTRACTOR SHALL PROVIDE A COMPLETE SYSTEM DESIGN IN COMPLIANCE WITH NFPA 72, THE IBC, NFPA 101, AND ANY OTHER ENFORCED CODES AND AMENDMENTS, INCLUDING ENGINEERED SIGNED AND SEALED DRAWINGS, POINT TO POINT WIRING WITH PROPOSED CIRCUITING OR CONDUIT ROUTING, ALL APPLICABLE CALCULATIONS, DEVICE MANUFACTURERS AND QUANTITIES, WIRING DIAGRAMS, AND SHOP SUBMITTALS. CONTRACTOR SHALL BE RESPONSIBLE FOR ALL ASSOCIATED PERMITS, INSPECTIONS, AND TESTING. CONSULT LOCAL BUILDING AUTHORITY AND FIRE MARSHAL REGARDING LOCAL AREA'S REQUIREMENTS.
11. FIRE ALARM NOTIFICATION STROBE CIRCUIT CAPACITY TO BE PROVIDED TO ACCOMMODATE FUTURE CONVERSION OF ANY GIVEN APARTMENT TO A 'HEARING IMPAIRED UNIT'. ADDITIONALLY, PROVIDE MEANS TO ACCOMMODATE FUTURE DOORBELL AND STROBE SYSTEM FOR ANY FUTURE 'HEARING IMPAIRED UNIT'.

ALL REPORTS, PLANS, SPECIFICATIONS AND COMPUTER FILES RELATING TO THIS PROJECT ARE THE PROPERTY OF THE MARTIN ARCHITECTURAL GROUP. THE MARTIN ARCHITECTURAL GROUP RETAINS ALL COMMON LAW, STATUTE AND OTHER RESERVED RIGHTS INCLUDING THE COPY RIGHT THEREIN. REPRODUCTION OF THE MATERIAL HEREIN OR SUBSTANTIAL USE WITHOUT WRITTEN PERMISSION OF THE MARTIN ARCHITECTURAL GROUP VIOLATES THE COPYRIGHT LAWS OF THE UNITED STATES AND WILL BE SUBJECT TO LEGAL PROSECUTION.

© The Martin Architectural Group, P.C.

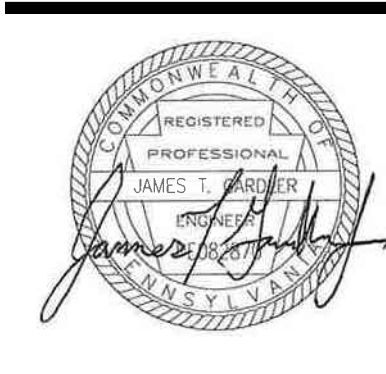

THE MARTIN ARCHITECTURAL GROUP, P.C.
ARCHITECTS AND LAND PLANNERS
A PROFESSIONAL CORPORATION
240 NORTH 22ND STREET, PHILADELPHIA, PA, 19103
P (215) 665-1060 F (215) 561-5064

P.A.: JTG
P.M.: TRT
DRAWN BY: Author
PROJECT NO: 1022747

NO.	REVISION	DATE
1	SCHEMATIC BUDGET PRICING SET	11/01/2022
1	PERMIT SET	12/20/2022


Project Status

FIRE ALARM - UNIT PLANS
Granite Run Apartments
MIDDLETOWN TOWNSHIP, PA


SCALE: AS INDICATED
DATE: 11/01/22

FA6.01


© The Martin Architectural Group, P.C.

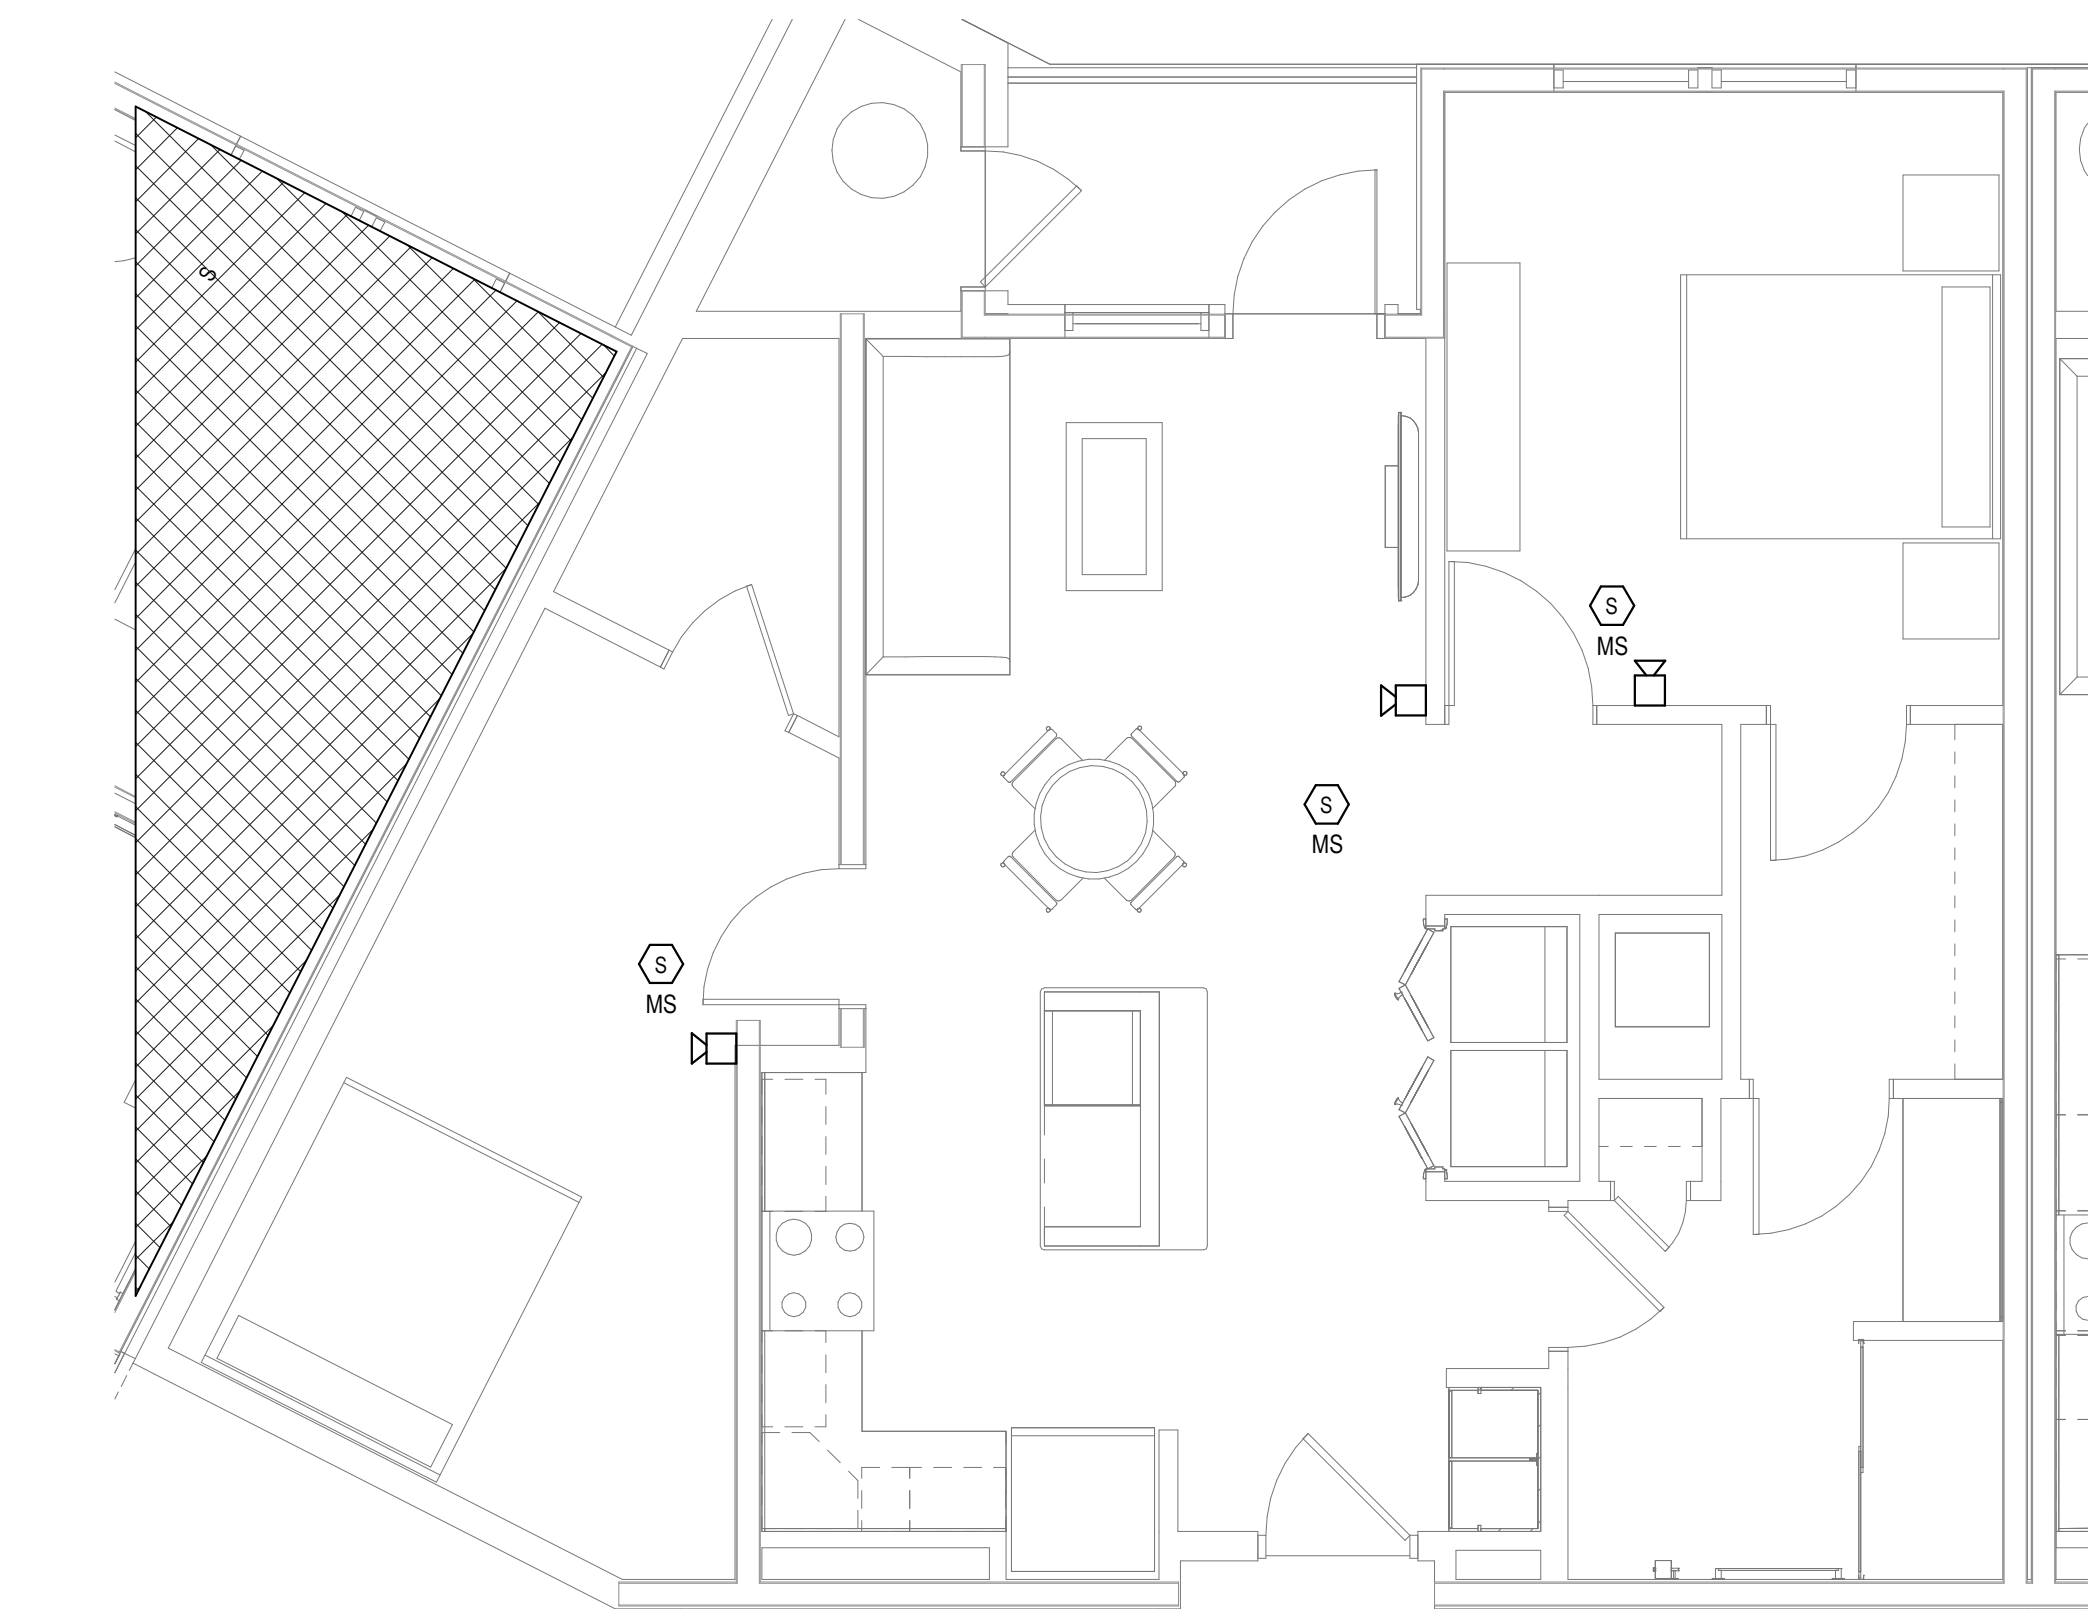

1 FIRE ALARM - UNIT - B4 PLAN
FA6.02 1/4" = 1'-0"

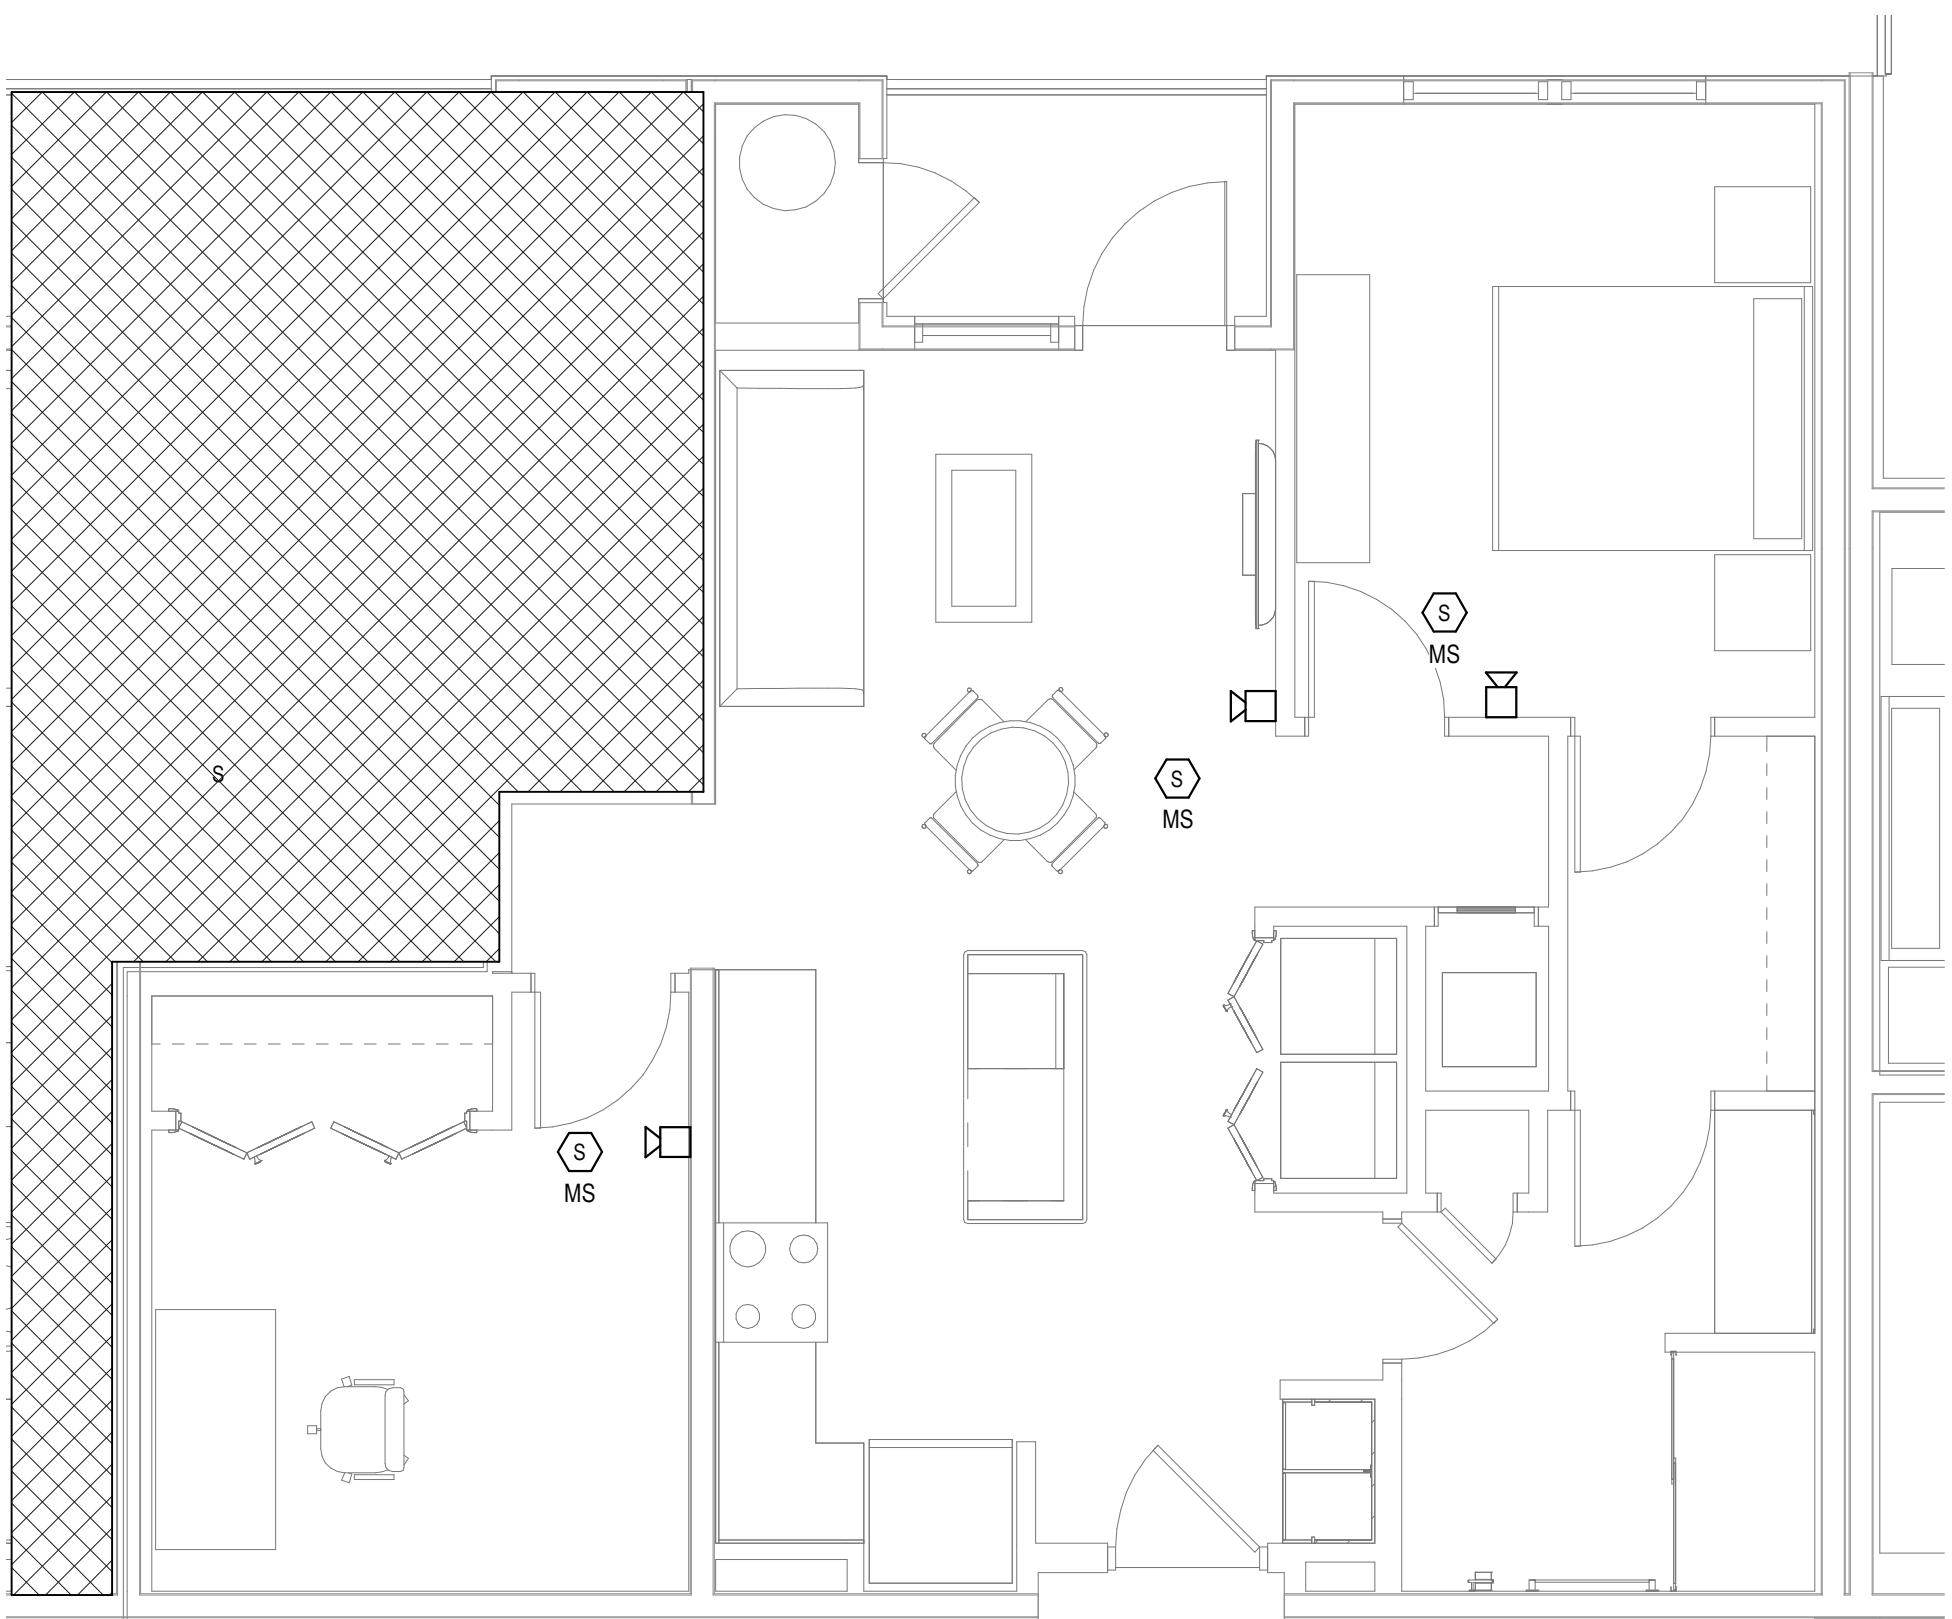

2 FIRE ALARM - UNIT - B5 PLAN
FA6.02 1/4" = 1'-0"

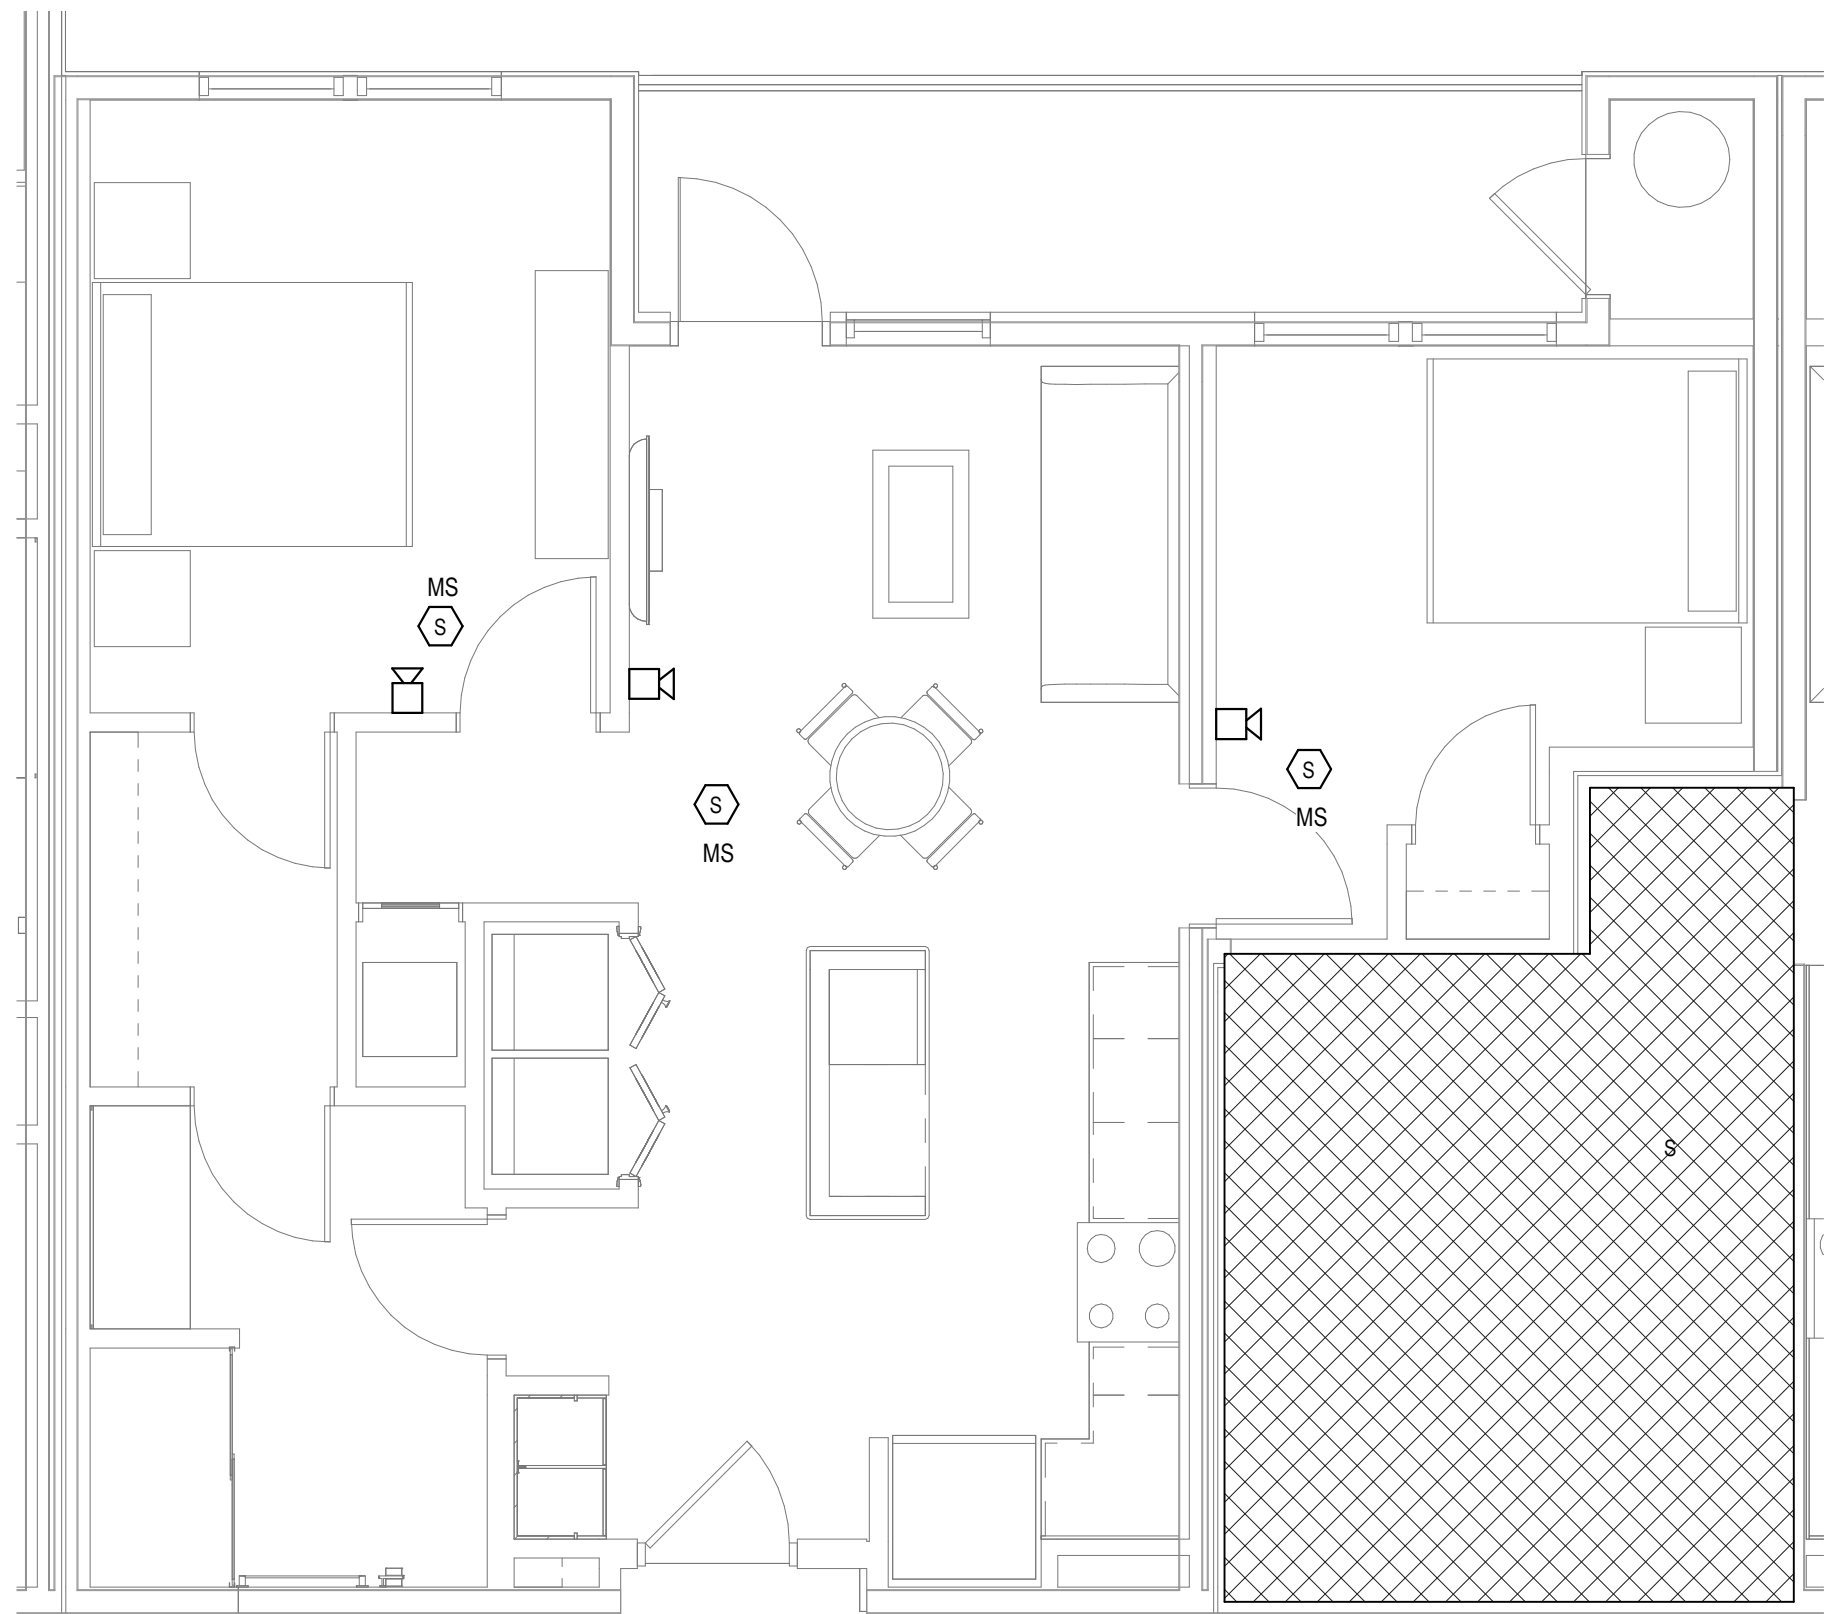

3 FIRE ALARM - UNIT - B6 PLAN
FA6.02 1/4" = 1'-0"

FIRE ALARM GENERAL NOTES

- REFER TO SHEETS FA0.01 FOR NOTES, SYMBOLS AND ABBREVIATIONS.
- EC SHALL REFER TO TELECOM, SECURITY & AV DRAWINGS, DETAILS FOR FINAL DEVICE LOCATIONS & RACEWAY REQUIREMENTS.
- REFER TO MECHANICAL PLANS FOR DUCT SMOKE DETECTOR AND FIRE SMOKE DAMPER LOCATIONS. PROVIDE FA CONNECTION AND WIRE AS REQUIRED.
- REFER TO FIRE PROTECTION PLANS FOR TAMPER AND FLOW SWITCH LOCATIONS. PROVIDE FA CONNECTION AND WIRE AS REQUIRED.
- PROVIDE AREA SMOKE DETECTORS IN ELEVATORS LOBBIES AND ELEVATOR MACHINE ROOM(S). SMOKE DETECTORS SHALL BE LOCATED ON THE CEILING WITHIN 21 FEET OF THE CENTERLINE OF EACH ELEVATOR DOOR WITHIN THE ELEVATOR BANK UNDER CONTROL OF THE DETECTOR FOR ELEVATOR LOBBIES UP TO 15 FEET IN HEIGHT WITH FLAT AND SMOOTH CEILINGS. FOR HIGHER AND UNEVEN CEILINGS, ADDITIONAL SMOKE DETECTORS MAY BE REQUIRED.
- MANUAL FIRE ALARM BOXES SHALL BE LOCATED WITHIN 5 FEET OF EACH EXIT DOORWAY ON EACH FLOOR.
- DUCT SMOKE DETECTORS AND DUCT SMOKE DETECTORS TEST STATIONS LOCATIONS TO BE COORDINATED WITH THE MECHANICAL DRAWINGS.
- PROVIDE AND INSTALL SYSTEM FIRE ALARM ADDRESSABLE DUCT SMOKE DETECTORS AS INDICATED ON THE MECHANICAL FLOOR PLANS AND RISERS FOR FIRE SMOKE DAMPERS AND SMOKE DAMPERS. PROVIDE ADDRESSABLE CONTROL RELAY AT EACH DAMPER.
- PROVIDE 120V EMERGENCY POWER TO ALL FIRE/SMOKE AND SMOKE DAMPERS INDICATED ON THE MECHANICAL DRAWINGS.
- THESE FIRE ALARM DRAWINGS ARE PERFORMANCE SPECIFICATION ONLY. CONTRACTOR SHALL PROVIDE A COMPLETE SYSTEM DESIGN IN COMPLIANCE WITH NFPA 72, THE IBC, NFPA 101, AND ANY OTHER ENFORCED CODES AND AMENDMENTS, INCLUDING ENGINEERED SIGNED AND SEALED DRAWINGS, POINT TO POINT WIRING WITH PROPOSED CIRCUITING OR CONDUIT ROUTING, ALL APPLICABLE CALCULATIONS, DEVICE MANUFACTURERS AND QUANTITIES, WIRING DIAGRAMS, AND SHOP SUBMITTALS. CONTRACTOR SHALL BE RESPONSIBLE FOR ALL ASSOCIATED PERMITS, INSPECTIONS, AND TESTING. CONSULT LOCAL BUILDING AUTHORITY AND FIRE MARSHAL REGARDING LOCAL AREA'S REQUIREMENTS.

ALL REPORTS, PLANS, SPECIFICATIONS AND COMPUTER FILES RELATING TO THIS PROJECT ARE THE PROPERTY OF THE MARTIN ARCHITECTURAL GROUP. THE MARTIN ARCHITECTURAL GROUP RETAINS ALL COMMON LAW, STATUTE AND OTHER RESERVED RIGHTS INCLUDING THE COPY RIGHT THEREIN. REPRODUCTION OF THE MATERIAL HEREIN OR SUBSTANTIAL USE WITHOUT WRITTEN PERMISSION OF THE MARTIN ARCHITECTURAL GROUP VIOLATES THE COPYRIGHT LAWS OF THE UNITED STATES AND WILL BE SUBJECT TO LEGAL PROSECUTION.
© The Martin Architectural Group, P.C.



THE MARTIN ARCHITECTURAL GROUP, P.C.
ARCHITECTS AND LAND PLANNERS
A PROFESSIONAL CORPORATION
240 NORTH 22ND STREET, PHILADELPHIA, PA, 19103
P (215) 665-1080 F (215) 561-5064

P.A.: JTG
P.M.: TRT
DRAWN BY: Author
PROJECT NO: 1022747

NO.	REVISION	DATE
1	SCHEMATIC BUDGET PRICING SET	11/01/2022
1	PERMIT SET	12/20/2022

Project Status


FIRE ALARM - UNIT PLANS
Granite Run Apartments

MIDDLETOWN TOWNSHIP, PA


SCALE: AS INDICATED
DATE: 11/01/22

FA6.02


© The Martin Architectural Group, P.C.

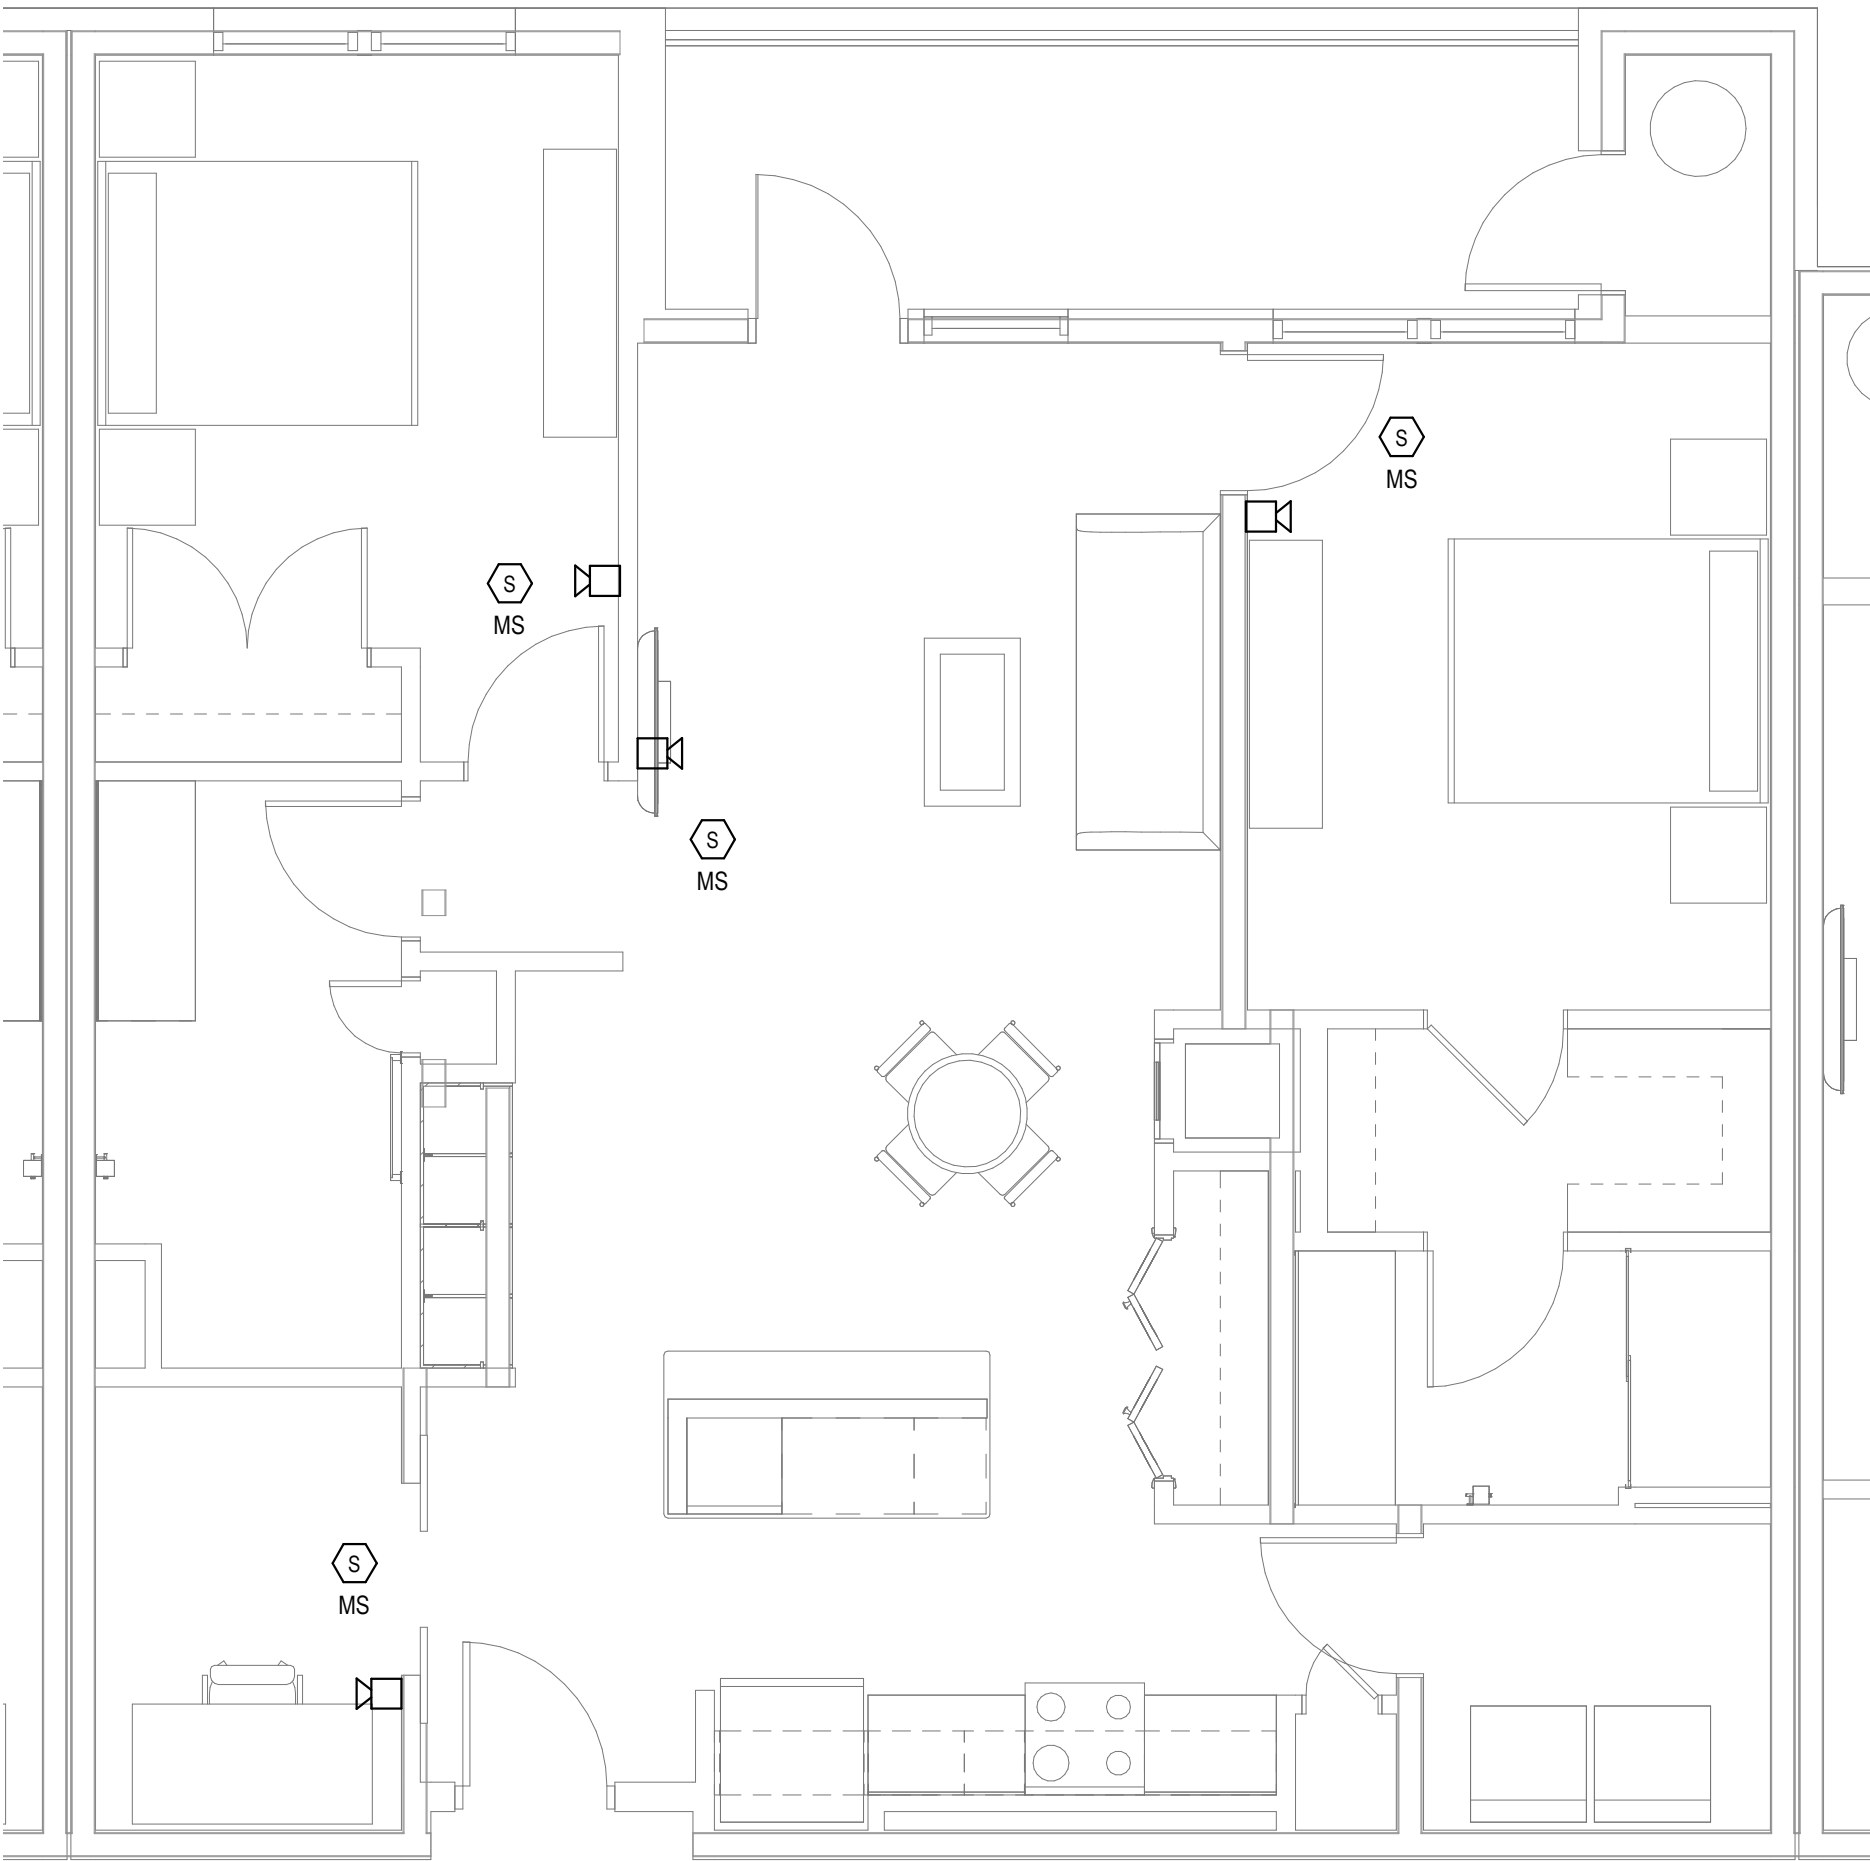

1
FA6.03
FIRE ALARM - UNIT - C PLAN
1/4" = 1'-0"

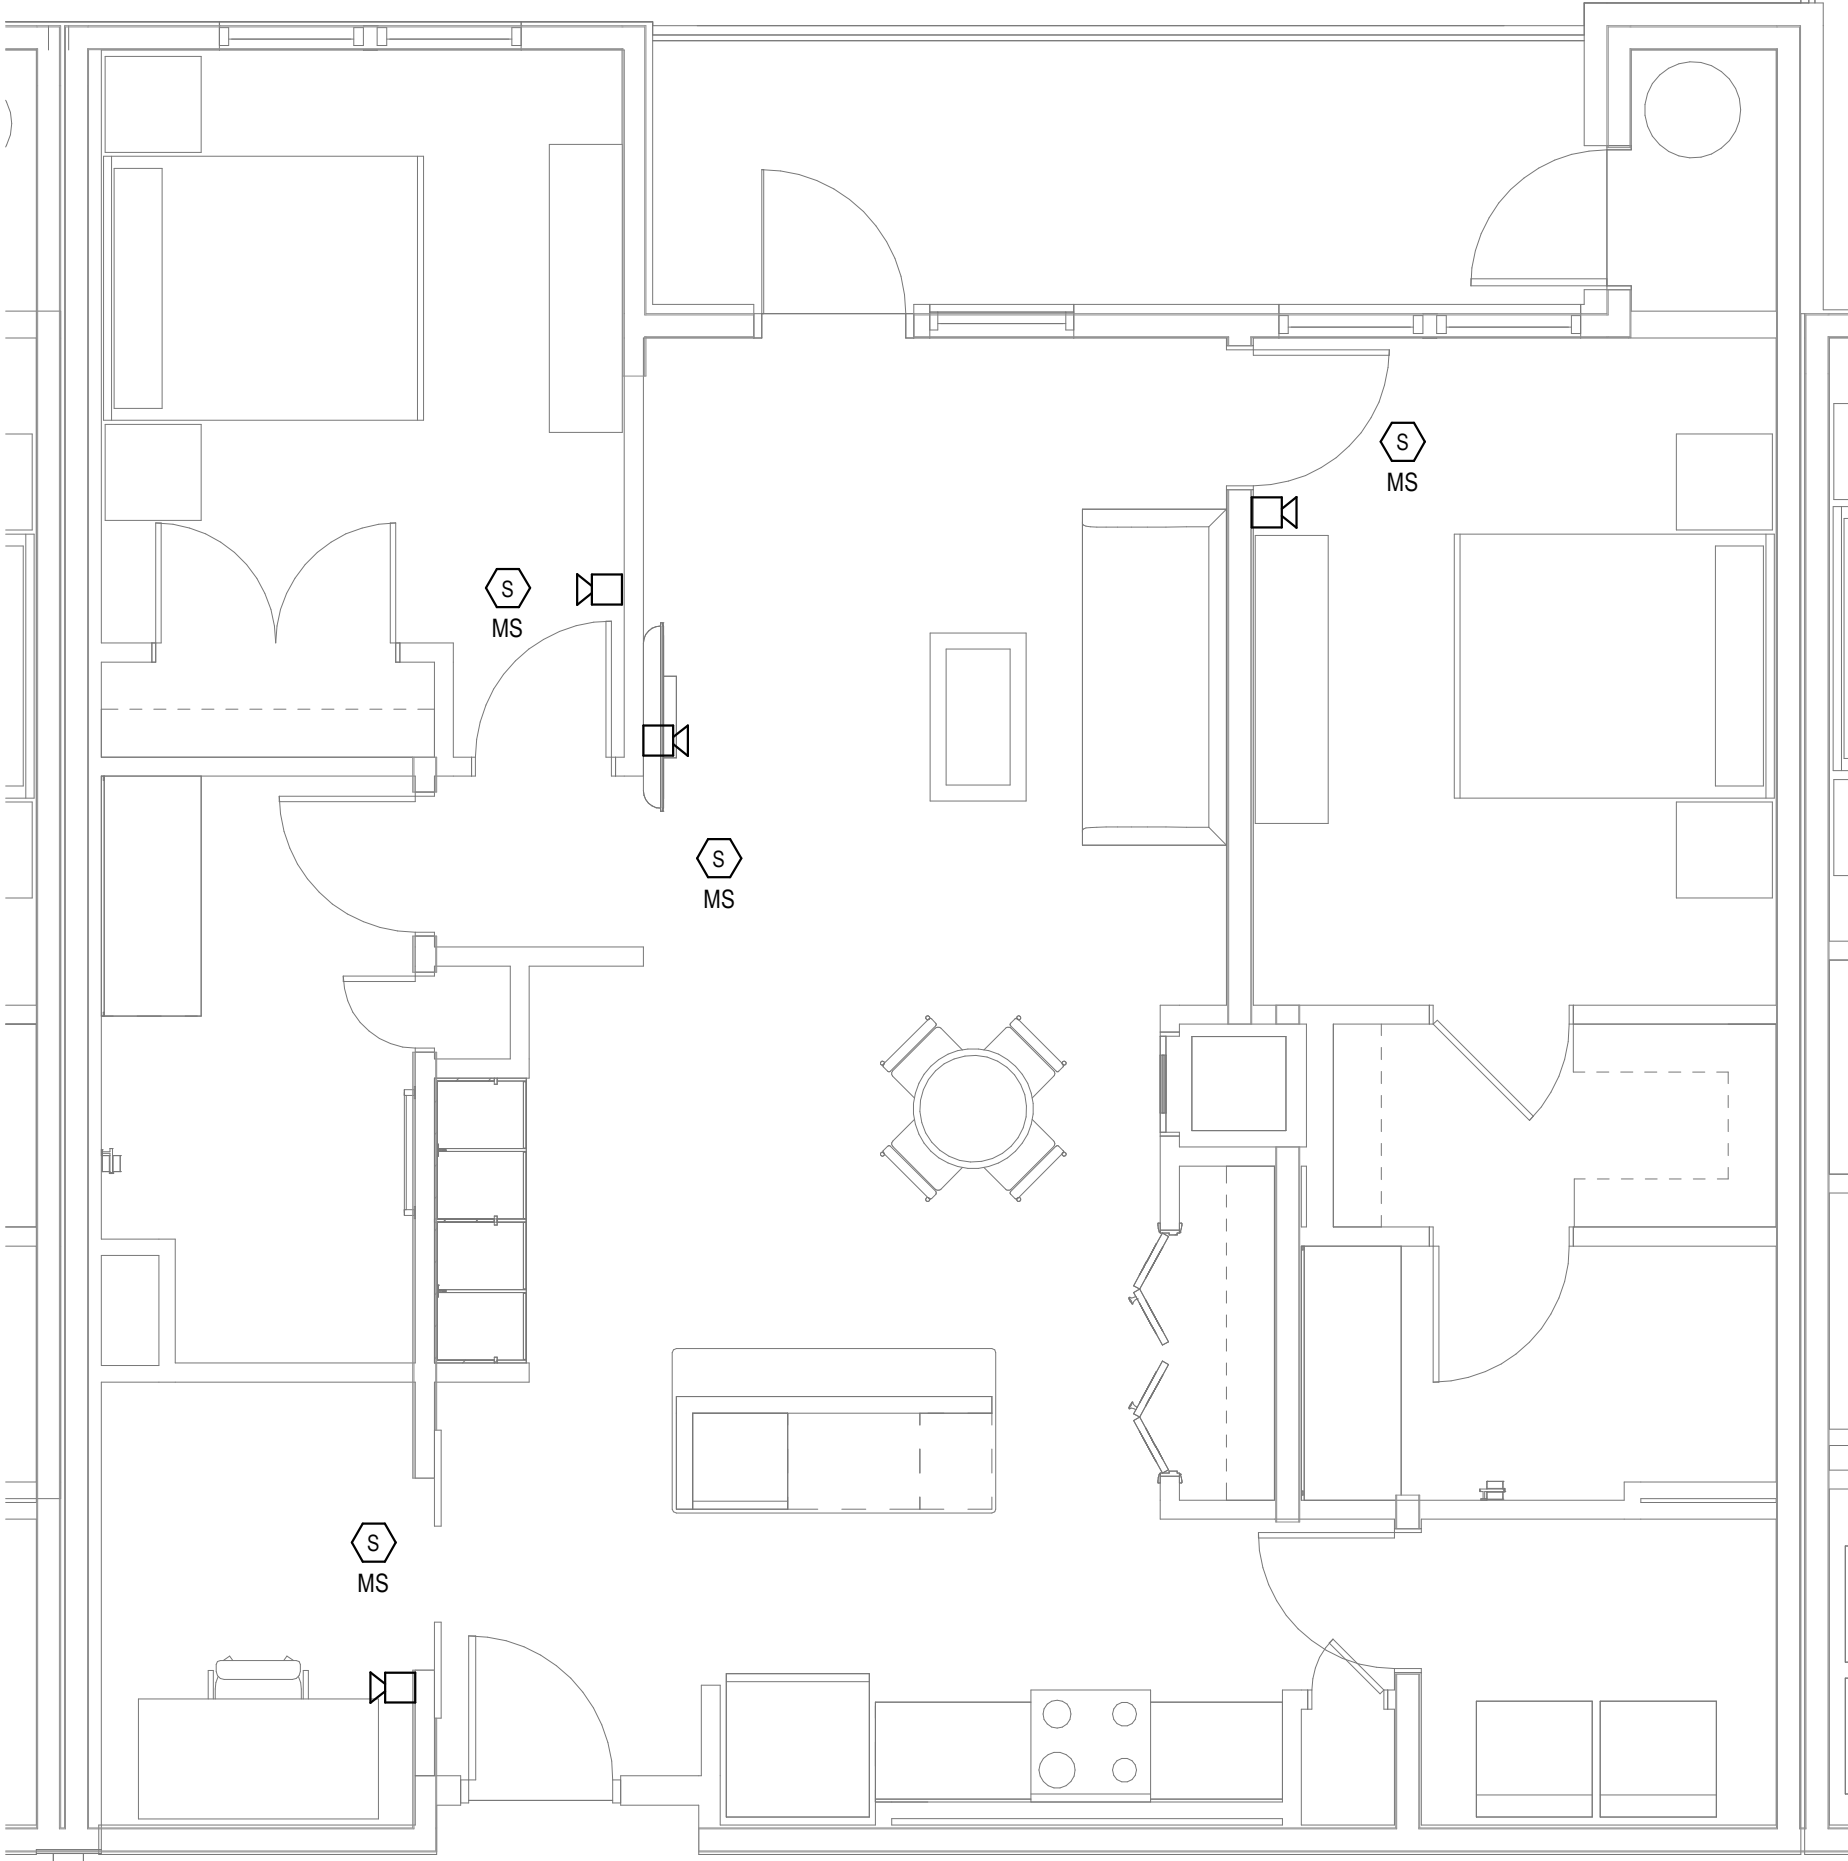

2
FA6.03
FIRE ALARM - UNIT - C (FW-1) PLAN
1/4" = 1'-0"

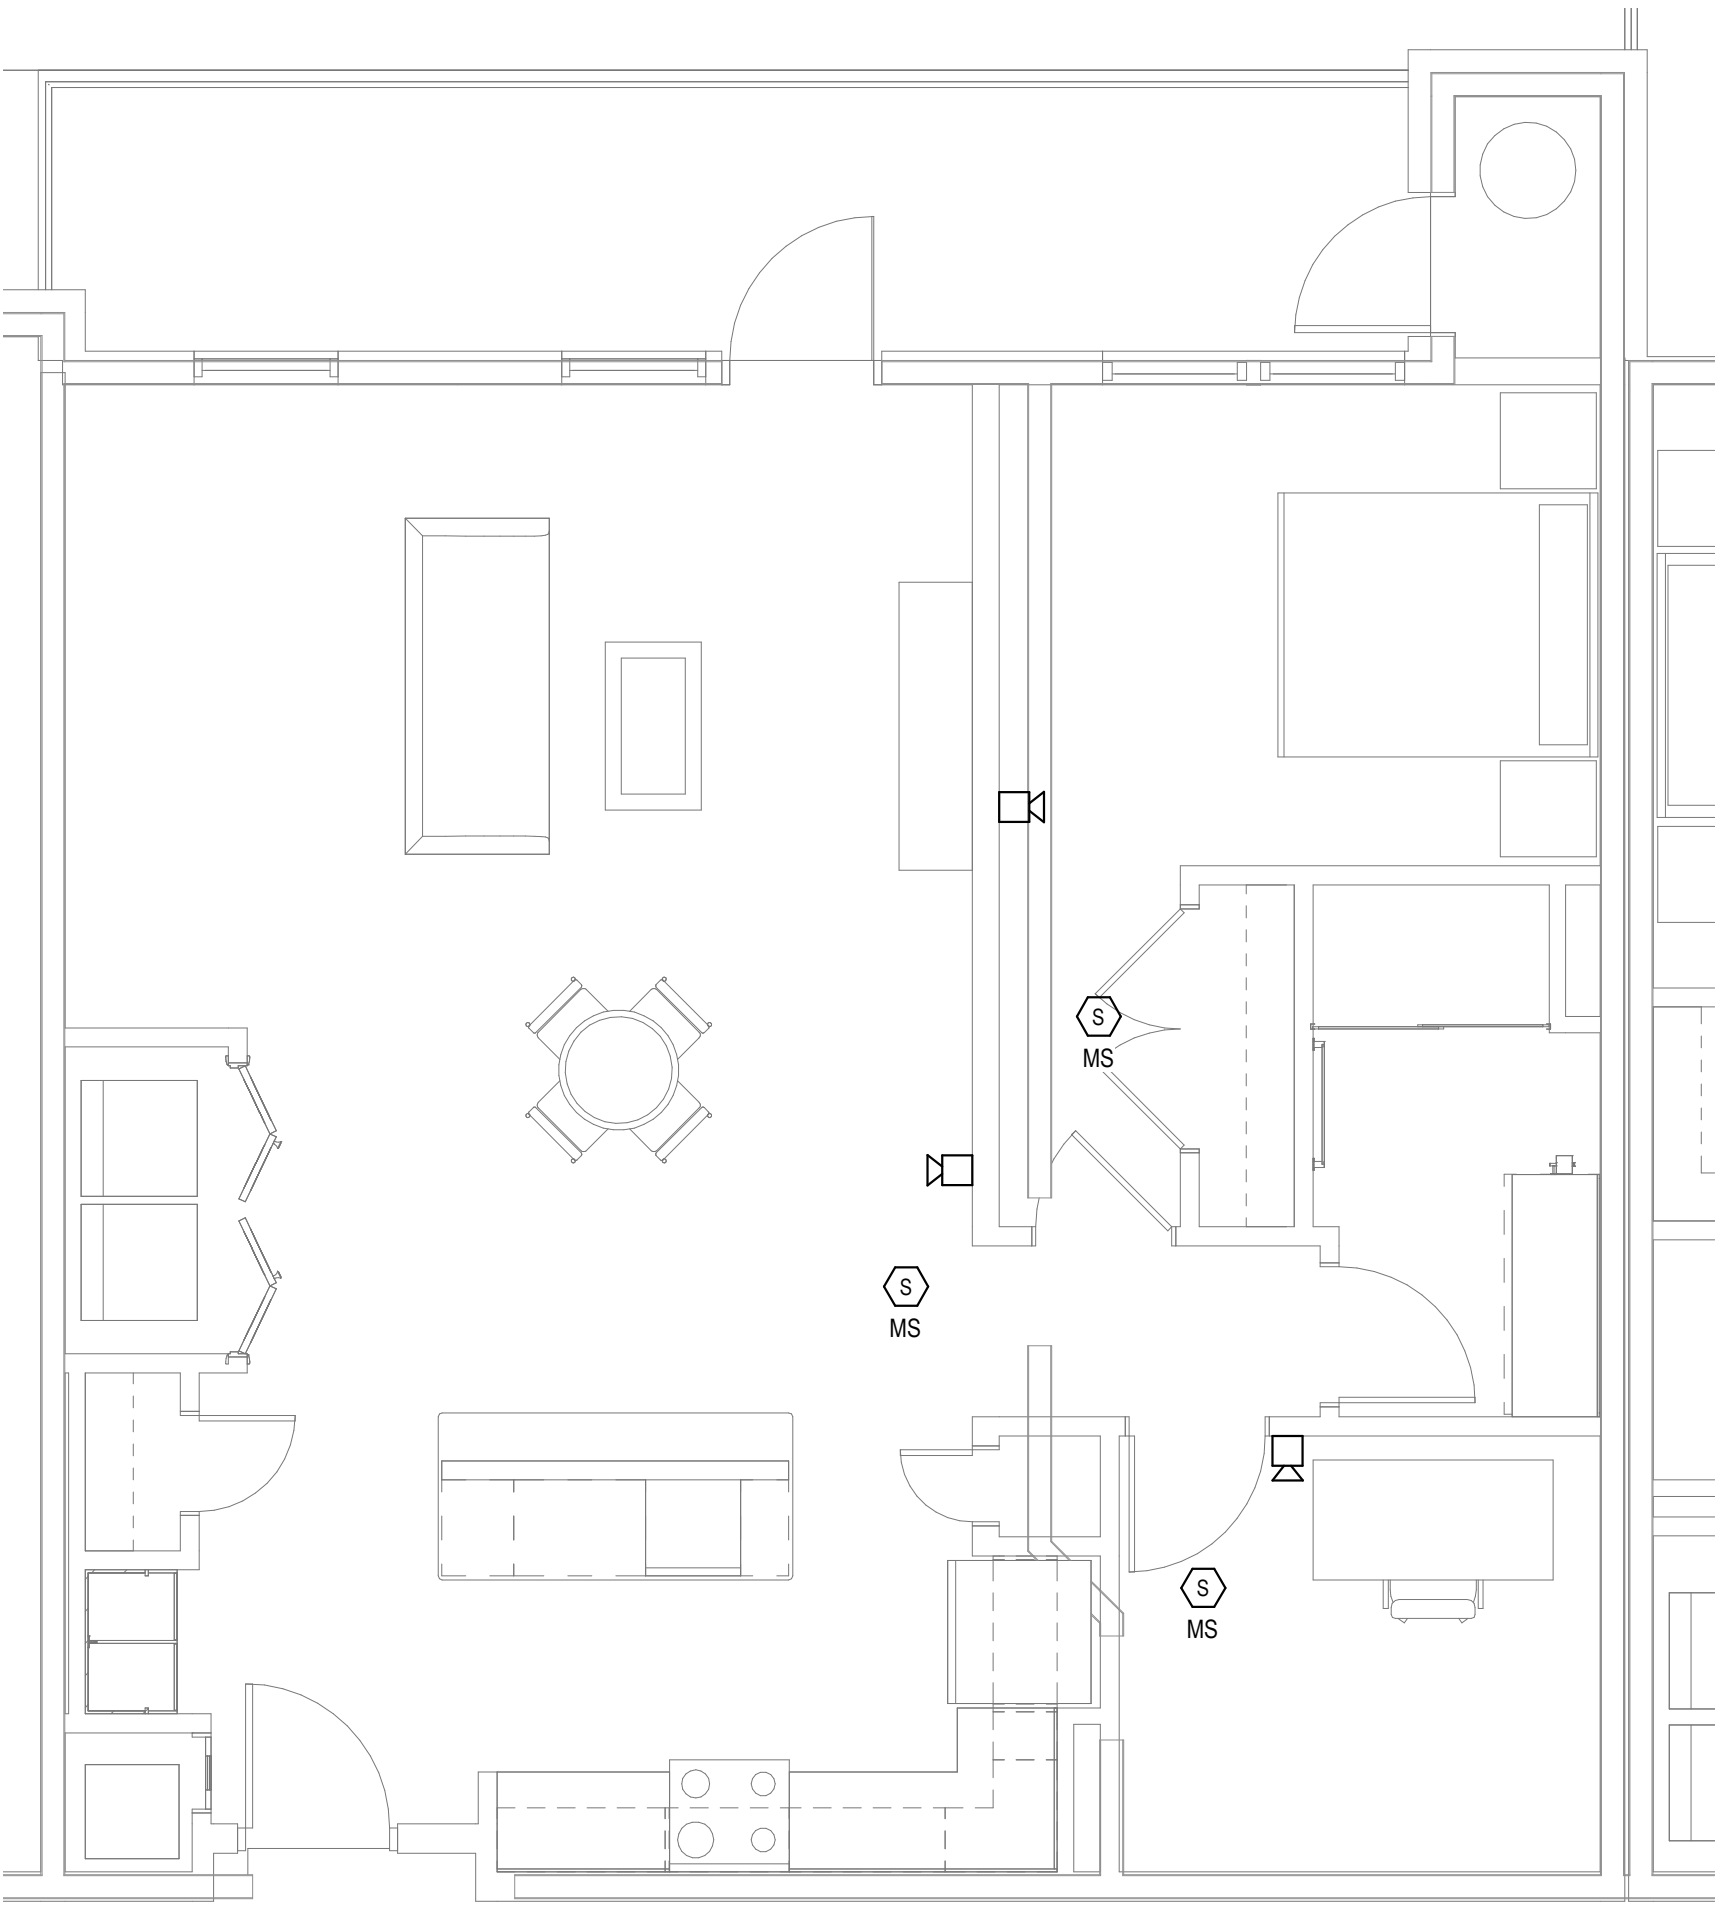


3
FA6.03
FIRE ALARM - UNIT - C2 PLAN
1/4" = 1'-0"

FIRE ALARM GENERAL NOTES

1. REFER TO SHEETS FA0.01 FOR NOTES, SYMBOLS AND ABBREVIATIONS.
2. EC SHALL REFER TO TELECOM, SECURITY & AV DRAWINGS, DETAILS FOR FINAL DEVICE LOCATIONS & RACEWAY REQUIREMENTS.
3. REFER TO MECHANICAL PLANS FOR DUCT SMOKE DETECTOR AND FIRE SMOKE DAMPER LOCATIONS. PROVIDE FA CONNECTION AND WIRE AS REQUIRED.
4. REFER TO FIRE PROTECTION PLANS FOR TAMPER AND FLOW SWITCH LOCATIONS. PROVIDE FA CONNECTION AND WIRE AS REQUIRED.
5. PROVIDE AREA SMOKE DETECTORS IN ELEVATORS LOBBIES AND ELEVATOR MACHINE ROOM(S). SMOKE DETECTORS SHALL BE LOCATED ON THE CEILING WITHIN 21 FEET OF THE CENTERLINE OF EACH ELEVATOR DOOR WITHIN THE ELEVATOR BANK UNDER CONTROL OF THE DETECTOR FOR ELEVATOR LOBBIES UP TO 15 FEET IN HEIGHT WITH FLAT AND SMOOTH CEILINGS. FOR HIGHER AND UNEVEN CEILINGS, ADDITIONAL SMOKE DETECTORS MAY BE REQUIRED.
6. MANUAL FIRE ALARM BOXES SHALL BE LOCATED WITHIN 5 FEET OF EACH EXIT DOORWAY ON EACH FLOOR.
7. DUCT SMOKE DETECTORS AND DUCT SMOKE DETECTORS TEST STATIONS LOCATIONS TO BE COORDINATED WITH THE MECHANICAL DRAWINGS.
8. PROVIDE AND INSTALL SYSTEM FIRE ALARM ADDRESSABLE DUCT SMOKE DETECTORS AS INDICATED ON THE MECHANICAL FLOOR PLANS AND RISERS FOR FIRE SMOKE DAMPERS AND SMOKE DAMPERS. PROVIDE ADDRESSABLE CONTROL RELAY AT EACH DAMPER.
9. PROVIDE 120V EMERGENCY POWER TO ALL FIRE SMOKE AND SMOKE DAMPERS INDICATED ON THE MECHANICAL DRAWINGS.
10. THESE FIRE ALARM DRAWINGS ARE PERFORMANCE SPECIFICATION ONLY. CONTRACTOR SHALL PROVIDE A COMPLETE SYSTEM DESIGN IN COMPLIANCE WITH NFPA 72, THE IBC, NFPA 96, AND ANY OTHER ENFORCED CODES AND AMENDMENTS, INCLUDING ENGINEERED SIGNED AND SEALED DRAWINGS, POINT TO POINT WIRING WITH PROPOSED CIRCUITING OR CONDUIT ROUTING, ALL APPLICABLE CALCULATIONS, DEVICE MANUFACTURERS AND QUANTITIES, WIRING DIAGRAMS, AND SHOP SUBMITTALS. CONTRACTOR SHALL BE RESPONSIBLE FOR ALL ASSOCIATED PERMITS, INSPECTIONS, AND TESTING. CONSULT LOCAL BUILDING AUTHORITY AND FIRE MARSHAL REGARDING LOCAL AREA'S REQUIREMENTS.

ALL REPORTS, PLANS, SPECIFICATIONS AND COMPUTER FILES RELATING TO THIS PROJECT ARE THE PROPERTY OF THE MARTIN ARCHITECTURAL GROUP. THE MARTIN ARCHITECTURAL GROUP RETAINS ALL COMMON LAW, STATUTE AND OTHER RESERVED RIGHTS INCLUDING THE COPY RIGHT THEREIN. REPRODUCTION OF THE MATERIAL HEREIN OR SUBSTANTIAL USE WITHOUT WRITTEN PERMISSION OF THE MARTIN ARCHITECTURAL GROUP VIOLATES THE COPYRIGHT LAWS OF THE UNITED STATES AND WILL BE SUBJECT TO LEGAL PROSECUTION.

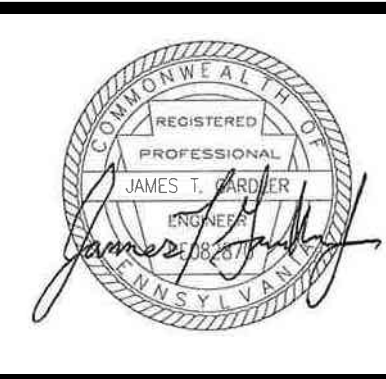

THE MARTIN ARCHITECTURAL GROUP, P.C.
ARCHITECTS AND LAND PLANNERS
A PROFESSIONAL CORPORATION
240 NORTH 22ND STREET, PHILADELPHIA, PA, 19103
P (215) 665-1086 F (215) 561-5064

P.A.: JTG
P.M.: TRT
DRAWN BY: Author
PROJECT NO: 1022747

NO.	REVISION	DATE
1	SCHEMATIC BUDGET PRICING SET	11/01/2022
1	PERMIT SET	12/20/2022

Project Status


FIRE ALARM - UNIT PLANS
Granite Run Apartments

MIDDLETOWN TOWNSHIP, PA


SCALE: AS INDICATED
DATE: 11/01/22

FA6.03


© The Martin Architectural Group, P.C.

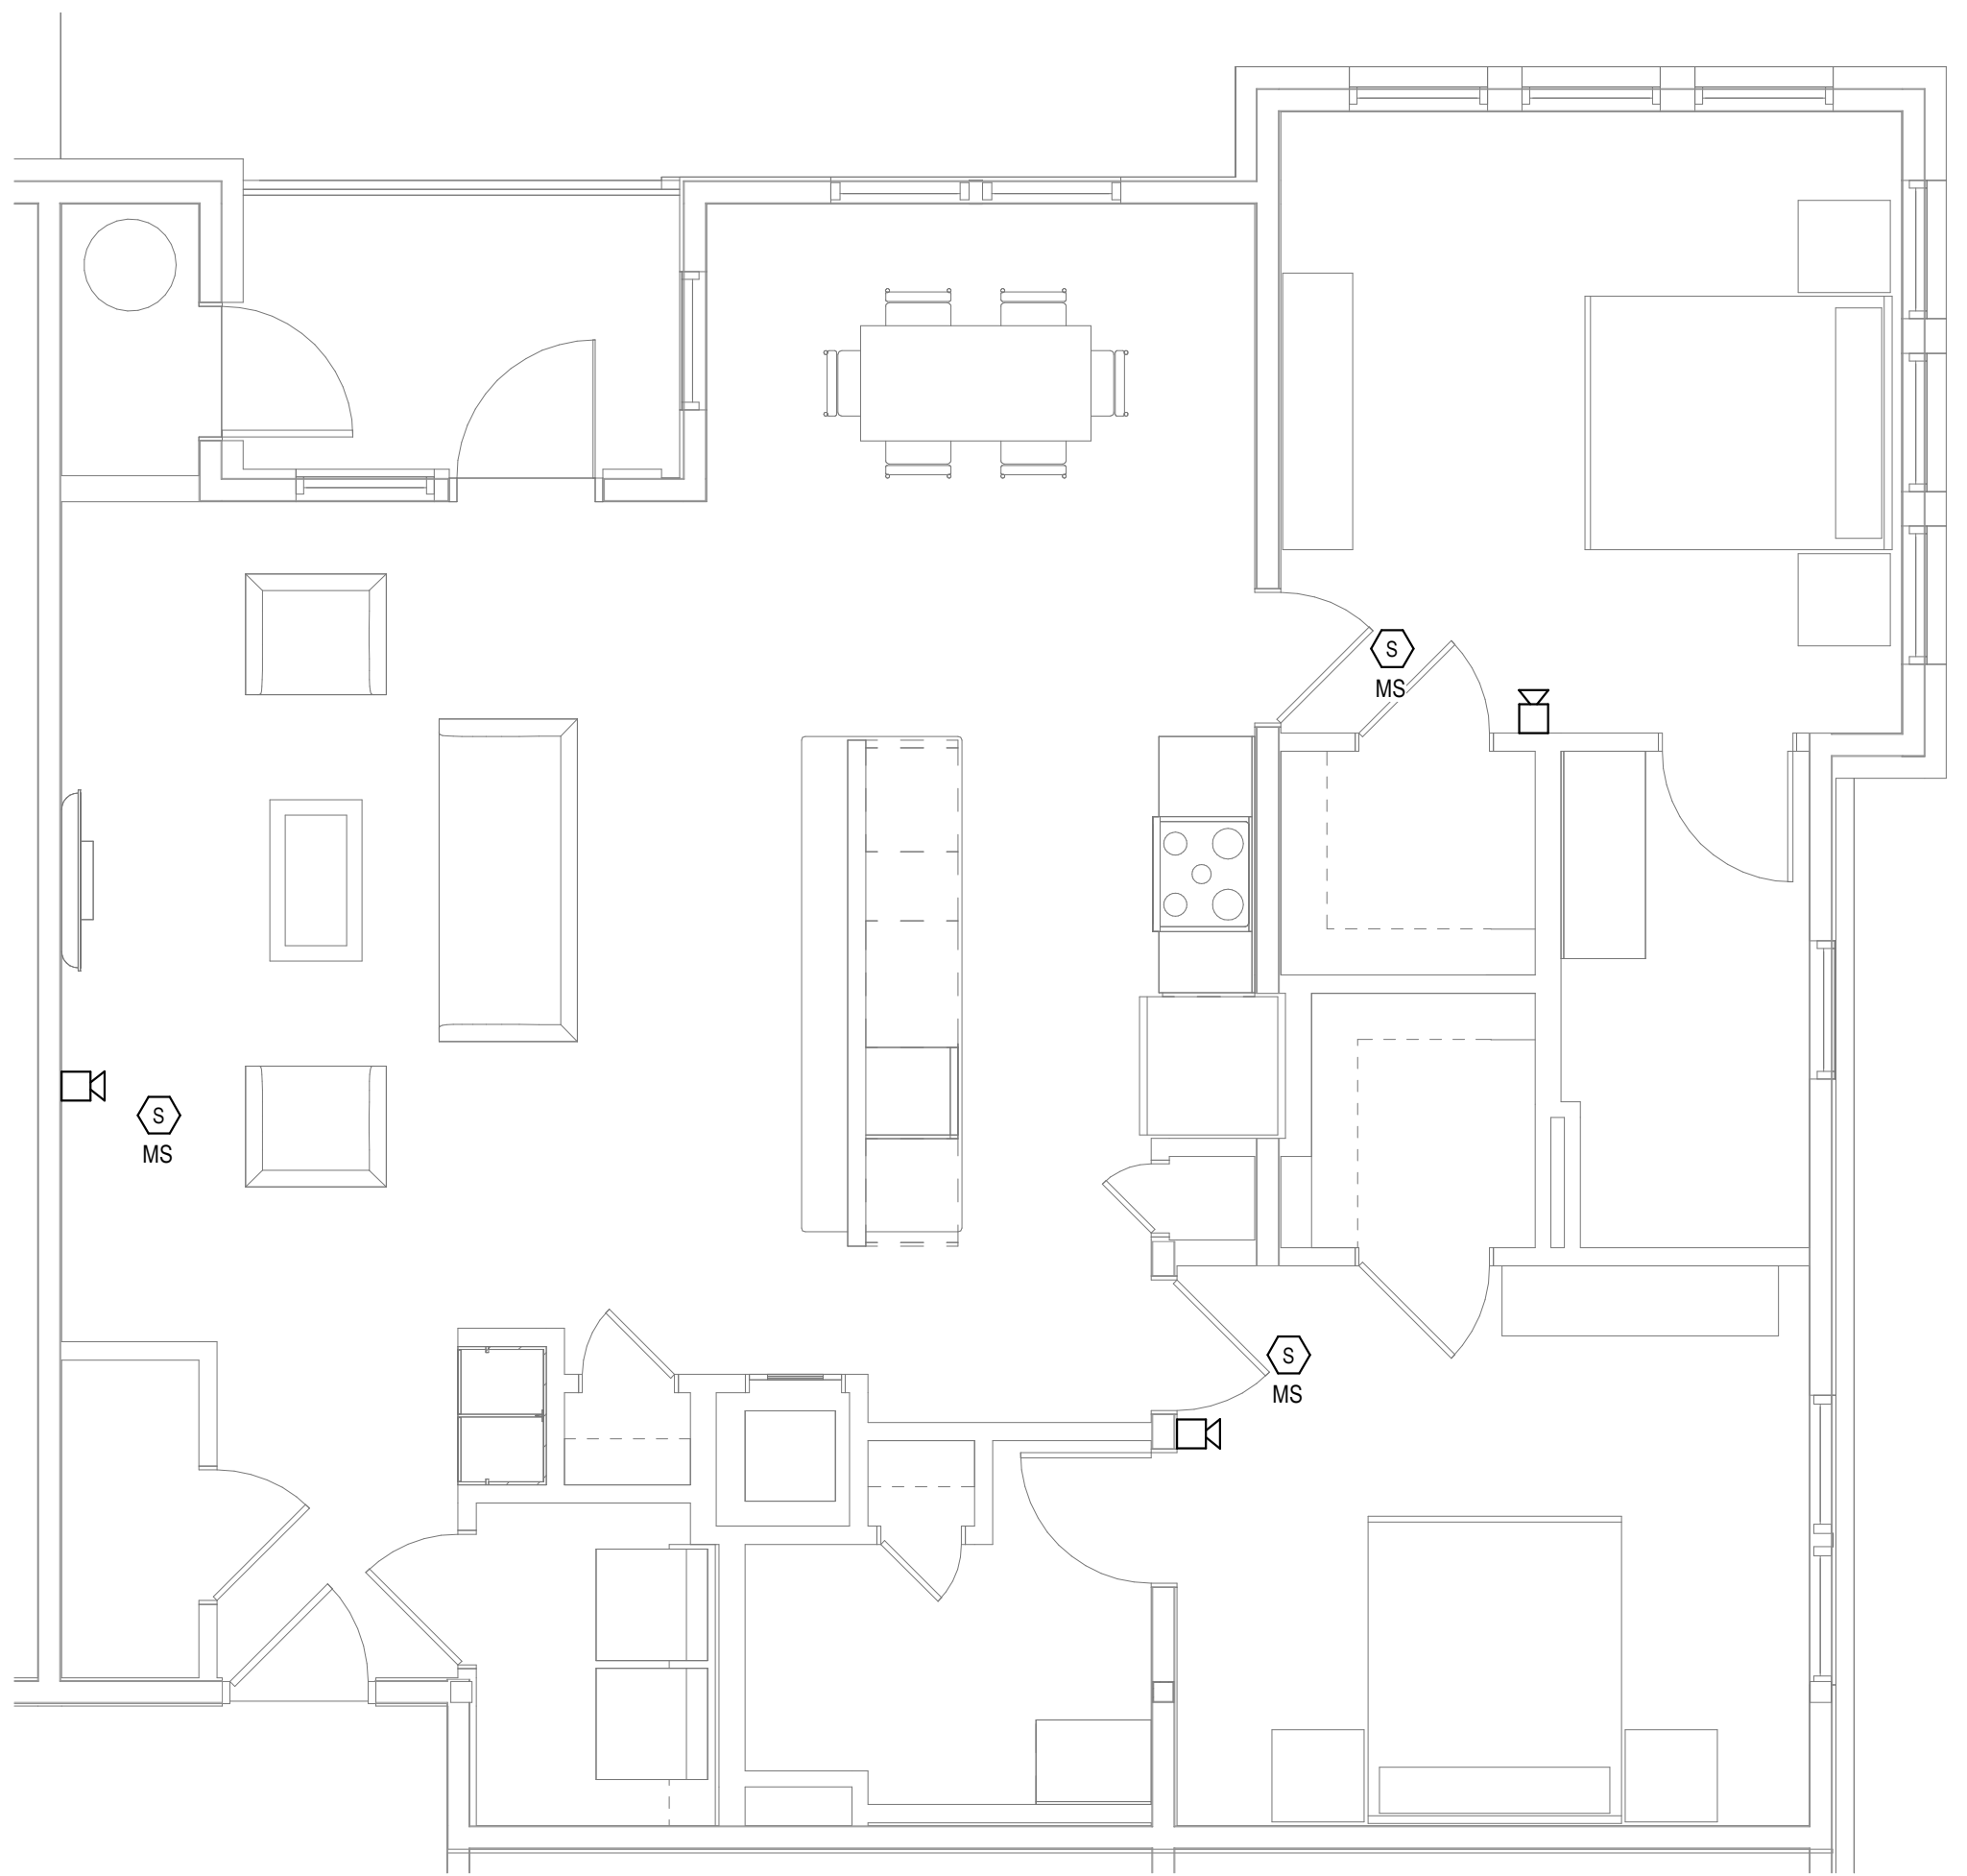


1
FA6.04
FIRE ALARM - UNIT - D PLAN
1/4" = 1'-0"

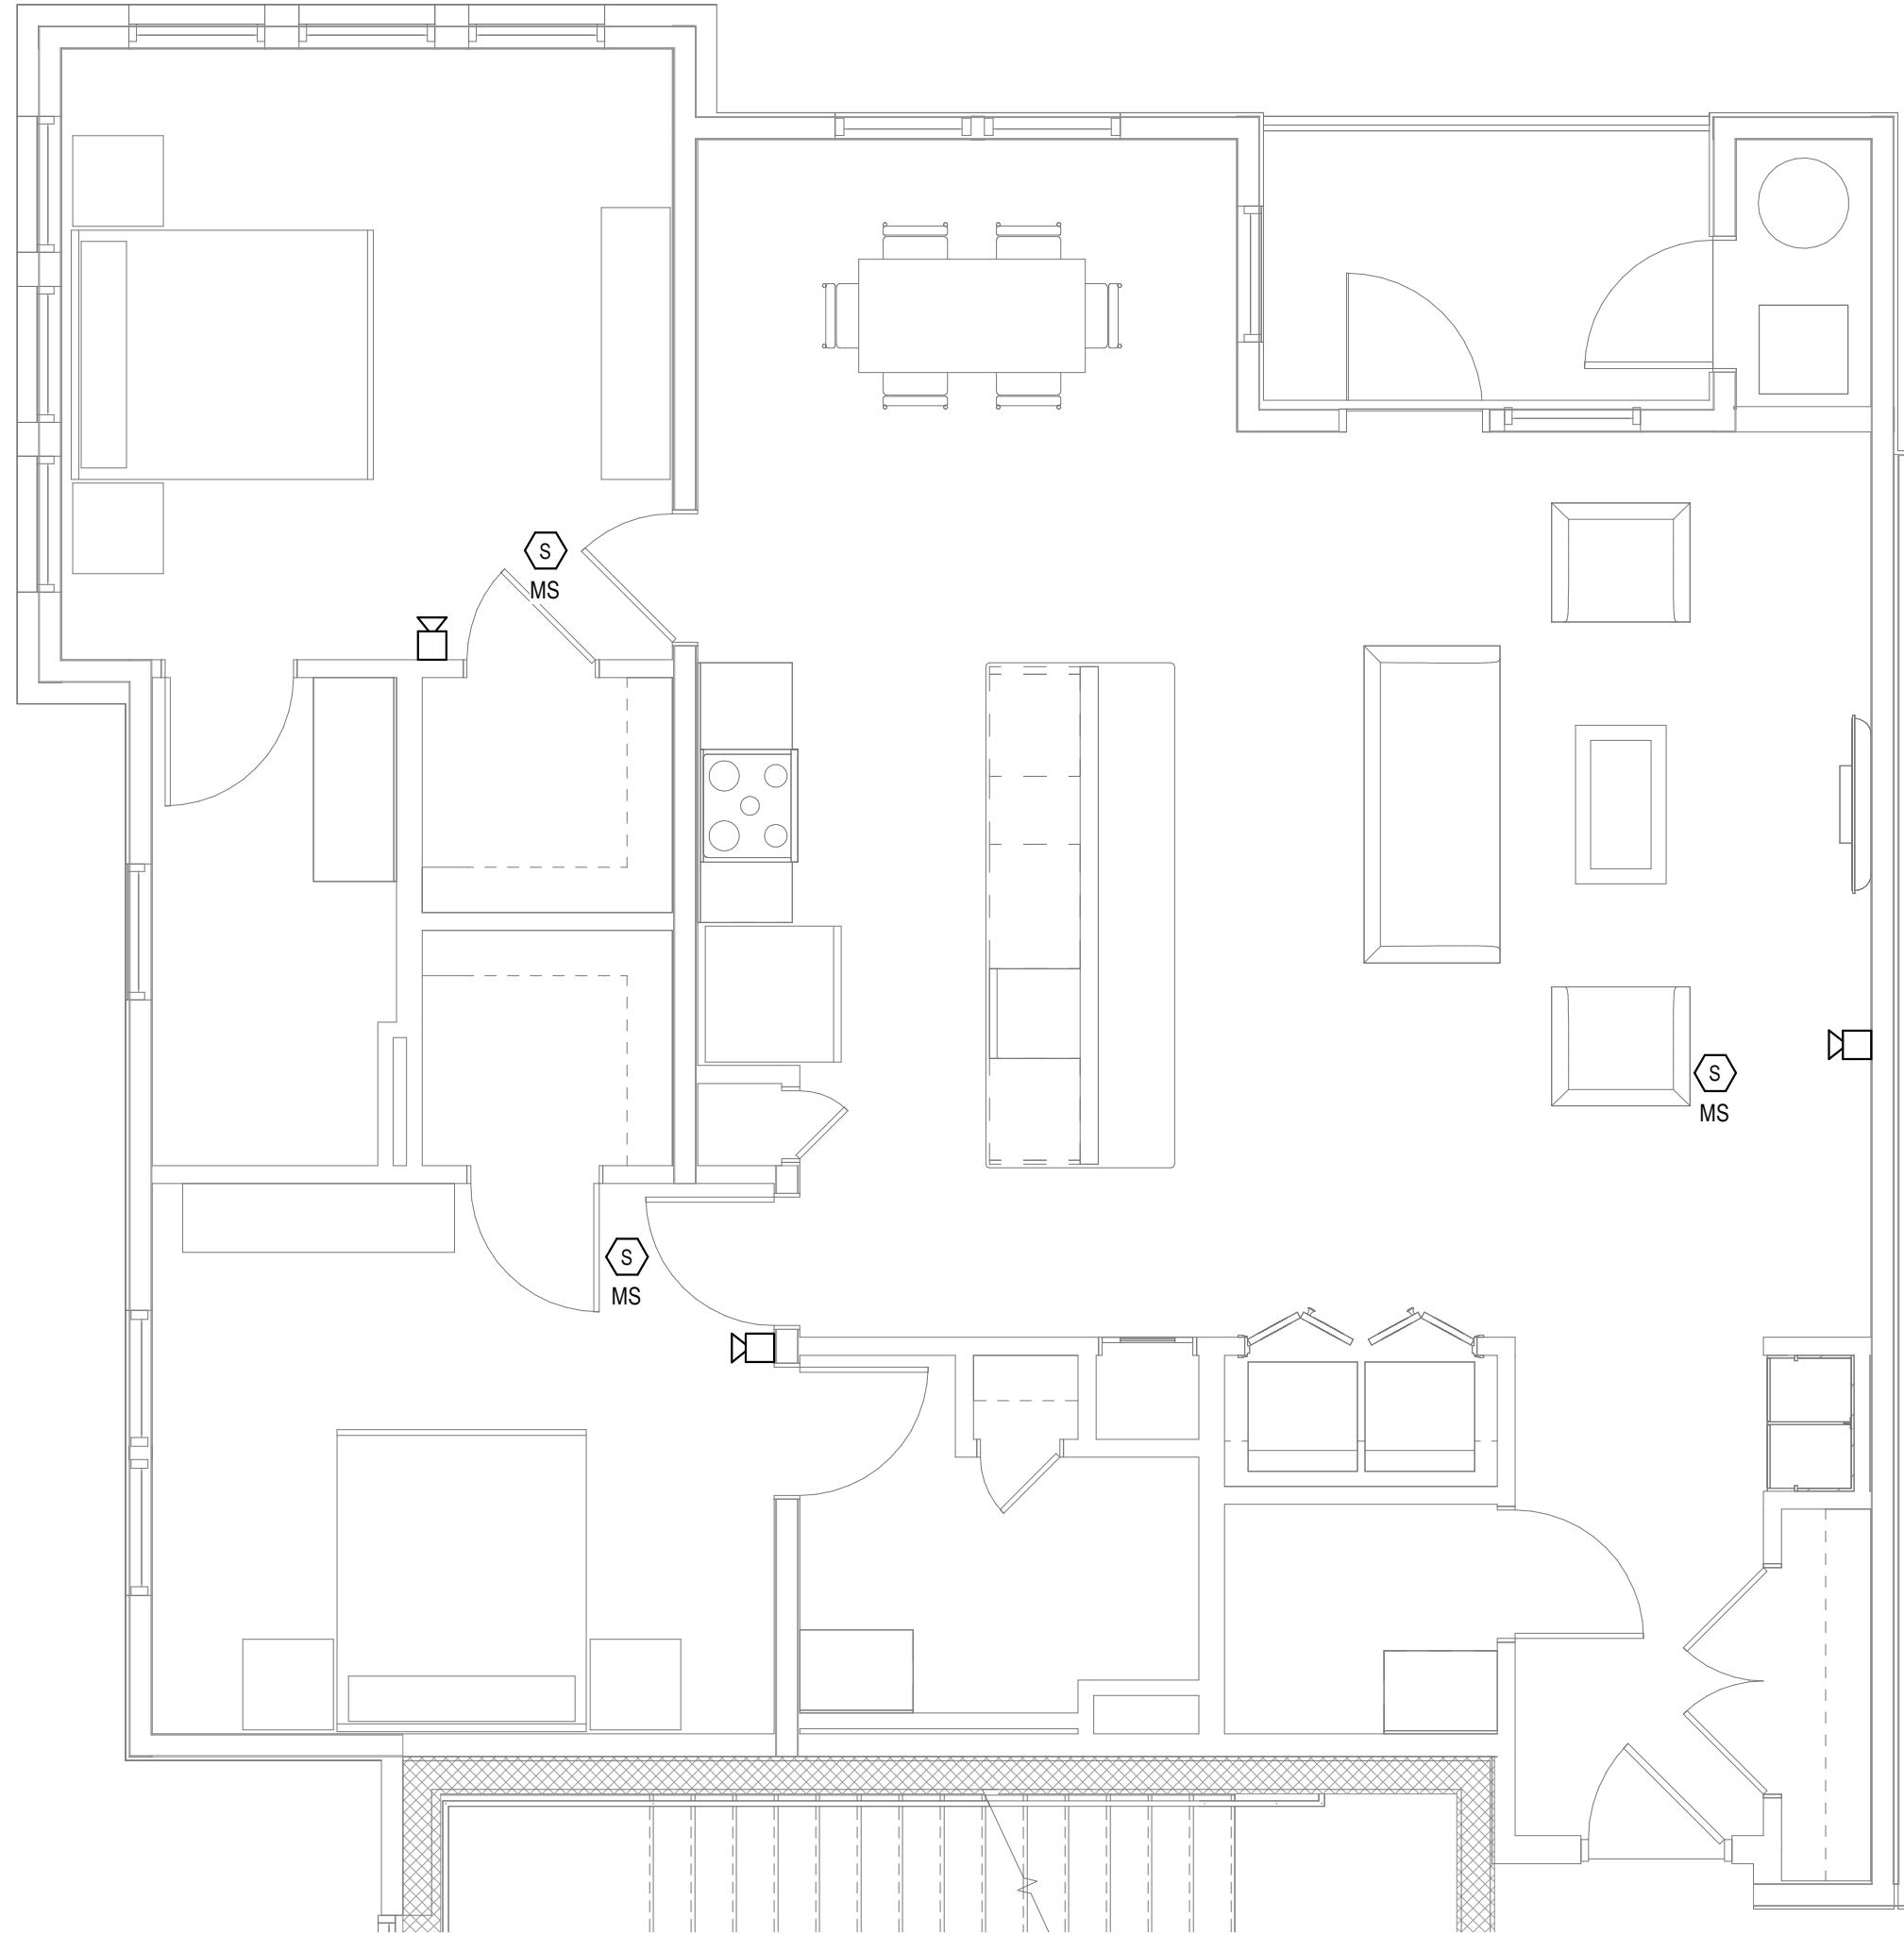

2
FA6.04
FIRE ALARM - UNIT - D - F1 (ALT. FOYER) PLAN
1/4" = 1'-0"

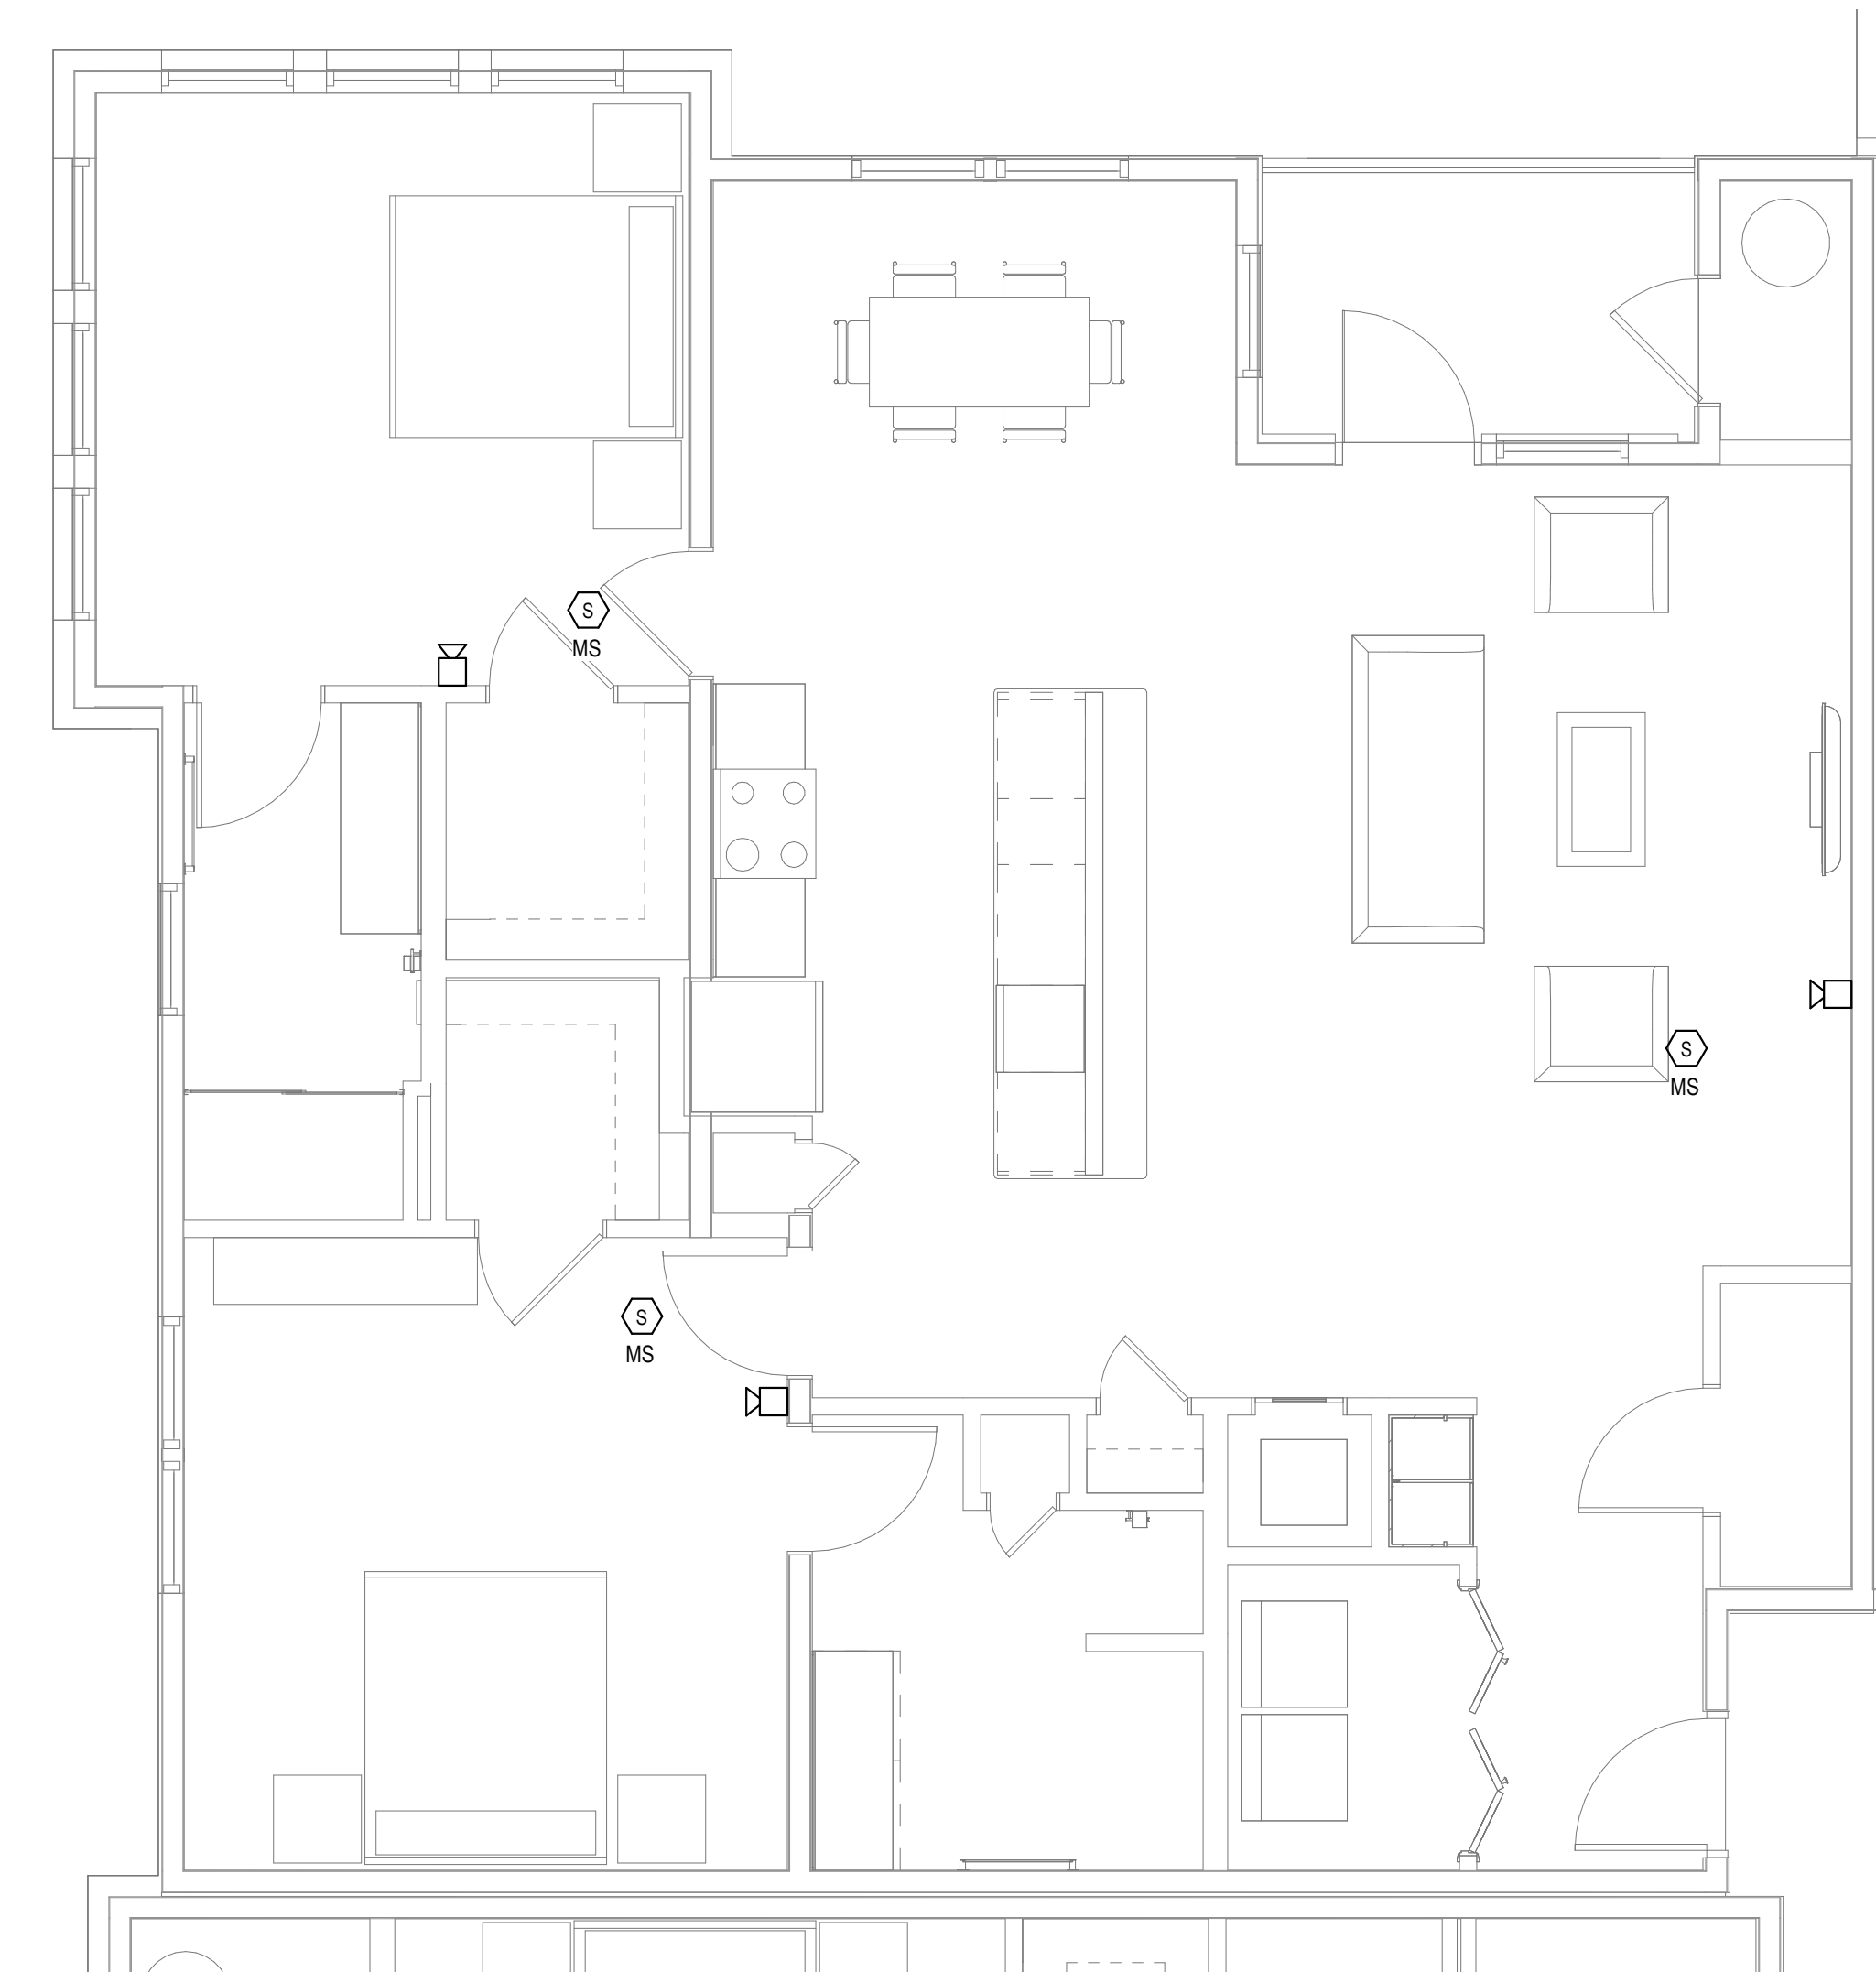

3
FA6.04
FIRE ALARM - UNIT - D2 - F1 PLAN
1/4" = 1'-0"

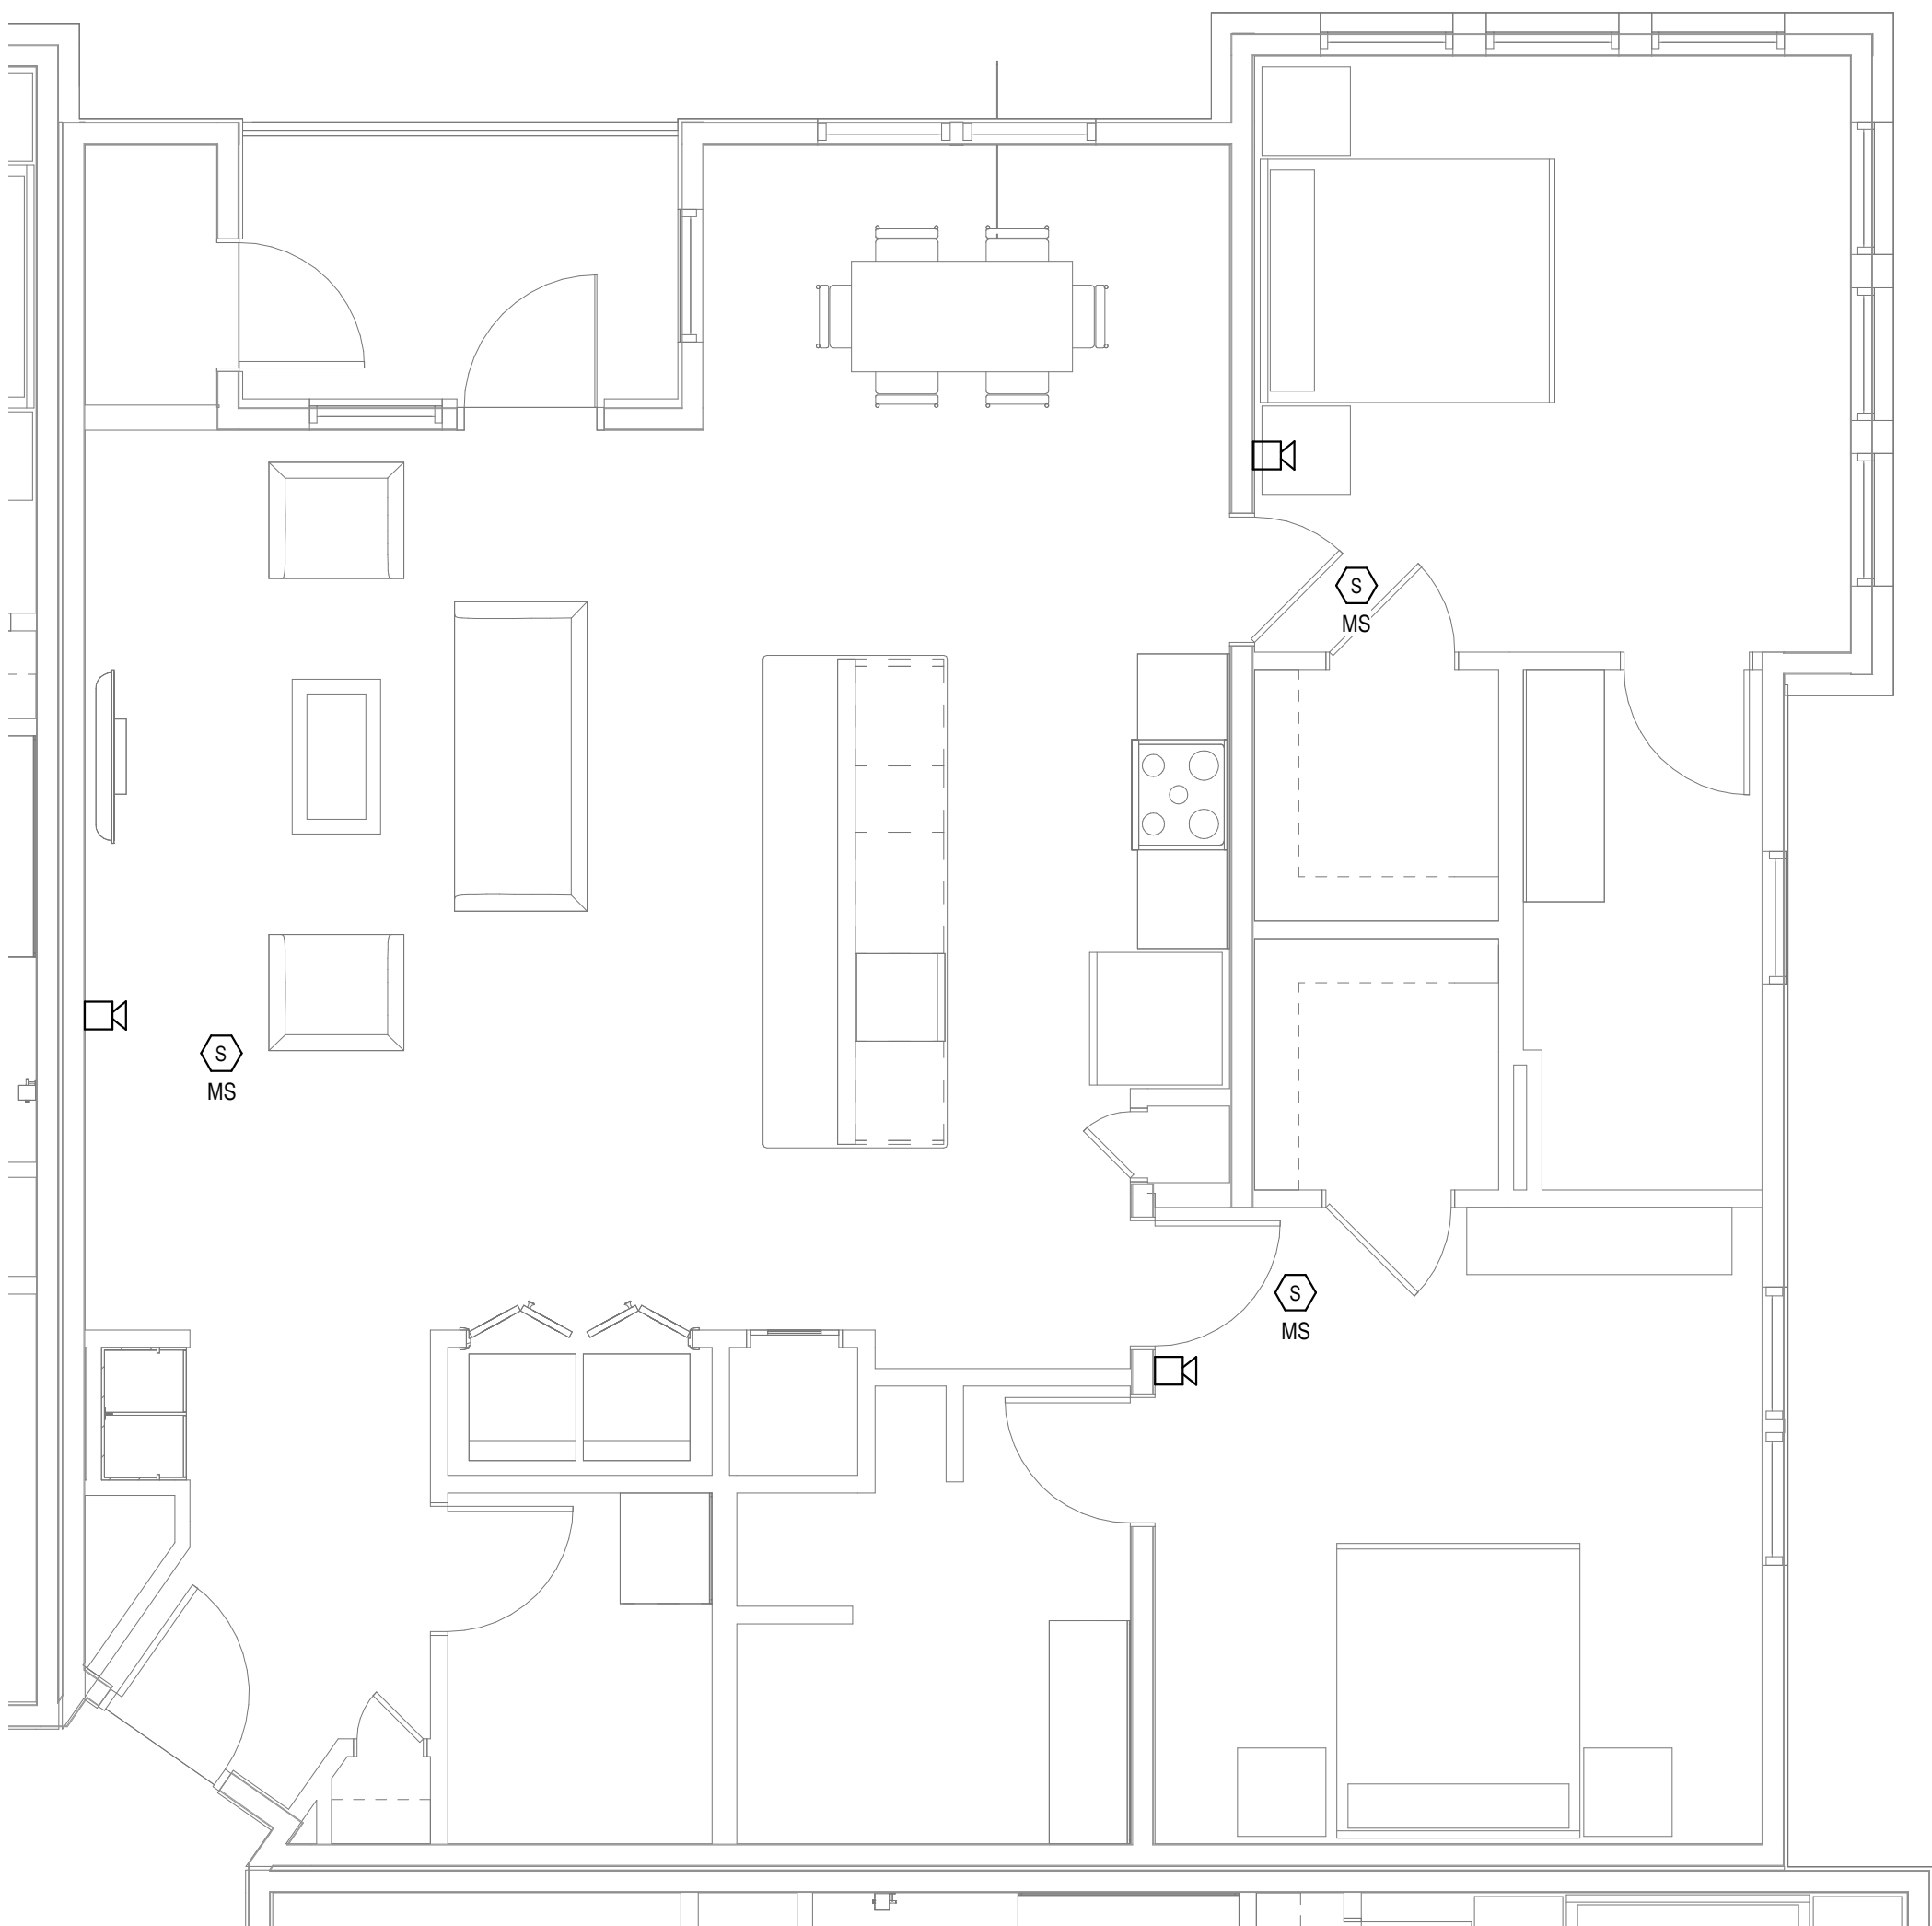

4
FA6.04
FIRE ALARM - UNIT - D2 - F2 (ALT. FOYER) PLAN
1/4" = 1'-0"

FIRE ALARM GENERAL NOTES

1. REFER TO SHEETS FA0.01 FOR NOTES, SYMBOLS AND ABBREVIATIONS.
2. EC SHALL REFER TO TELECOM, SECURITY & AV DRAWINGS, DETAILS FOR FINAL DEVICE LOCATIONS & RACEWAY REQUIREMENTS.
3. REFER TO MECHANICAL PLANS FOR DUCT SMOKE DETECTOR AND FIRE SMOKE DAMPER LOCATIONS. PROVIDE FA CONNECTION AND WIRE AS REQUIRED.
4. REFER TO FIRE PROTECTION PLANS FOR TAMPER AND FLOW SWITCH LOCATIONS. PROVIDE FA CONNECTION AND WIRE AS REQUIRED.
5. PROVIDE AREA SMOKE DETECTORS IN ELEVATORS LOBBIES AND ELEVATOR MACHINE ROOM(S). SMOKE DETECTORS SHALL BE LOCATED ON THE CEILING WITHIN 21 FEET OF THE CENTERLINE OF EACH ELEVATOR DOOR WITHIN THE ELEVATOR BANK UNDER CONTROL OF THE DETECTOR FOR ELEVATOR LOBBIES UP TO 15 FEET IN HEIGHT WITH FLAT AND SMOOTH CEILINGS. FOR HIGHER AND UNEVEN CEILINGS, ADDITIONAL SMOKE DETECTORS MAY BE REQUIRED.
6. MANUAL FIRE ALARM BOXES SHALL BE LOCATED WITHIN 5 FEET OF EACH EXIT DOORWAY ON EACH FLOOR.
7. DUCT SMOKE DETECTORS AND DUCT SMOKE DETECTORS TEST STATIONS LOCATIONS TO BE COORDINATED WITH THE MECHANICAL DRAWINGS.
8. PROVIDE AND INSTALL SYSTEM FIRE ALARM ADDRESSABLE DUCT SMOKE DETECTORS AS INDICATED ON THE MECHANICAL FLOOR PLANS AND RISERS FOR FIRE SMOKE DAMPERS AND SMOKE DAMPERS. PROVIDE ADDRESSABLE CONTROL RELAY AT EACH DAMPER.
9. PROVIDE 120V EMERGENCY POWER TO ALL FIRE/SMOKE AND SMOKE DAMPERS INDICATED ON THE MECHANICAL DRAWINGS.
10. THESE FIRE ALARM DRAWINGS ARE PERFORMANCE SPECIFICATION ONLY. CONTRACTOR SHALL PROVIDE A COMPLETE SYSTEM DESIGN IN COMPLIANCE WITH NFPA 72, THE IBC, NFPA 96, AND ANY OTHER ENFORCED CODES AND AMENDMENTS, INCLUDING ENGINEERED SIGNED AND SEALED DRAWINGS, POINT TO POINT WIRING WITH PROPOSED CIRCUITING OR CONDUIT ROUTING, ALL APPLICABLE CALCULATIONS, DEVICE MANUFACTURERS AND QUANTITIES, WIRING DIAGRAMS, AND SHOP SUBMITTALS. CONTRACTOR SHALL BE RESPONSIBLE FOR ALL ASSOCIATED PERMITS, INSPECTIONS, AND TESTING. CONSULT LOCAL BUILDING AUTHORITY AND FIRE MARSHAL REGARDING LOCAL AREA'S REQUIREMENTS.

ALL REPORTS, PLANS, SPECIFICATIONS AND COMPUTER FILES RELATING TO THIS PROJECT ARE THE PROPERTY OF THE MARTIN ARCHITECTURAL GROUP. THE MARTIN ARCHITECTURAL GROUP RETAINS ALL COMMON LAW, STATUTE AND OTHER RESERVED RIGHTS INCLUDING THE COPY RIGHT THEREIN. REPRODUCTION OF THE MATERIAL HEREIN OR SUBSTANTIAL USE WITHOUT WRITTEN PERMISSION OF THE MARTIN ARCHITECTURAL GROUP VIOLATES THE COPYRIGHT LAWS OF THE UNITED STATES AND WILL BE SUBJECT TO LEGAL PROSECUTION.

© The Martin Architectural Group, P.C.



THE MARTIN ARCHITECTURAL GROUP, P.C.
ARCHITECTS AND LAND PLANNERS
A PROFESSIONAL CORPORATION
240 NORTH 22ND STREET, PHILADELPHIA, PA, 19103
P (215) 665-1080 F (215) 561-5064

P.A.: JTG
P.M.: TRT
DRAWN BY: Author
PROJECT NO: 1022747

NO.	REVISION	DATE
1	SCHEMATIC BUDGET PRICING SET	11/01/2022
1	PERMIT SET	12/20/2022

Project Status

FIRE ALARM - UNIT PLANS
Granite Run Apartments

MIDDLETOWN TOWNSHIP, PA

SCALE: AS INDICATED
DATE: 11/01/22

FA6.04

© The Martin Architectural Group, P.C.



P.A.: JTG
P.M.: TRT
DRAWN BY: Author
PROJECT NO: 1022747

NO.	REVISION	DATE
1	SCHEMATIC BUDGET PRICING SET	11/01/2022
1	PERMIT SET	12/20/2022

Project Status


SCALE: AS INDICATED
DATE: 11/01/22

FIRE ALARM GENERAL NOTES

- REFER TO SHEETS FA0.01 FOR NOTES, SYMBOLS AND ABBREVIATIONS.
- EC SHALL REFER TO TELECOM, SECURITY & AV DRAWINGS, DETAILS FOR FINAL DEVICE LOCATIONS & RACEWAY REQUIREMENTS.
- REFER TO MECHANICAL PLANS FOR DUCT SMOKE DETECTOR AND FIRE SMOKE DAMPER LOCATIONS. PROVIDE FA CONNECTION AND WIRE AS REQUIRED.
- REFER TO FIRE PROTECTION PLANS FOR TAMPER AND FLOW SWITCH LOCATIONS. PROVIDE FA CONNECTION AND WIRE AS REQUIRED.
- PROVIDE AREA SMOKE DETECTORS IN ELEVATORS LOBBIES AND ELEVATOR MACHINE ROOM(S). SMOKE DETECTORS SHALL BE LOCATED ON THE CEILING WITHIN 21 FEET OF THE CENTERLINE OF EACH ELEVATOR DOOR WITHIN THE ELEVATOR BANK UNDER CONTROL OF THE DETECTOR FOR ELEVATOR LOBBIES UP TO 15 FEET IN HEIGHT WITH FLAT AND SMOOTH CEILINGS. FOR HIGHER AND UNEVEN CEILINGS, ADDITIONAL SMOKE DETECTORS MAY BE REQUIRED.
- MANUAL FIRE ALARM BOXES SHALL BE LOCATED WITHIN 5 FEET OF EACH EXIT DOORWAY ON EACH FLOOR.
- DUCT SMOKE DETECTORS AND DUCT SMOKE DETECTORS TEST STATIONS LOCATIONS TO BE COORDINATED WITH THE MECHANICAL DRAWINGS.
- PROVIDE AND INSTALL SYSTEM FIRE ALARM ADDRESSABLE DUCT SMOKE DETECTORS AS INDICATED ON THE MECHANICAL FLOOR PLANS AND RISERS FOR FIRE SMOKE DAMPERS AND SMOKE DAMPERS. PROVIDE ADDRESSABLE CONTROL RELAY AT EACH DAMPER.
- PROVIDE 120V EMERGENCY POWER TO ALL FIRE/SMOKE AND SMOKE DAMPERS INDICATED ON THE MECHANICAL DRAWINGS.
- THESE FIRE ALARM DRAWINGS ARE PERFORMANCE SPECIFICATION ONLY. CONTRACTOR SHALL PROVIDE A COMPLETE SYSTEM DESIGN IN COMPLIANCE WITH NFPA 72, THE IBC, NFPA 101, AND ANY OTHER ENFORCED CODES AND AMENDMENTS, INCLUDING ENGINEERED SIGNED AND SEALED DRAWINGS, POINT TO POINT WIRING WITH PROPOSED CIRCUITING OR CONDUIT ROUTING, ALL APPLICABLE CALCULATIONS, DEVICE MANUFACTURERS AND QUANTITIES, WIRING DIAGRAMS, AND SHOP SUBMITTALS. CONTRACTOR SHALL BE RESPONSIBLE FOR ALL ASSOCIATED PERMITS, INSPECTIONS, AND TESTING. CONSULT LOCAL BUILDING AUTHORITY AND FIRE MARSHAL REGARDING LOCAL AREA'S REQUIREMENTS.



1
FA6.05
FIRE ALARM - UNIT - E PLAN
1/4" = 1'-0"

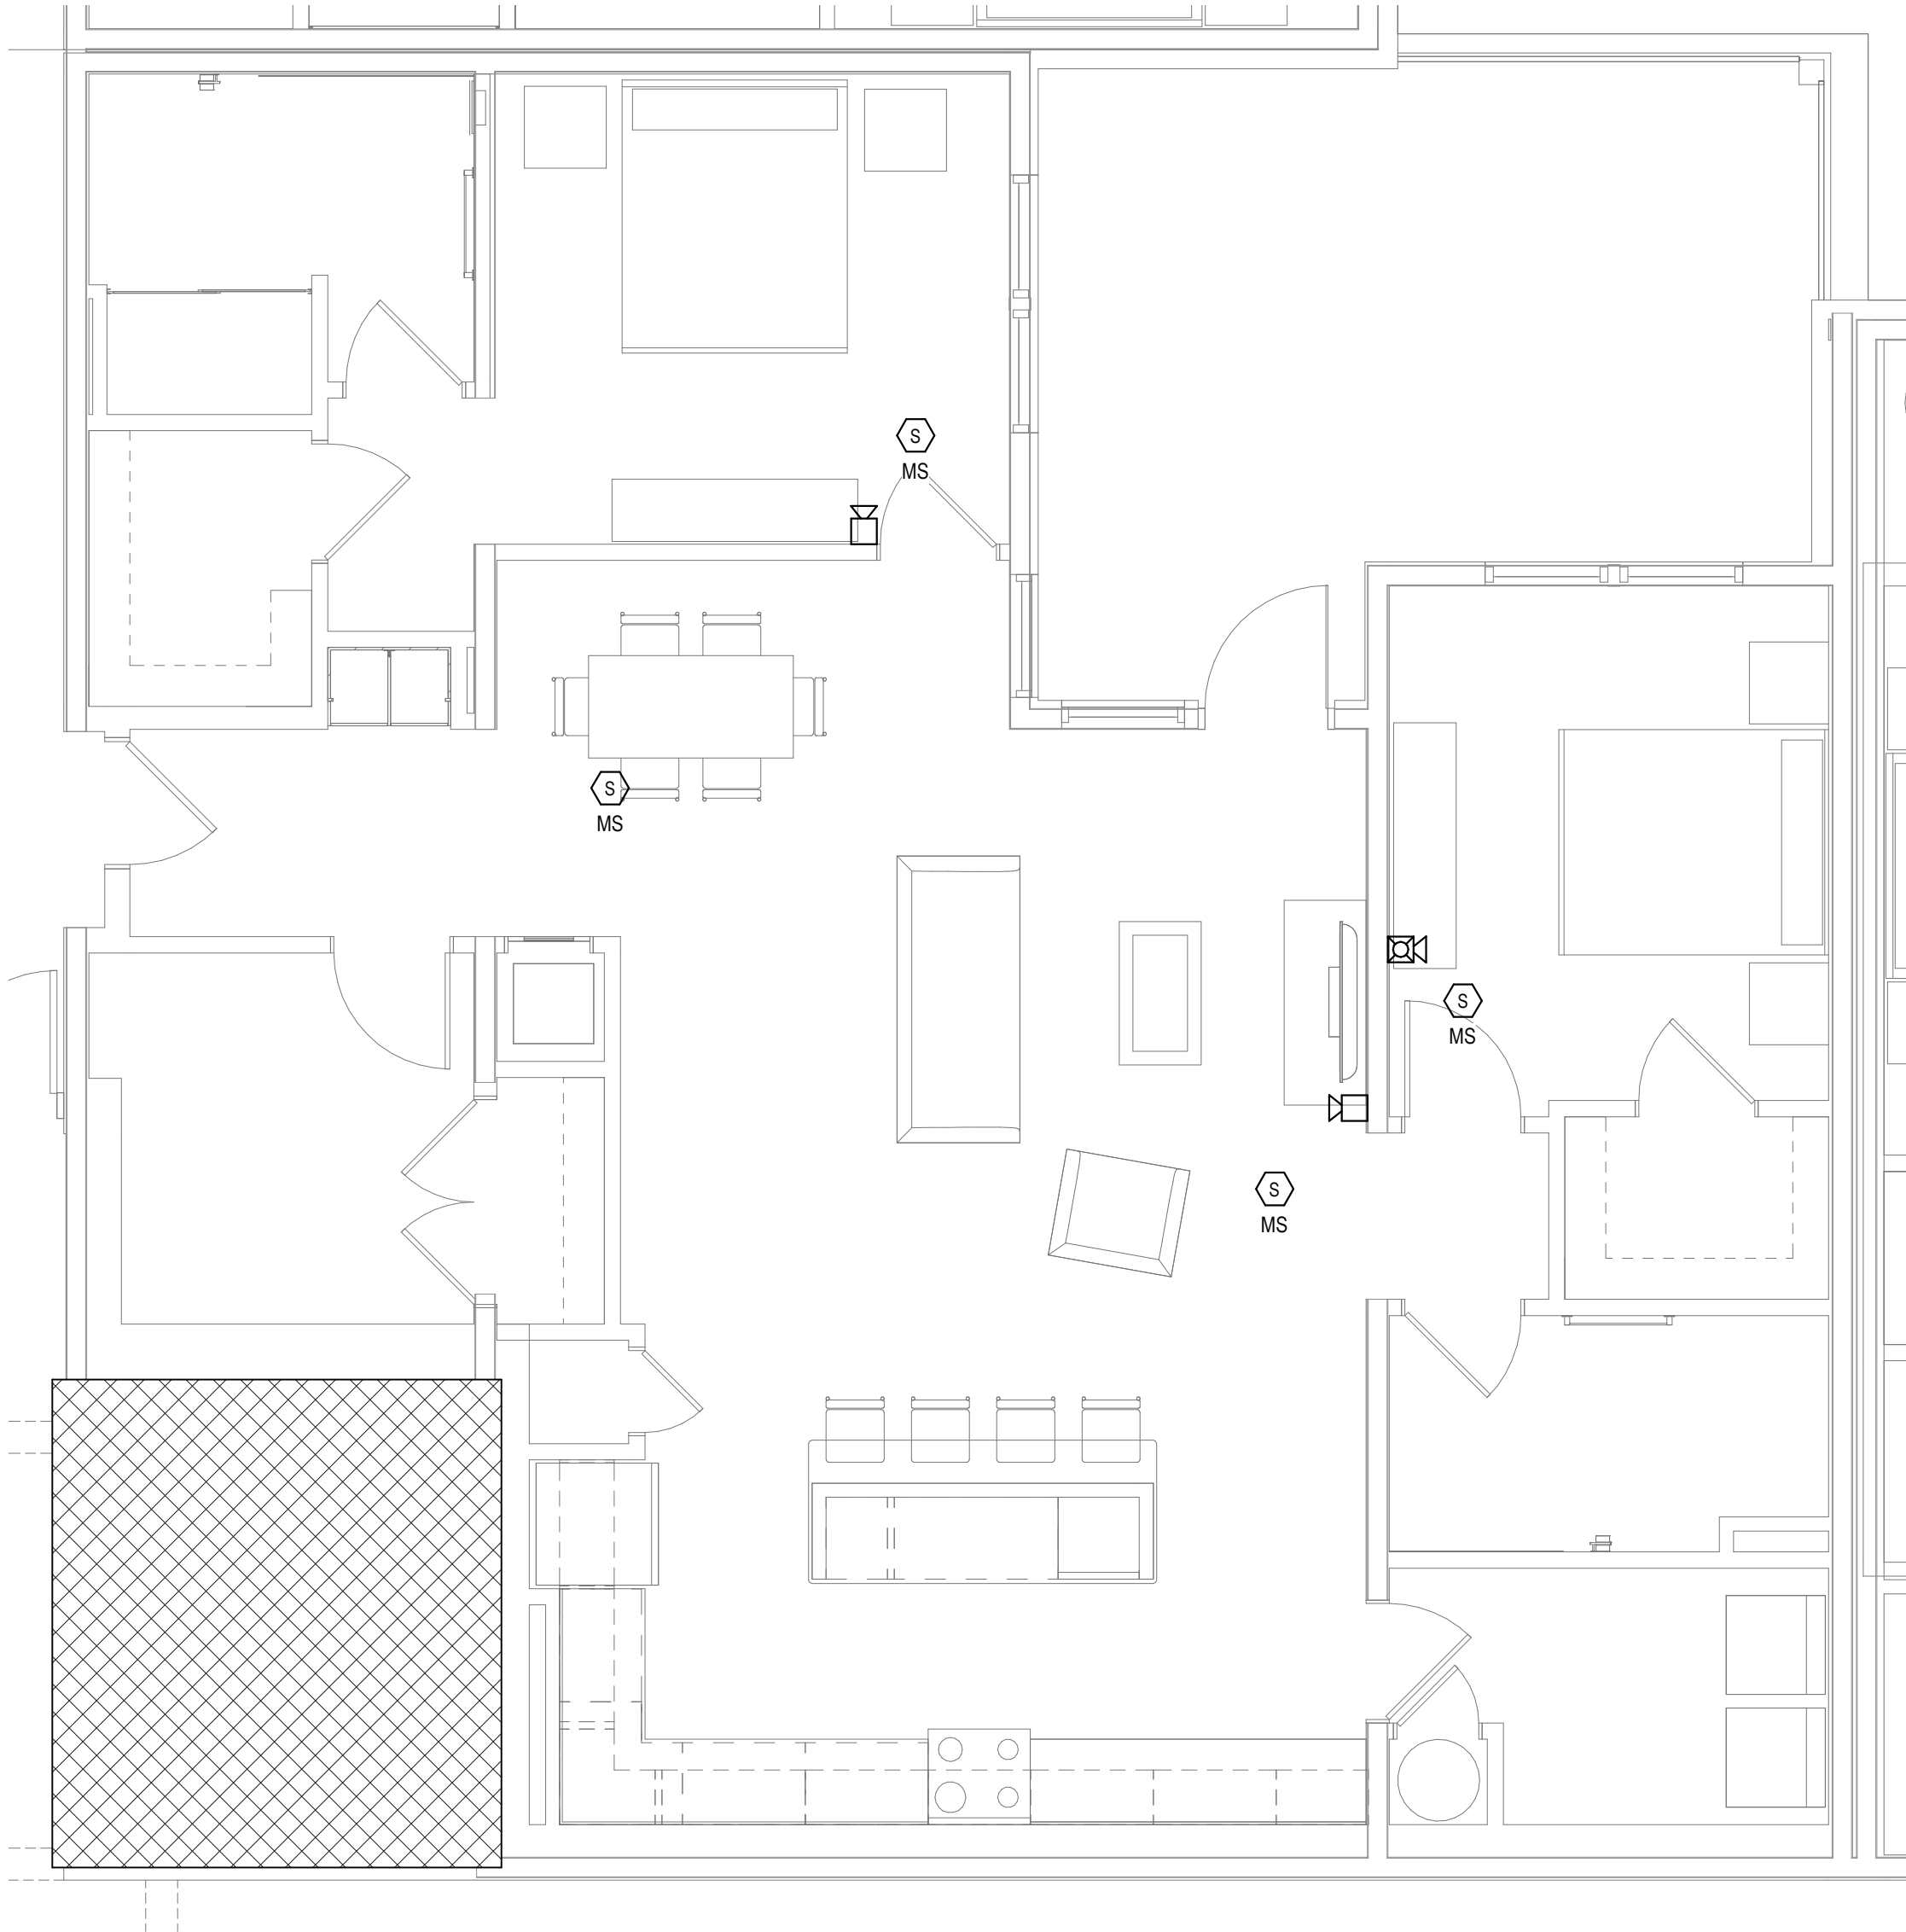


2
FA6.05
FIRE ALARM - UNIT - E (FW-1) PLAN
1/4" = 1'-0"



3
FA6.05
FIRE ALARM - UNIT - E (FW-2) PLAN
1/4" = 1'-0"



4
FA6.05
FIRE ALARM - UNIT - E (FW-3) PLAN
1/4" = 1'-0"

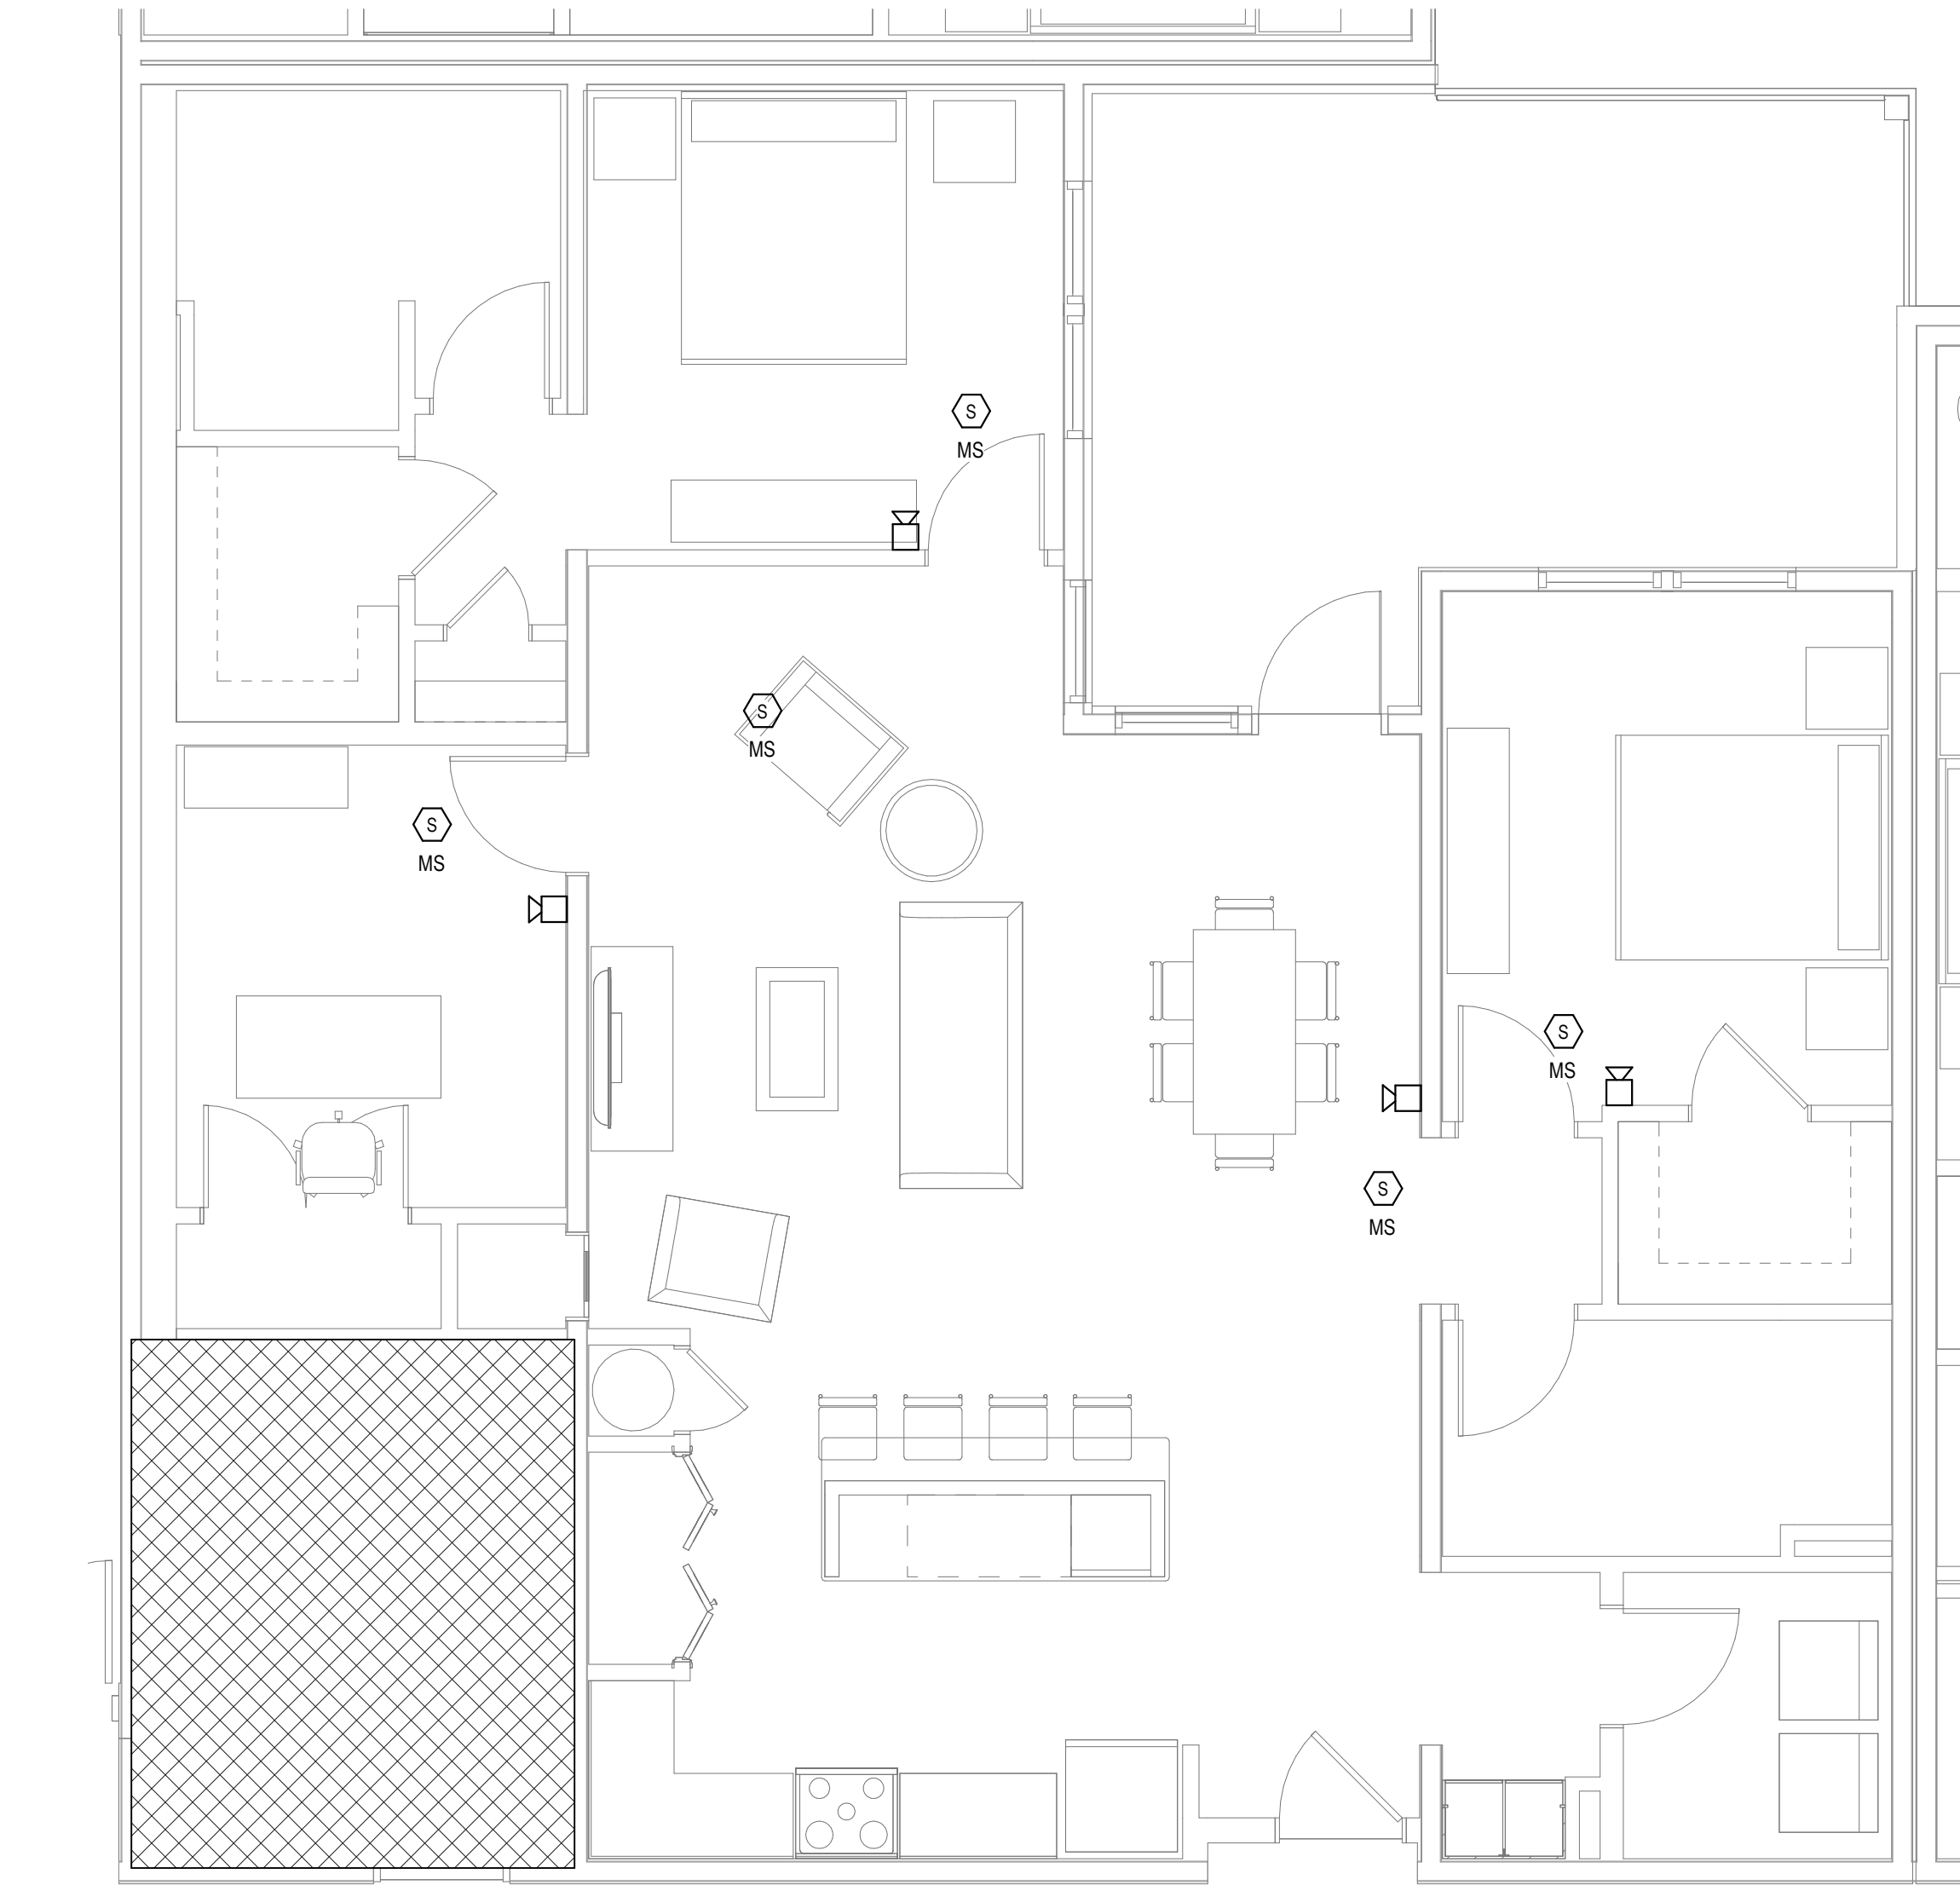

1 FIRE ALARM - UNIT - E (FW-4) PLAN
FA6.06 1/4" = 1'-0"

- FIRE ALARM GENERAL NOTES
1.

REFER TO SHEETS FA0.01 FOR NOTES, SYMBOLS AND ABBREVIATIONS.

2.

EC SHALL REFER TO TELECOM, SECURITY & AV DRAWINGS, DETAILS FOR FINAL DEVICE LOCATIONS & RACEWAY REQUIREMENTS.

3.

REFER TO MECHANICAL PLANS FOR DUCT SMOKE DETECTOR AND FIRE SMOKE DAMPER LOCATIONS. PROVIDE FA CONNECTION AND WIRE AS REQUIRED.

4.

REFER TO FIRE PROTECTION PLANS FOR TAMPER AND FLOW SWITCH LOCATIONS. PROVIDE FA CONNECTION AND WIRE AS REQUIRED.

5.

PROVIDE AREA SMOKE DETECTORS IN ELEVATORS LOBBIES AND ELEVATOR MACHINE ROOM(S). SMOKE DETECTORS SHALL BE LOCATED ON THE CEILING WITHIN 21 FEET OF THE CENTERLINE OF EACH ELEVATOR DOOR WITHIN THE ELEVATOR BANK UNDER CONTROL OF THE DETECTOR FOR ELEVATOR LOBBIES UP TO 15 FEET IN HEIGHT WITH FLAT AND SMOOTH CEILINGS. FOR HIGHER AND UNEVEN CEILINGS, ADDITIONAL SMOKE DETECTORS MAY BE REQUIRED.

6.

MANUAL FIRE ALARM BOXES SHALL BE LOCATED WITHIN 5 FEET OF EACH EXIT DOORWAY ON EACH FLOOR.

7.

DUCT SMOKE DETECTORS AND DUCT SMOKE DETECTORS TEST STATIONS LOCATIONS TO BE COORDINATED WITH THE MECHANICAL DRAWINGS.

8.

PROVIDE AND INSTALL SYSTEM FIRE ALARM ADDRESSABLE DUCT SMOKE DETECTORS AS INDICATED ON THE MECHANICAL FLOOR PLANS AND RISERS FOR FIRE-SMOKE DAMPERS AND SMOKE DAMPERS. PROVIDE ADDRESSABLE CONTROL RELAY AT EACH DAMPER.

9.


PROVIDE 120V EMERGENCY POWER TO ALL FIRE/SMOKE AND SMOKE DAMPERS INDICATED ON THE MECHANICAL DRAWINGS.

10.

THESE FIRE ALARM DRAWINGS ARE PERFORMANCE SPECIFICATION ONLY. CONTRACTOR SHALL PROVIDE A COMPLETE SYSTEM DESIGN IN COMPLIANCE WITH NFPA 72, THE IBC, NFPA 91, AND ANY OTHER ENFORCED CODES AND AMENDMENTS, INCLUDING ENGINEERED SIGNED AND SEALED DRAWINGS, POINT TO POINT WIRING WITH PROPOSED CIRCUITING OR CONDUIT ROUTING, ALL APPLICABLE CALCULATIONS, DEVICE MANUFACTURERS AND QUANTITIES, WIRING DIAGRAMS, AND SHOP SUBMITTALS. CONTRACTOR SHALL BE RESPONSIBLE FOR ALL ASSOCIATED PERMITS, INSPECTIONS, AND TESTING. CONSULT LOCAL BUILDING AUTHORITY AND FIRE MARSHAL REGARDING LOCAL AREA'S REQUIREMENTS.

ALL REPORTS, PLANS, SPECIFICATIONS AND COMPUTER FILES RELATING TO THIS PROJECT ARE THE PROPERTY OF THE MARTIN ARCHITECTURAL GROUP. THE MARTIN ARCHITECTURAL GROUP RETAINS ALL COMMON LAW, STATUTE AND OTHER RESERVED RIGHTS INCLUDING THE COPY RIGHT THERE TO. REPRODUCTION OF THE MATERIAL HEREIN OR SUBSTANTIAL USE WITHOUT WRITTEN PERMISSION OF THE MARTIN ARCHITECTURAL GROUP VIOLATES THE COPYRIGHT LAWS OF THE UNITED STATES AND WILL BE SUBJECT TO LEGAL PROSECUTION.

© The Martin Architectural Group, P.C.

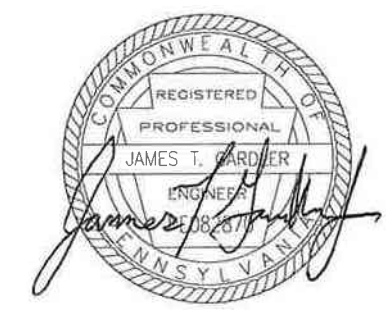

THE MARTIN ARCHITECTURAL GROUP, P.C.

ARCHITECTS AND LAND PLANNERS

A PROFESSIONAL CORPORATION

240 NORTH 22ND STREET, PHILADELPHIA, PA, 19103
P (215) 665-1080 F (215) 561-5064

P.A.: JTG
P.M.: TRT
DRAWN BY: Author
PROJECT NO: 1022747

NO.	REVISION	DATE
1	SCHEMATIC BUDGET PRICING SET	11/01/2022
1	PERMIT SET	12/20/2022

Project Status

FIRE ALARM - UNIT PLANS

Granite Run Apartments

MIDDLETOWN TOWNSHIP, PA

SCALE: AS INDICATED
DATE: 11/01/22